
DPR (VOL – 01.1)
TENDER DRAWINGS

Chinabat, Meghalaya



Submitted By:




Studio archohm


Submitted To:



MEGHALAYAN AGE LIMITED

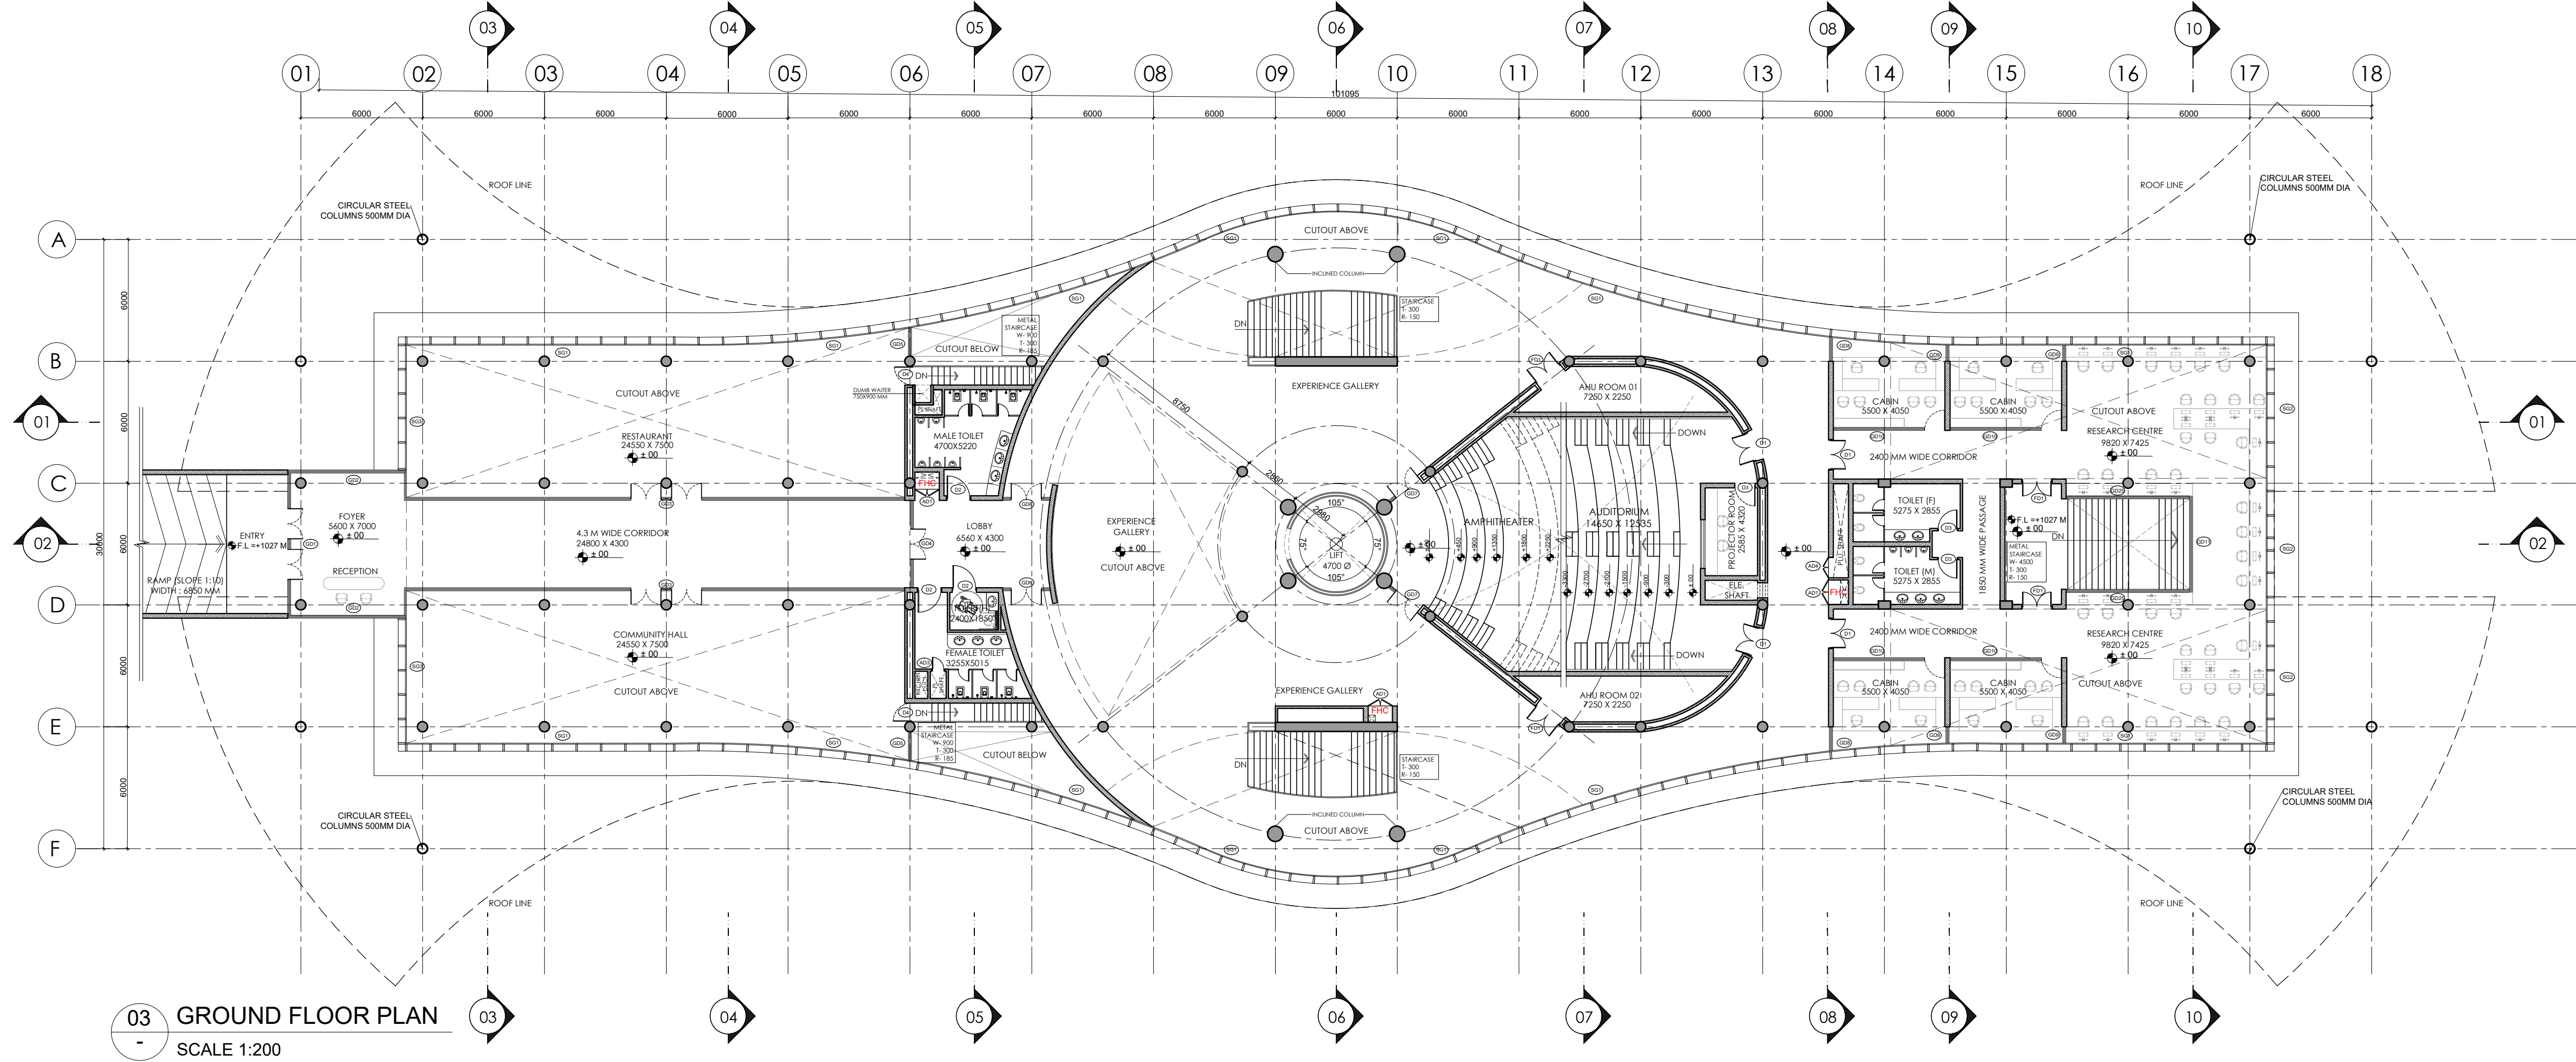

03 GROUND FLOOR PLAN
SCALE 1:200

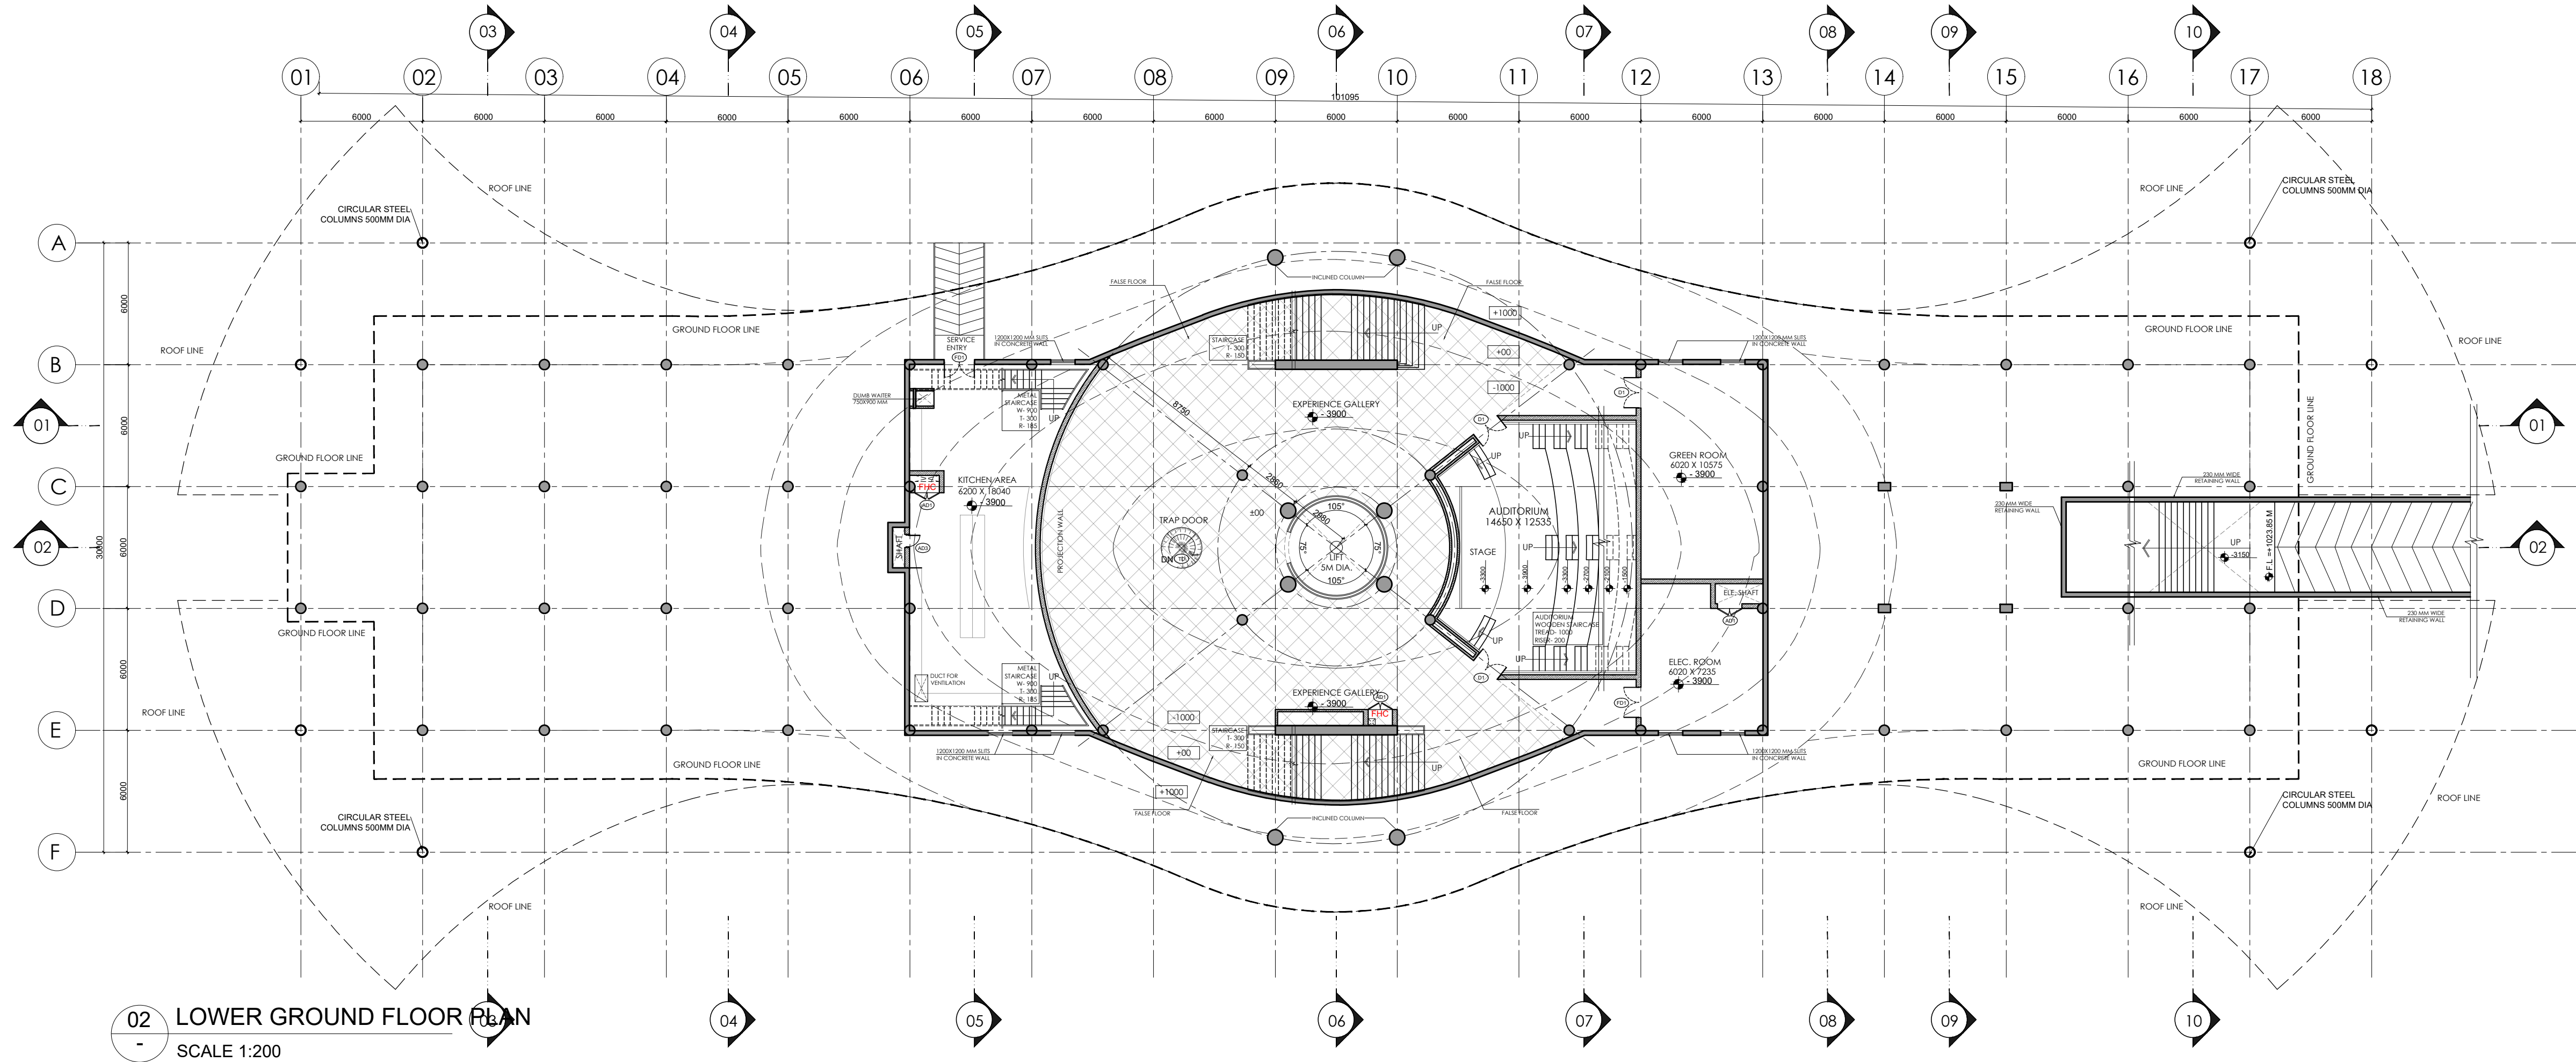

02 LOWER GROUND FLOOR PLAN
SCALE 1:200

- NOTES:
- DO NOT SCALE THE DRAWING. FOLLOW ONLY FIGURED DIMENSIONS.
 - ALL DIMENSIONS GIVEN IN THIS DRAWING ARE IN MILLIMETERS UNLESS NOTED OTHERWISE.
 - ALL DIMENSIONS TO BE VERIFIED ON SITE AND APPROVED BY THE SITE ENGINEER.
 - ANY DISCREPANCY OR AMBIGUITY IN THE DRAWINGS SHOULD IMMEDIATELY BE BROUGHT TO NOTICE OF THE ARCHITECT.
 - ALL DRAWINGS SHOULD BE READ IN CONJUNCTION WITH OTHER RELEVANT ARCHITECTURAL, STRUCTURAL, PLUMBING, MECHANICAL AND ELECTRICAL DRAWINGS.
 - THE ± 0 REFERS TO LEVEL ESTABLISHED AT SITE IN PRESENCE OF THE SITE SUPERVISOR AND THE ARCHITECT. ALL REMAINING LEVELS ARE RELATIVE TO THIS LEVEL.
 - THIS DRAWING IS THE COPYRIGHT OF ARCHOHM CONSULTANTS AND MUST NOT BE RETAINED, COPIED OR USED WITHOUT THEIR AUTHORITY.

REVISIONS			
No.	Date	Descriptions	Revision by

Client:
MEGHALAYAN AGE LIMITED (MAL)

Project:
TRIBAL HERITAGE CENTRE, MANDALGRE, MEGHALAYA


Architects:



Structural Consultants:



Electrical Consultants:

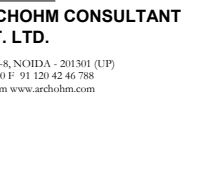

Mechanical Consultants:



Drawn By

SJ

Checked By

GK

Design By

SG


Sheet Title:
**TRIBAL HERITAGE CENTRE
EXHIBITION & RESEARCH CENTER
FLOOR PLANS
(SHEET 01 OF 04)**

Date:
30-08-2024


Drawing No.:
A-232409-B1-01-01

Project No.:
A-232409

A1 R0

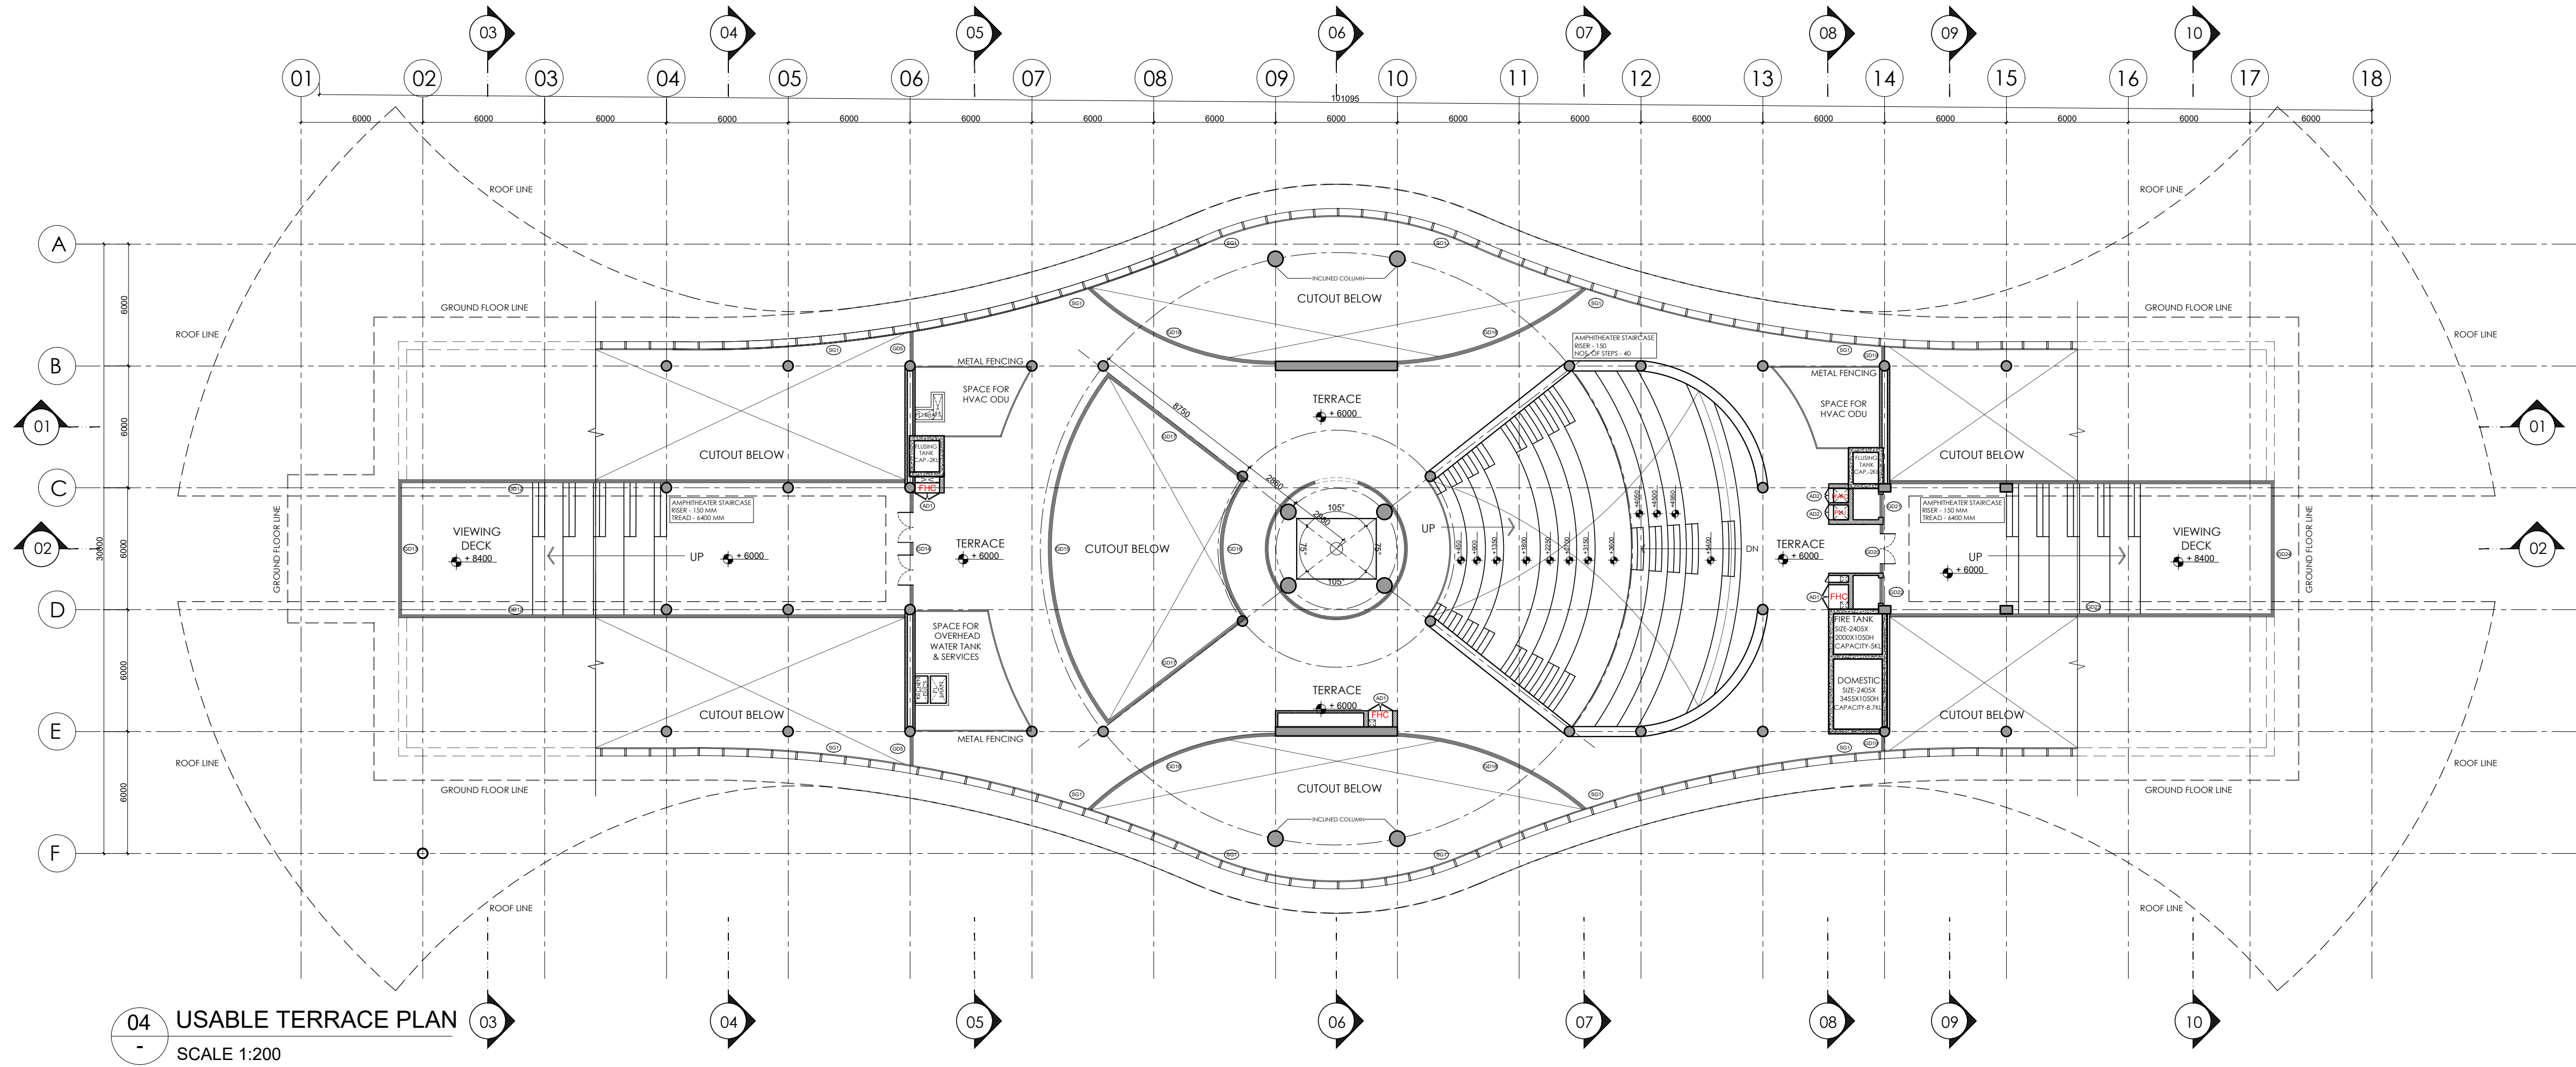

04 USABLE TERRACE PLAN
SCALE 1:200

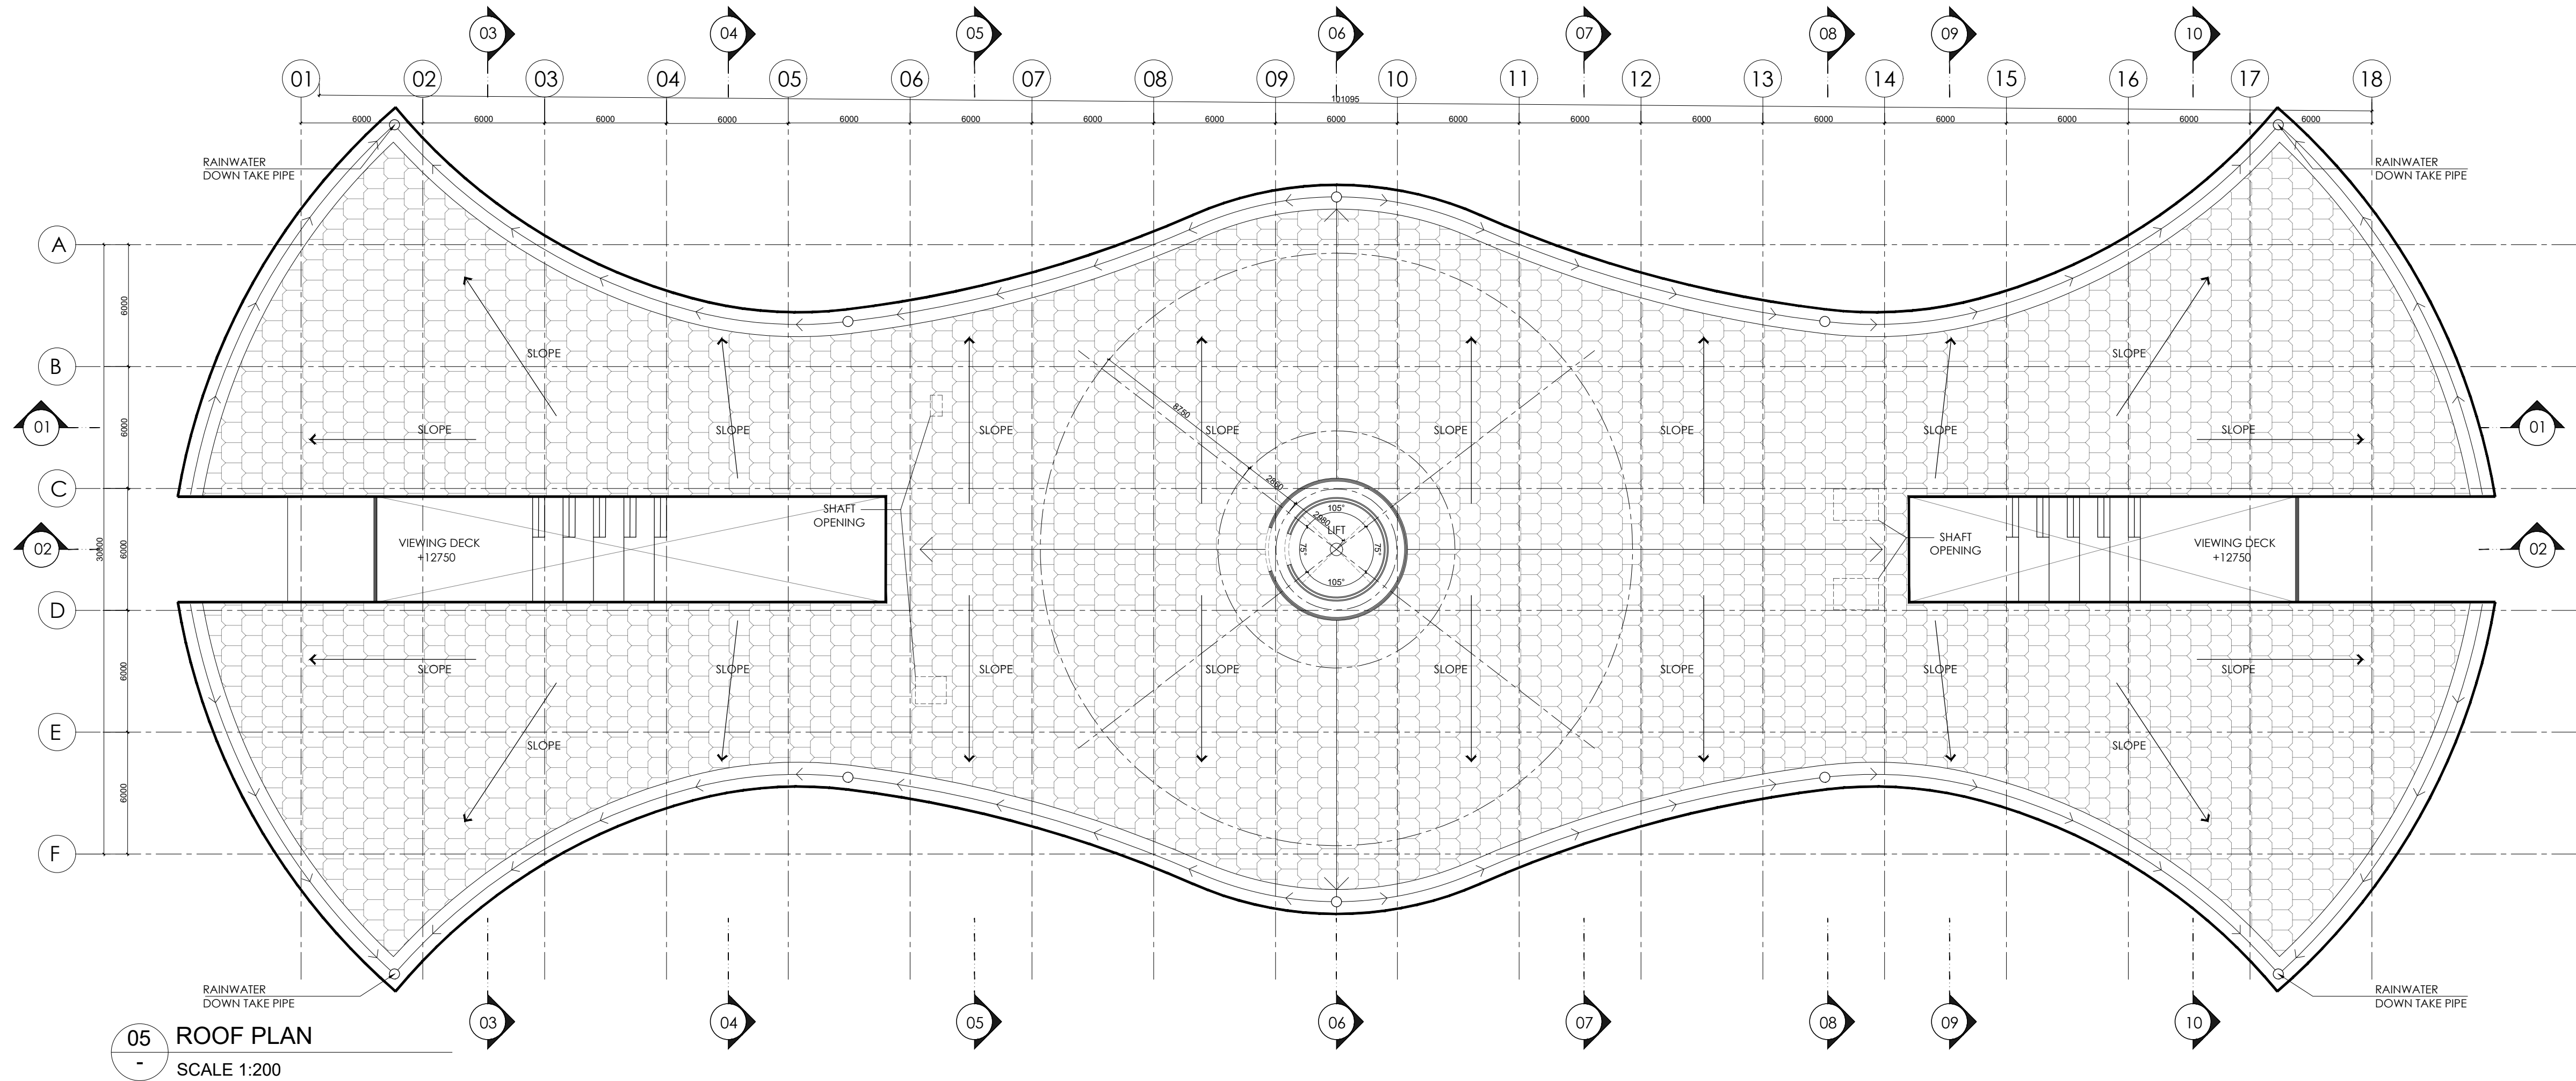

05 ROOF PLAN
SCALE 1:200

NOTES:

- DO NOT SCALE THE DRAWING. FOLLOW ONLY FIGURED DIMENSIONS.
- ALL DIMENSIONS GIVEN IN THIS DRAWING ARE IN MILLIMETERS UNLESS NOTED OTHERWISE.
- ALL DIMENSIONS TO BE VERIFIED ON SITE AND APPROVED BY THE SITE ENGINEER.
- ANY DISCREPANCY OR AMBIGUITY IN THE DRAWINGS SHOULD IMMEDIATELY BE BROUGHT TO NOTICE OF THE ARCHITECT.
- ALL DRAWINGS SHOULD BE READ IN CONJUNCTION WITH OTHER RELEVANT ARCHITECTURAL, STRUCTURAL, PLUMBING, MECHANICAL AND ELECTRICAL DRAWINGS.
- THE ± 0 REFERS TO LEVEL ESTABLISHED AT SITE IN PRESENCE OF THE SITE SUPERVISOR AND THE ARCHITECT. ALL REMAINING LEVELS ARE RELATIVE TO THIS LEVEL.
- THIS DRAWING IS THE COPYRIGHT OF ARCHOHM CONSULTANTS AND MUST NOT BE RETAINED, COPIED OR USED WITHOUT THEIR AUTHORITY.

REVISIONS			
No.	Date	Descriptions	Revision by


Client:
MEGHALAYAN AGE LIMITED (MAL)

Project:
TRIBAL HERITAGE CENTRE, MANDALGRE, MEGHALAYA


Architects:



Structural Consultants:

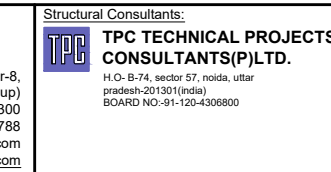

Electrical Consultants:

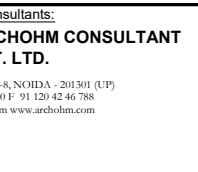

MEP Consultants:



Drawn By:

SJ

Checked By:

GK

Design By:

SG

Sheet Title:
**TRIBAL HERITAGE CENTRE
EXHIBITION & RESEARCH CENTER
FLOOR PLANS
(SHEET 02 OF 04)**

Date:

30-08-2024

Drawing No.:

A-232409-B1-01-02

Scale:


1:200

Project No.:

A-232409

A1

R0

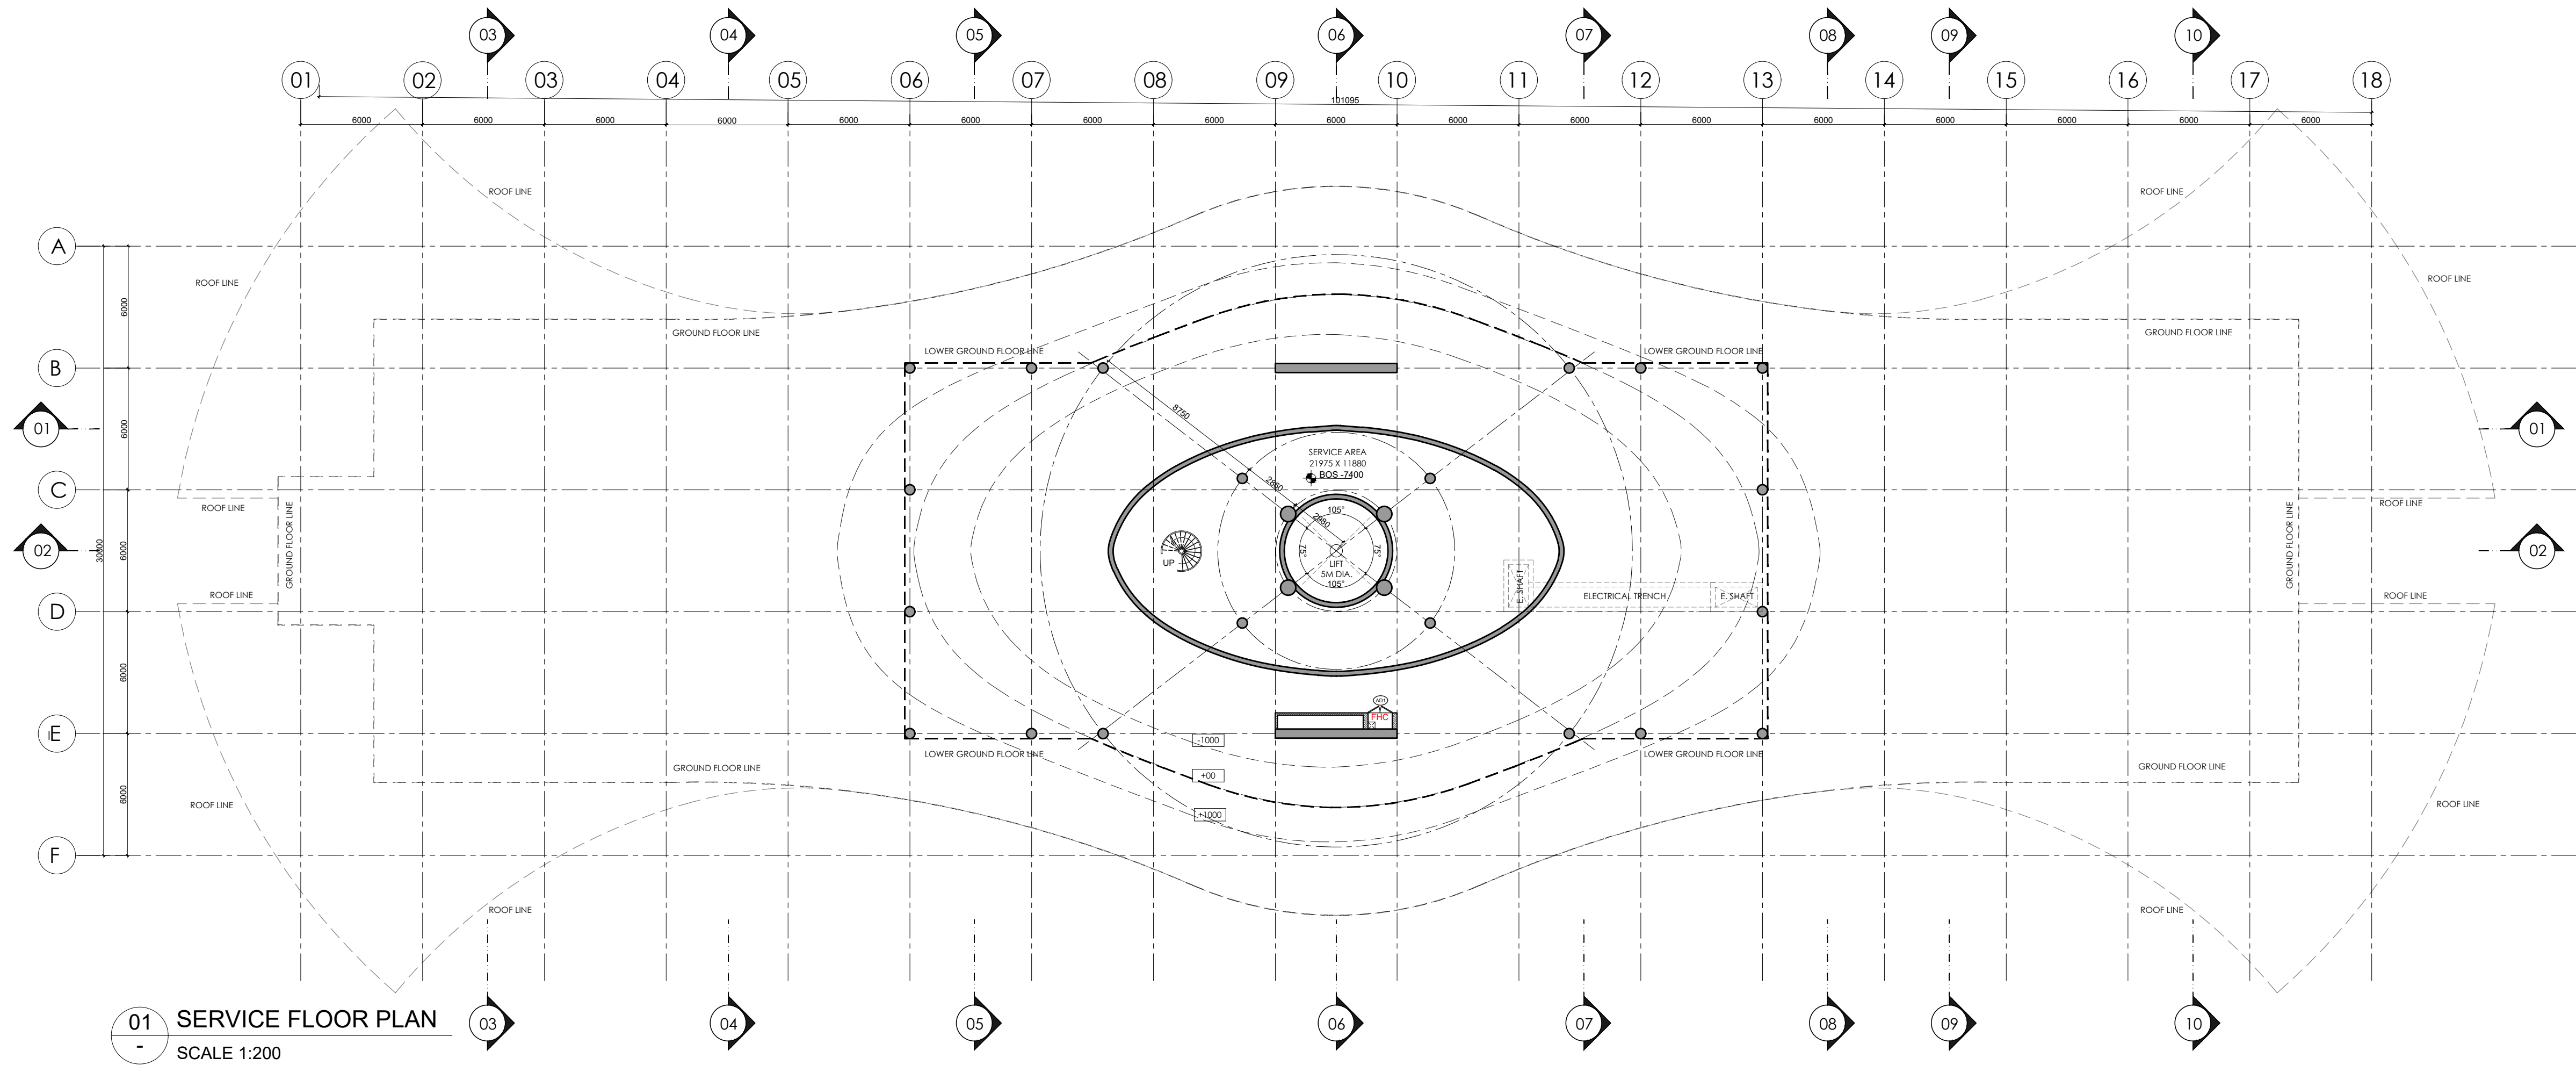

DOOR WINDOW SCHEDULE TRIBAL HERITAGE CENTRE, MANDALGRE						
EXHIBITION AND RESEARCH CENTRE						
GLAZING SCHEDULE						
TAG	WIDTH	HEIGHT	CILL	LINTEL	MATERIAL	TYPE
GD1	7300	5800	0	5800	DOUBLE GLAZED UNIT	CURTAIN GLAZING
GD2	5800	5800	0	5800	DOUBLE GLAZED UNIT	CURTAIN GLAZING
GD3	26000	5800	0	5800	DOUBLE GLAZED UNIT	CURTAIN GLAZING
GD4	4300	5350	0	5350	DOUBLE GLAZED UNIT	CURTAIN GLAZING
GD5	1450	5350	0	5350	DOUBLE GLAZED UNIT	CURTAIN GLAZING
GD6	2335	5800	0	5800	DOUBLE GLAZED UNIT	CURTAIN GLAZING
GD7	1870	5350	0	5350	DOUBLE GLAZED UNIT	CURTAIN GLAZING
GD8	1185	5800	0	5800	DOUBLE GLAZED UNIT	CURTAIN GLAZING
GD9	800	5800	0	5800	DOUBLE GLAZED UNIT	CURTAIN GLAZING
GD10	5500	5800	0	5800	DOUBLE GLAZED UNIT	CURTAIN GLAZING
GD11	4750	8200	0	8200	DOUBLE GLAZED UNIT	CURTAIN GLAZING
GD12	24845	VARIES FROM 3550 TO 1150	0	VARIES FROM 3550 TO 1150	DOUBLE GLAZED UNIT	CURTAIN GLAZING
GD13	6800	1200	0	1200	DOUBLE GLAZED UNIT	CURTAIN GLAZING
GD14	5600	4790	0	4790	DOUBLE GLAZED UNIT	CURTAIN GLAZING
GD15	18600	5800	0	5800	DOUBLE GLAZED UNIT	CURTAIN GLAZING
GD16	7320	5800	0	5800	DOUBLE GLAZED UNIT	CURTAIN GLAZING
GD17	5610	5800	0	5800	DOUBLE GLAZED UNIT	CURTAIN GLAZING
GD18	10200	7500	0	7500	DOUBLE GLAZED UNIT	CURTAIN GLAZING
GD19	750	3545	0	3545	DOUBLE GLAZED UNIT	CURTAIN GLAZING
GD20	2400	3240	0	3240	DOUBLE GLAZED UNIT	CURTAIN GLAZING
GD21	1150	3240	0	3240	DOUBLE GLAZED UNIT	CURTAIN GLAZING
GD22	1250	3240	0	3240	DOUBLE GLAZED UNIT	CURTAIN GLAZING
GD23	18940	VARIES FROM 3550 TO 1150	0	VARIES FROM 3550 TO 1150	DOUBLE GLAZED UNIT	CURTAIN GLAZING
GD24	6700	1150	0	1150	DOUBLE GLAZED UNIT	CURTAIN GLAZING
GD25	6230	VARIES FROM 5800 TO 8200	0	VARIES FROM 5800 TO 8200	DOUBLE GLAZED UNIT	CURTAIN GLAZING
SG1	1200	VARIES FROM 3580-13600-3565	0	VARIES FROM 2180-10715-3000	DOUBLE GLAZED UNIT	STRUCTURAL GLAZING
SG2	1200	3315	0	3315	DOUBLE GLAZED UNIT	STRUCTURAL GLAZING
SG3	1200	3315	0	3315	DOUBLE GLAZED UNIT	STRUCTURAL GLAZING

DOOR WINDOW SCHEDULE TRIBAL HERITAGE CENTRE, MANDALGRE							
EXHIBITION AND RESEARCH CENTRE							
DOOR WINDOW SCHEDULE							
TAG	WIDTH	HEIGHT	CILL	LINTEL	MATERIAL	TYPE	REMARK
D1	1500	2400	0	2400	WOODEN DOOR	DOUBLE SWING	
D2	1200	2400	0	2400	WOODEN DOOR	SINGLE SWING	
D3	1000	2400	0	2400	WOODEN DOOR	SINGLE SWING	
D4	900	2400	0	2400	WOODEN DOOR	SINGLE SWING	
AD1	1200	2400	0	2400	WOODEN DOOR	DOUBLE SWING	
AD2	700	2400	0	2400	WOODEN DOOR	DOUBLE SWING	
AD3	650	2400	0	2400	WOODEN DOOR	SINGLE SWING	
AD4	1000	2400	0	2400	WOODEN DOOR	DOUBLE SWING	
FD1	1500	2750	0	2750	FIRE DOOR	DOUBLE SWING	
W1	2400	1800	1000	2800	GLASS	FIXED	
TD	2000 Ø	-	-	-	METAL	TRAP DOOR	



DOOR WINDOW SCHEDULE

- NOTES:
- DO NOT SCALE THE DRAWING. FOLLOW ONLY FIGURED DIMENSIONS.
 - ALL DIMENSIONS GIVEN IN THIS DRAWING ARE IN MILLIMETERS UNLESS NOTED OTHERWISE.
 - ALL DIMENSIONS TO BE VERIFIED ON SITE AND APPROVED BY THE SITE ENGINEER.
 - ANY DISCREPANCY OR AMBIGUITY IN THE DRAWINGS SHOULD IMMEDIATELY BE BROUGHT TO NOTICE OF THE ARCHITECT.
 - ALL DRAWINGS SHOULD BE READ IN CONJUNCTION WITH OTHER RELEVANT ARCHITECTURAL, STRUCTURAL, PLUMBING, MECHANICAL AND ELECTRICAL DRAWINGS.
 - THE ± 0 REFERS TO LEVEL ESTABLISHED AT SITE IN PRESENCE OF THE SITE SUPERVISOR AND THE ARCHITECT. ALL REMAINING LEVELS ARE RELATIVE TO THIS LEVEL.
 - THIS DRAWING IS THE COPYRIGHT OF ARCHOHM CONSULTANTS AND MUST NOT BE RETAINED, COPIED OR USED WITHOUT THEIR AUTHORITY.

REVISIONS			
No.	Date	Descriptions	Revision by

Client:
MEGHALAYAN AGE LIMITED (MAL)

Project:
TRIBAL HERITAGE CENTRE, MANDALGRE, MEGHALAYA

Architects:



©2016, section 4
revised - 2017/01/10
1 91 120 46 40 300
1 91 120 42 46 700
mail@archohm.com
www.archohm.com

Structural Consultants:

TPC TECHNICAL PROJECTS CONSULTANTS PVT. LTD.
H/O: B-14, Sector 07, Noida, U.P.
INDIA
MOBILE: 91-98104-10000
BOONWADI, INDIA

Electrical Consultants:

ARCHOHM CONSULTANT PVT. LTD.
H/O: B-14, Sector 07, Noida, U.P.
INDIA
MOBILE: 91-98104-10000
BOONWADI, INDIA

M/E Consultants:

WAC Engineers INDIA PVT. LTD.
MEP Consultants & Project Managers
P.O. Box: 444444, P.O. Box: 444444
P.O. Box: 444444, P.O. Box: 444444

Drawn By:

SJ

Checked By:

GK

Design By:

SG

Sheet Title:
TRIBAL HERITAGE CENTER EXHIBITION & RESEARCH CENTER FLOOR PLANS (SHEET 03 OF 04)

Date:
30-08-2024


Scale:
1:200

Drawing No.:
A-232409-B1-01-03

Project No.:
A-232409

A1

R0

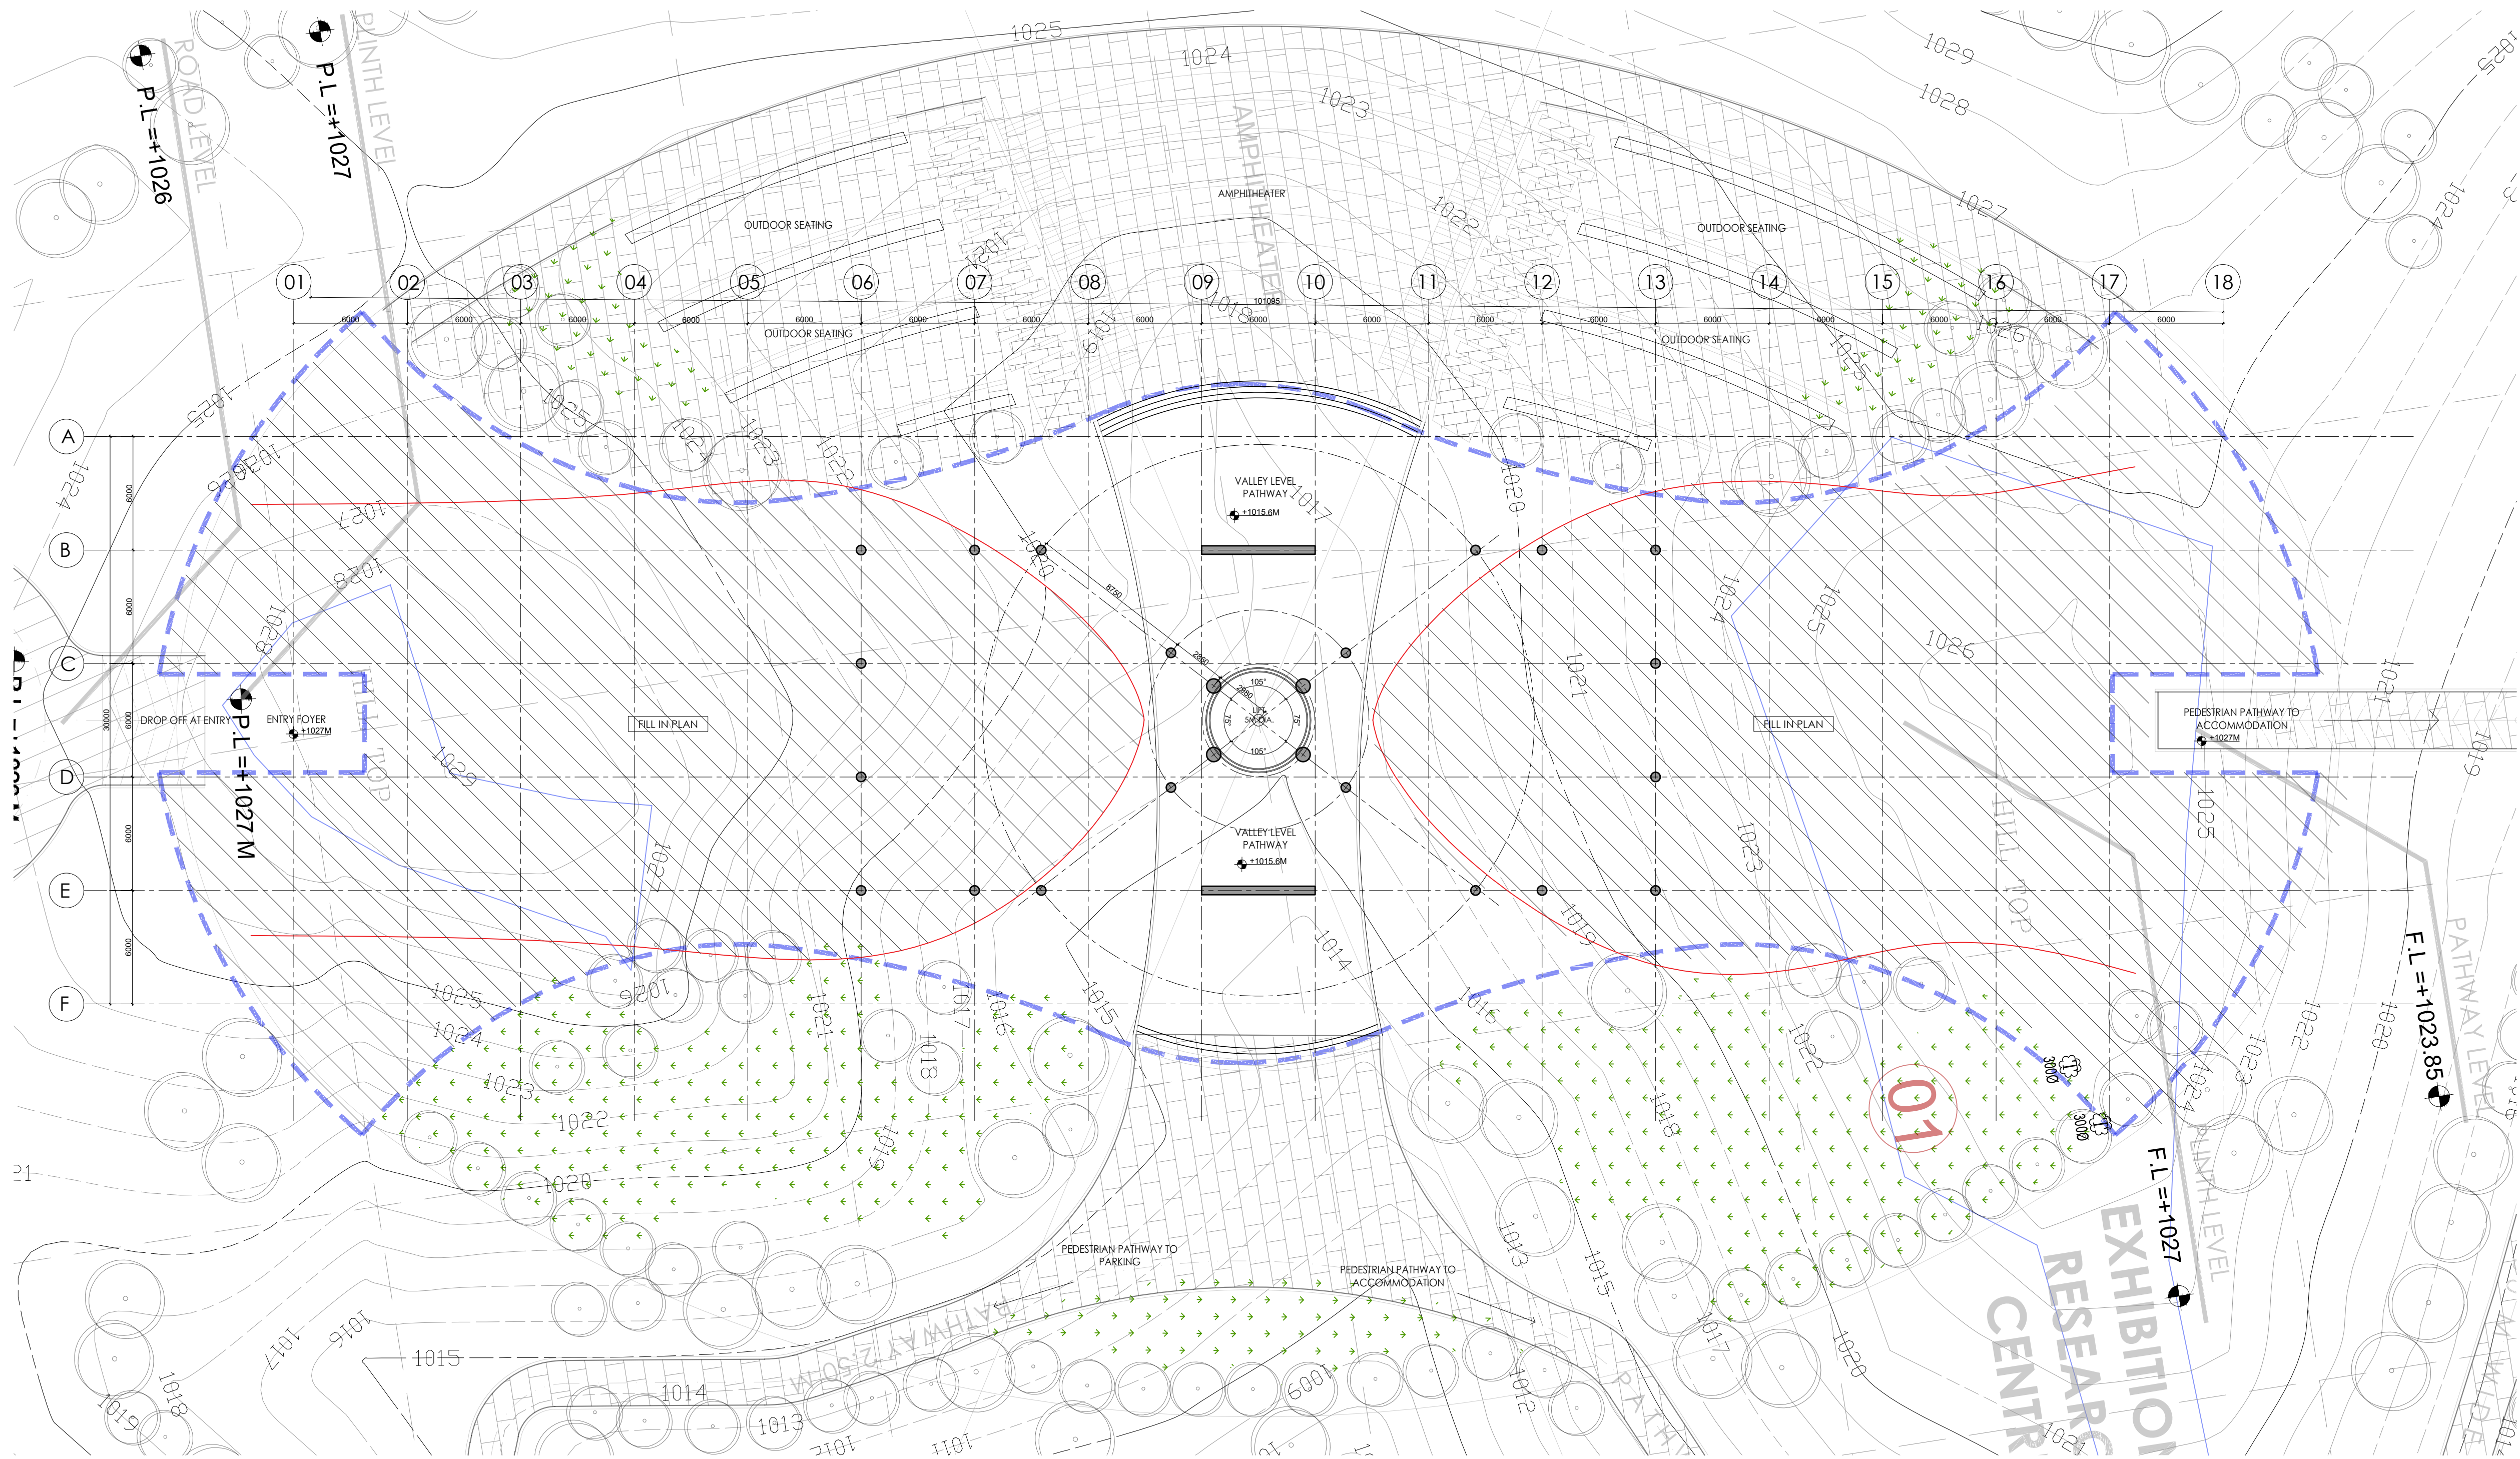

01 VALLEY LEVEL PLAN
A SCALE 1:200

NOTES:

- DO NOT SCALE THE DRAWING. FOLLOW ONLY FIGURED DIMENSIONS.
- ALL DIMENSIONS GIVEN IN THIS DRAWING ARE IN MILLIMETERS UNLESS NOTED OTHERWISE.
- ALL DIMENSIONS TO BE VERIFIED ON SITE AND APPROVED BY THE SITE ENGINEER.
- ANY DISCREPANCY OR AMBIGUITY IN THE DRAWINGS SHOULD IMMEDIATELY BE BROUGHT TO NOTICE OF THE ARCHITECT.
- ALL DRAWINGS SHOULD BE READ IN CONJUNCTION WITH OTHER RELEVANT ARCHITECTURAL, STRUCTURAL, PLUMBING, MECHANICAL AND ELECTRICAL DRAWINGS.
- THE ± 0 REFERS TO LEVEL ESTABLISHED AT SITE IN PRESENCE OF THE SITE SUPERVISOR AND THE ARCHITECT. ALL REMAINING LEVELS ARE RELATIVE TO THIS LEVEL.
- THIS DRAWING IS THE COPYRIGHT OF ARCHOHM CONSULTANTS AND MUST NOT BE RETAINED, COPIED OR USED WITHOUT THEIR AUTHORITY.

REVISIONS

No.	Date	Descriptions	Revision by

Client:

MEGHALAYAN AGE LIMITED (MAL)

Project:

TRIBAL HERITAGE CENTRE, MANDALGRE, MEGHALAYA

Architects:



Structural Consultants:

TPC TECHNICAL PROJECTS CONSULTANTS PVT. LTD.
10/10, B-14, Sector 02, Noida, U.P.
110028
Phone: 91-11-26141111, 91-11-26141112
Fax: 91-11-26141113
Email: tpc@tpc.co.in
www.tpc.co.in

Electrical Consultants:

ARCHOHM CONSULTANT PVT. LTD.
10/10, B-14, Sector 02, Noida, U.P.
110028
Phone: 91-11-26141111, 91-11-26141112
Fax: 91-11-26141113
Email: archohm@archohm.com
www.archohm.com

M/E Consultants:

WAC Engineers INDIA PVT. LTD.
MEP Consultants & Project Managers
10/10, B-14, Sector 02, Noida, U.P.
110028
Phone: 91-11-26141111, 91-11-26141112
Fax: 91-11-26141113
Email: wac@wac.co.in
www.wac.co.in

Drawn By:

SJ

Checked By:

GK

Design By:

SG

Sheet Title:

TRIBAL HERITAGE CENTRE
EXHIBITION & RESEARCH CENTER
(SHEET 04 OF 04)
VALLEY LEVEL PLAN

Date:

30-08-2024

Drawing No.:

A-232409-B1-01-04

Scale:

1:200

Project No.:


A-232409

Sheet No.:


A1

Sheet No.:


R0

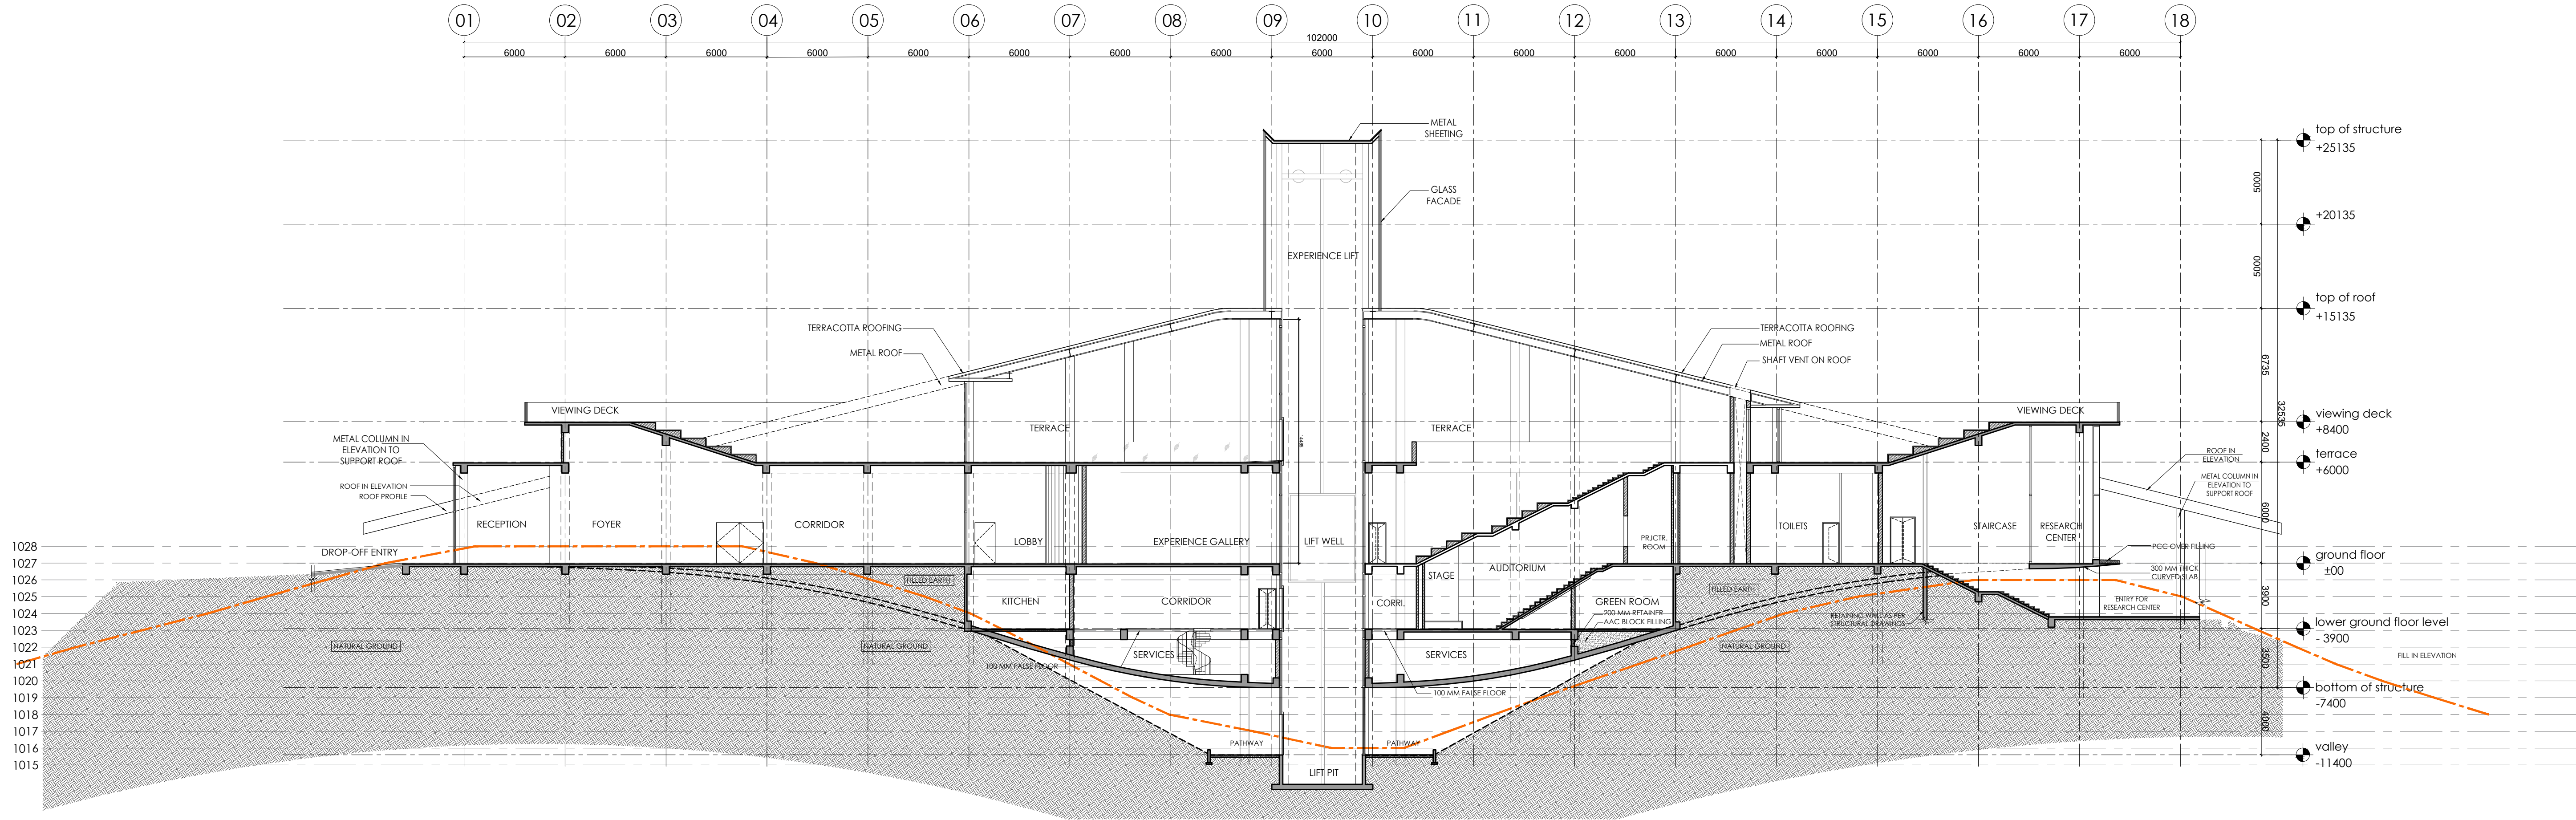


07 SECTION - 02
SCALE 1:200

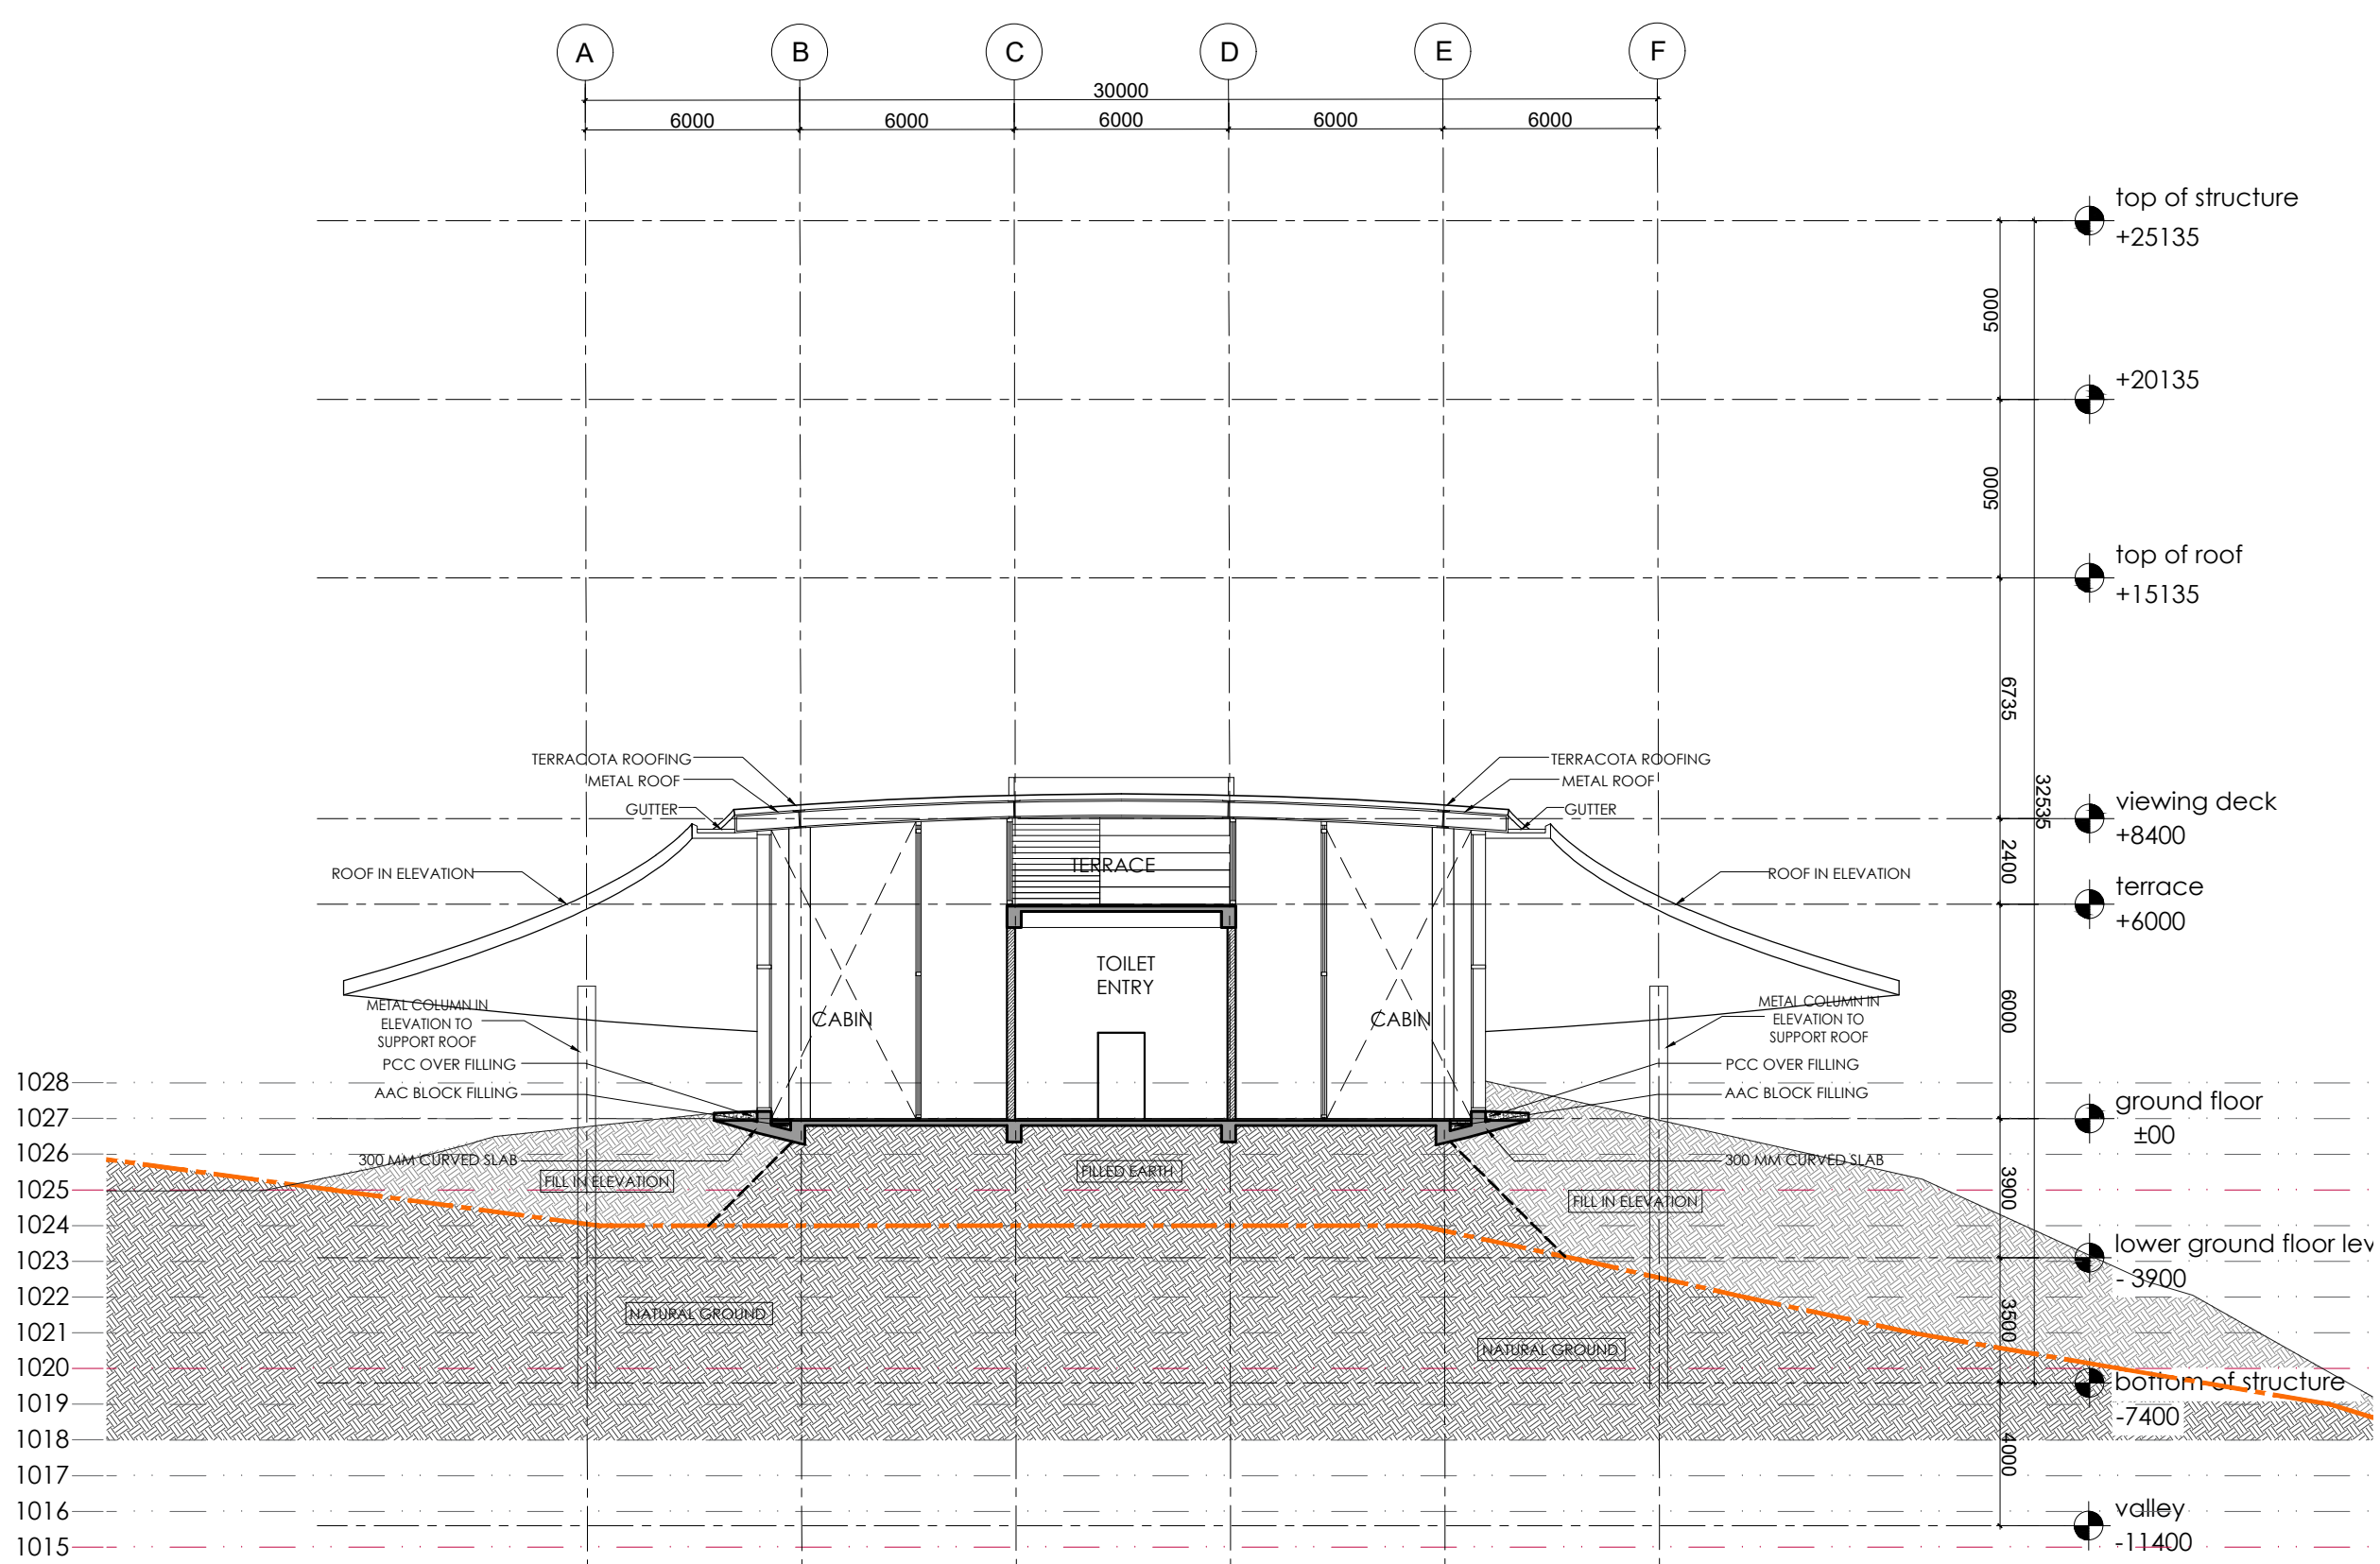

14 SECTION - 09
SCALE 1:200

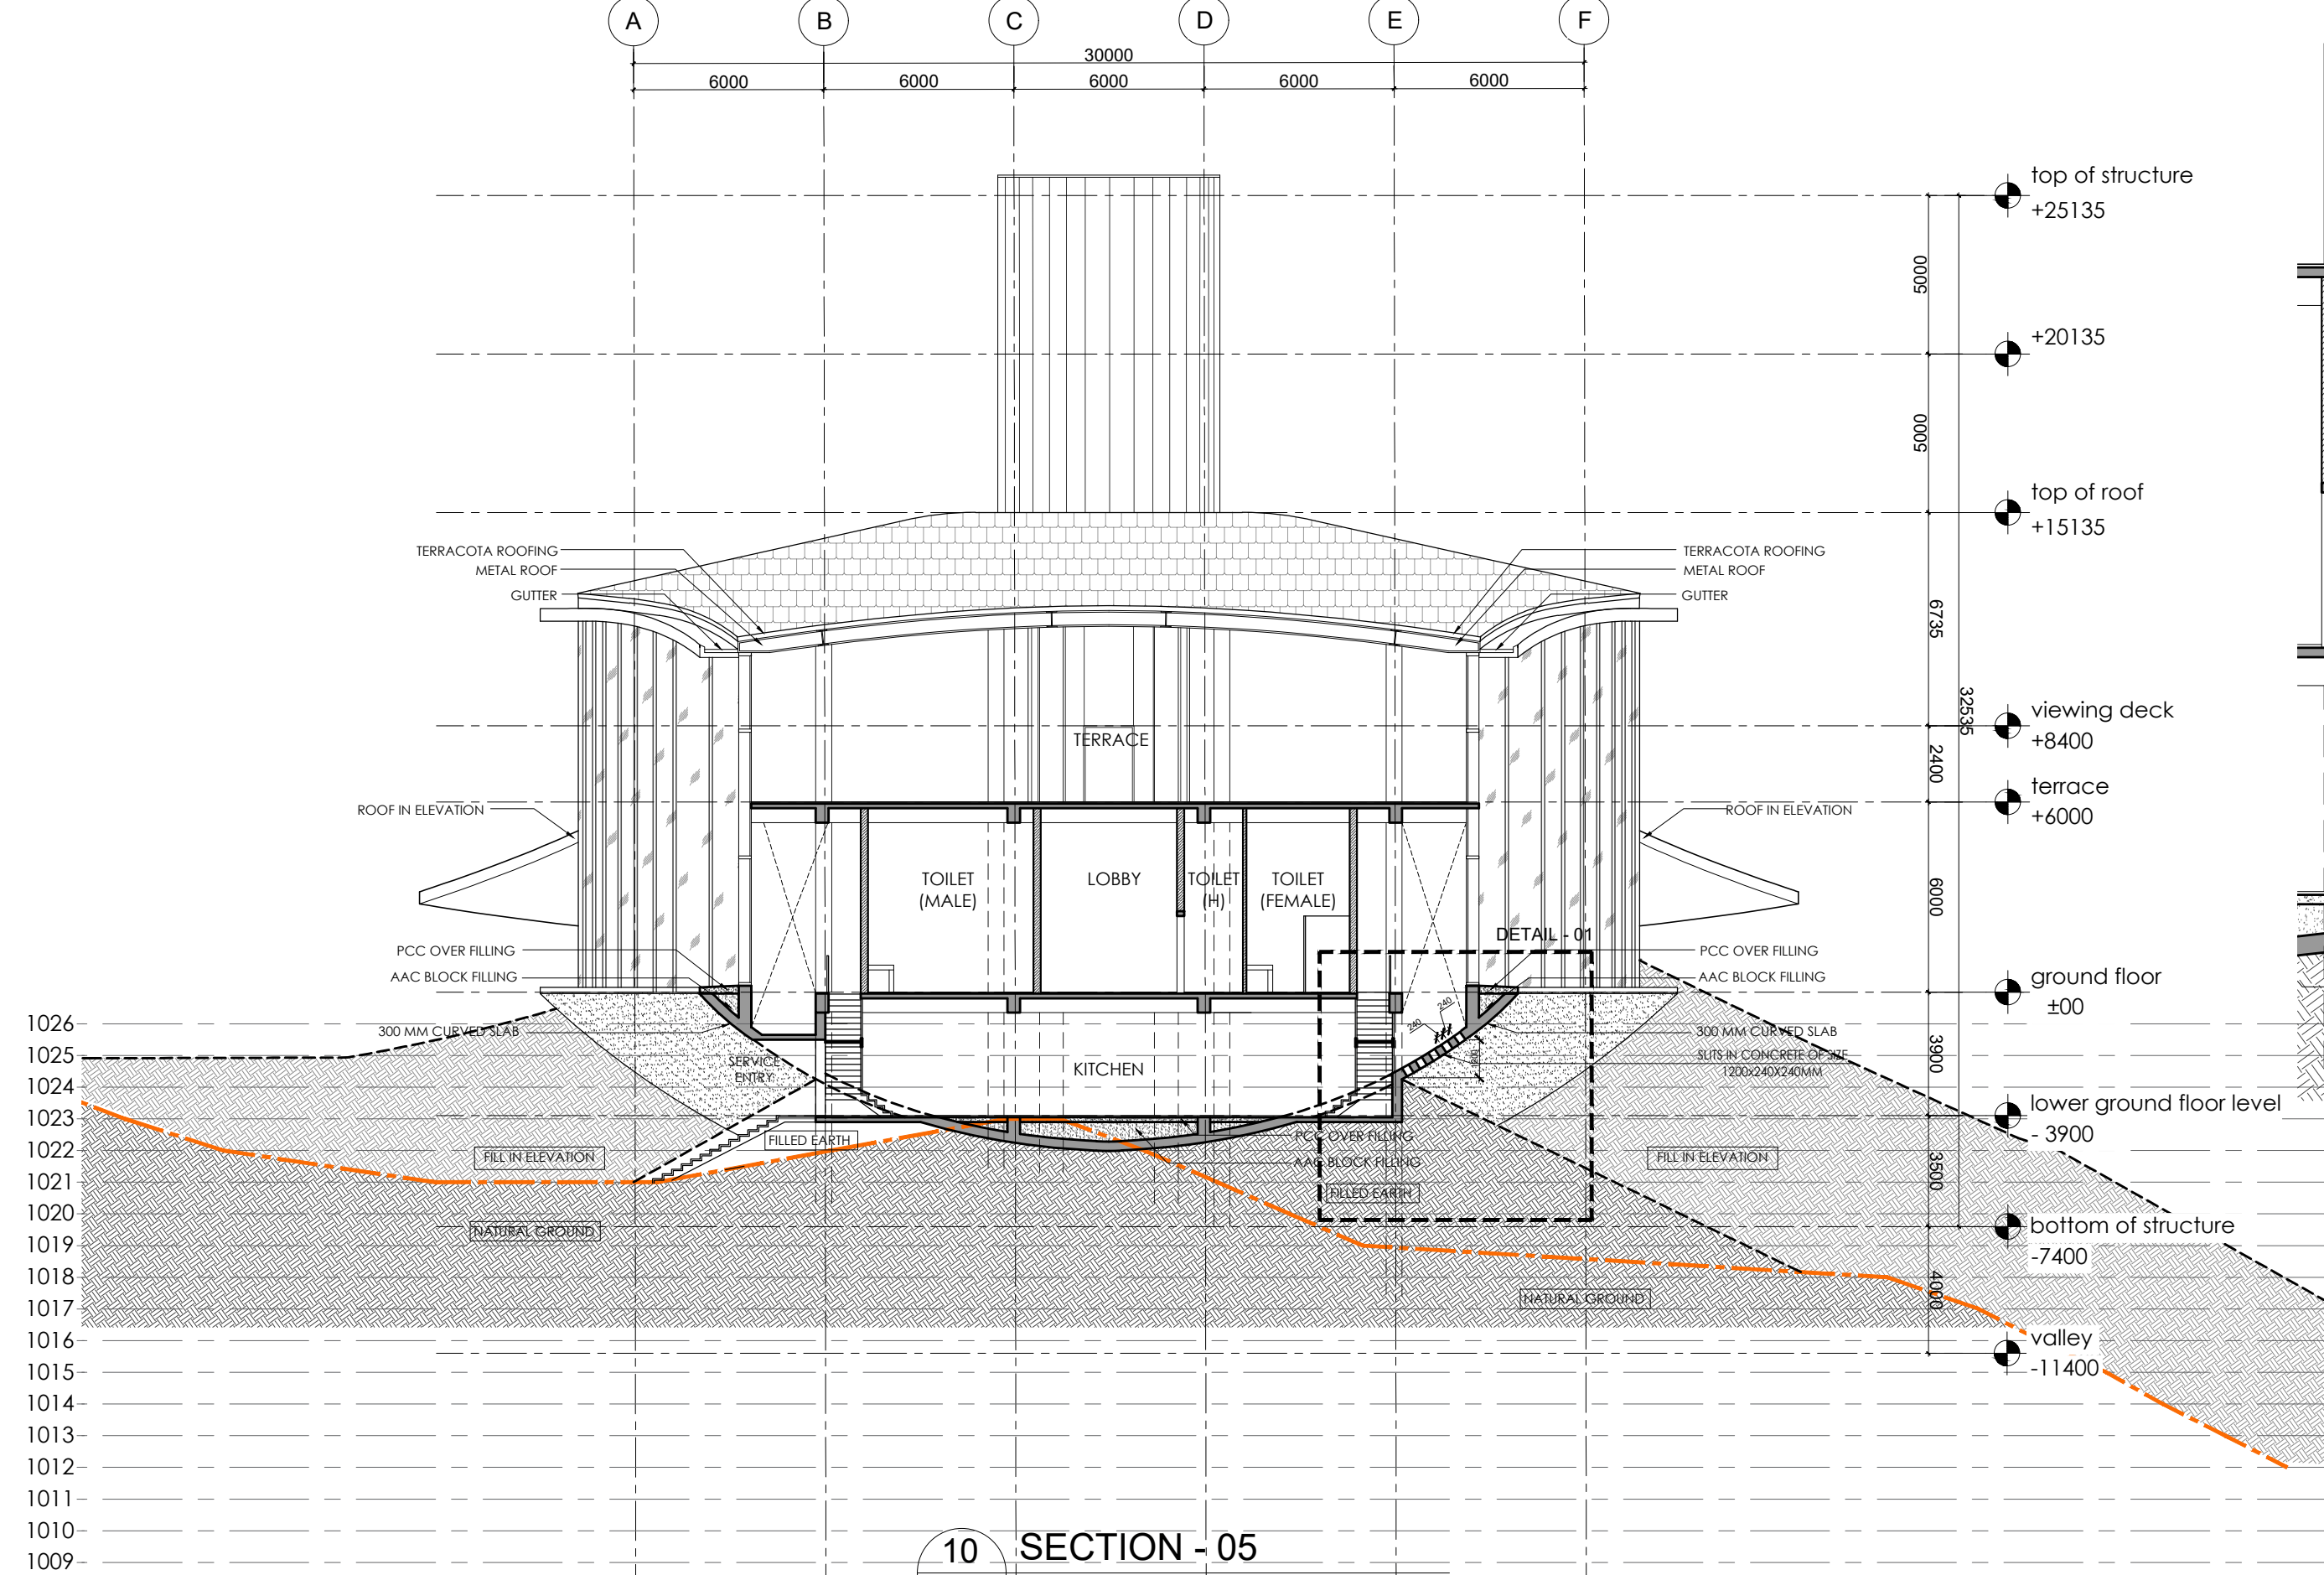

10 SECTION - 05
SCALE 1:200

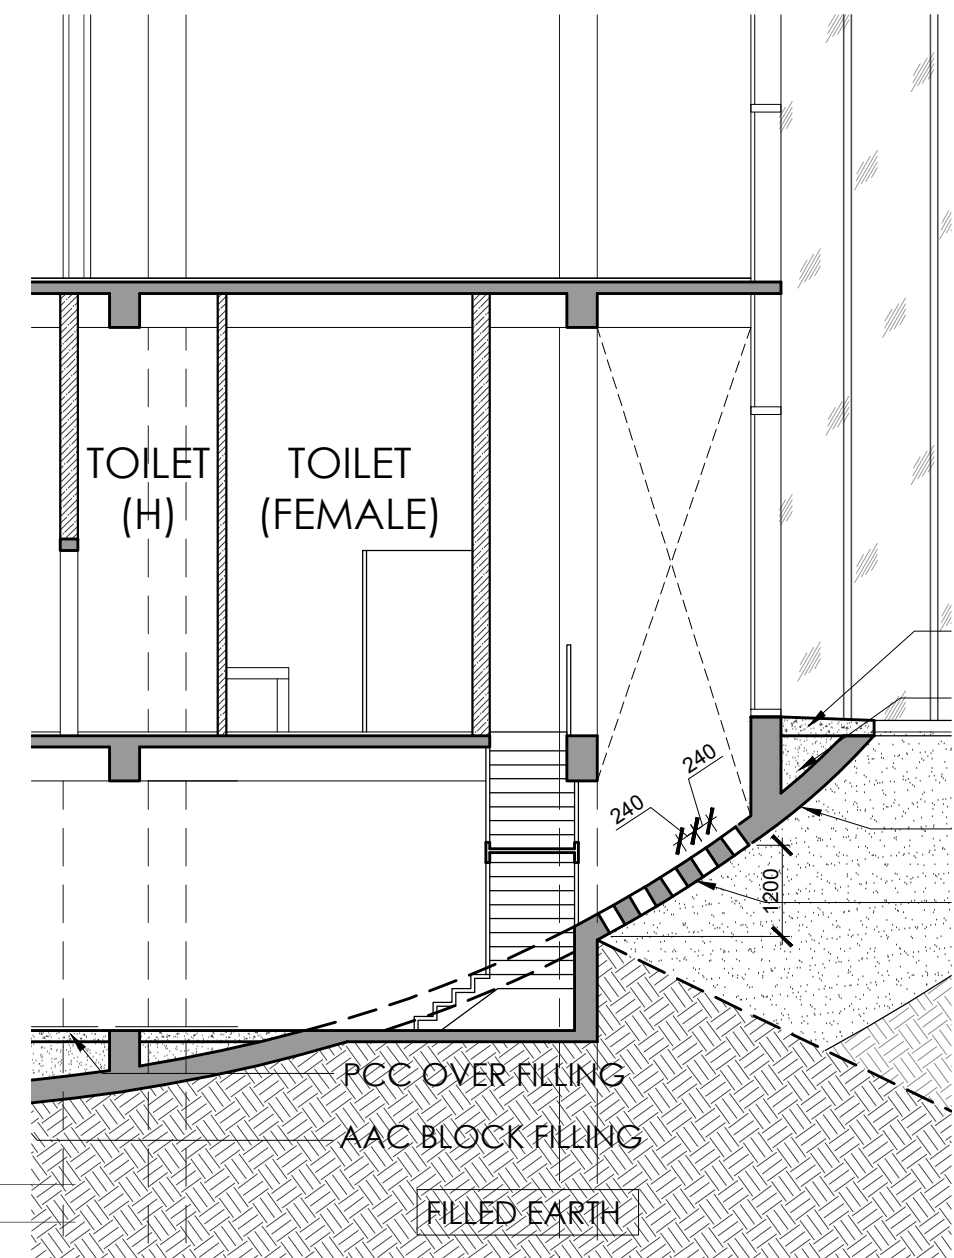

10 DETAIL - 01
SCALE 1:100

- NOTES:
- DO NOT SCALE THE DRAWING. FOLLOW ONLY FIGURED DIMENSIONS.
 - ALL DIMENSIONS GIVEN IN THIS DRAWING ARE IN MILLIMETERS UNLESS NOTED OTHERWISE.
 - ALL DIMENSIONS TO BE VERIFIED ON SITE AND APPROVED BY THE SITE ENGINEER.
 - ANY DISCREPANCY OR AMBIGUITY IN THE DRAWINGS SHOULD IMMEDIATELY BE BROUGHT TO NOTICE OF THE ARCHITECT.
 - ALL DRAWINGS SHOULD BE READ IN CONJUNCTION WITH OTHER RELEVANT ARCHITECTURAL, STRUCTURAL, PLUMBING, MECHANICAL AND ELECTRICAL DRAWINGS.
 - THE ± 0 REFERS TO LEVEL ESTABLISHED AT SITE IN PRESENCE OF THE SITE SUPERVISOR AND THE ARCHITECT. ALL REMAINING LEVELS ARE RELATIVE TO THIS LEVEL.
 - THIS DRAWING IS THE COPYRIGHT OF ARCHOHM CONSULTANTS AND MUST NOT BE RETAINED, COPIED OR USED WITHOUT THEIR AUTHORITY.

REVISIONS			
No.	Date	Descriptions	Revision by

Client:
MEGHALAYAN AGE LIMITED (MAL)

Project:
TRIBAL HERITAGE CENTRE, MANDALGRE, MEGHALAYA

Architects:
ARCHOHM CONSULTANTS
PVT. LTD.
C-286, Sector-45
Rohtak - 141103 (Haryana)
T: 91 120 46 40 300
F: 91 120 42 48 788
mail@archohm.com
www.archohm.com


Structural Consultants:
TPC TECHNICAL PROJECTS CONSULTANTS PVT. LTD.
H-10, B-14, Sector-02, Noida, U.P.
T: 91 120 46 40 300
F: 91 120 42 48 788
mail@tpc-architects.com
www.tpc-architects.com

Electrical Consultants:
ARCHOHM CONSULTANT PVT. LTD.
C-286, Sector-45
Rohtak - 141103 (Haryana)
T: 91 120 46 40 300
F: 91 120 42 48 788
mail@archohm.com
www.archohm.com


MEP Consultants:
WAC Engineers
INDIA PVT. LTD.
PLOT NO. 10, SECTOR-10, PHASE-1
Gurgaon - 122002 (Haryana)
T: 91 120 46 40 300
F: 91 120 42 48 788
mail@wac-engineers.com
www.wac-engineers.com

Drawn By: SJ
Checked By: GK
Design By: SG


Sheet Title: TRIBAL HERITAGE CENTER EXHIBITION & RESEARCH CENTER SECTIONS (SHEET 02 OF 03)	Scale: 1:200	Project No.: A-232409
Date: 30-08-2024	Drawing No.: A-232409-B1-02-02	A1 R0

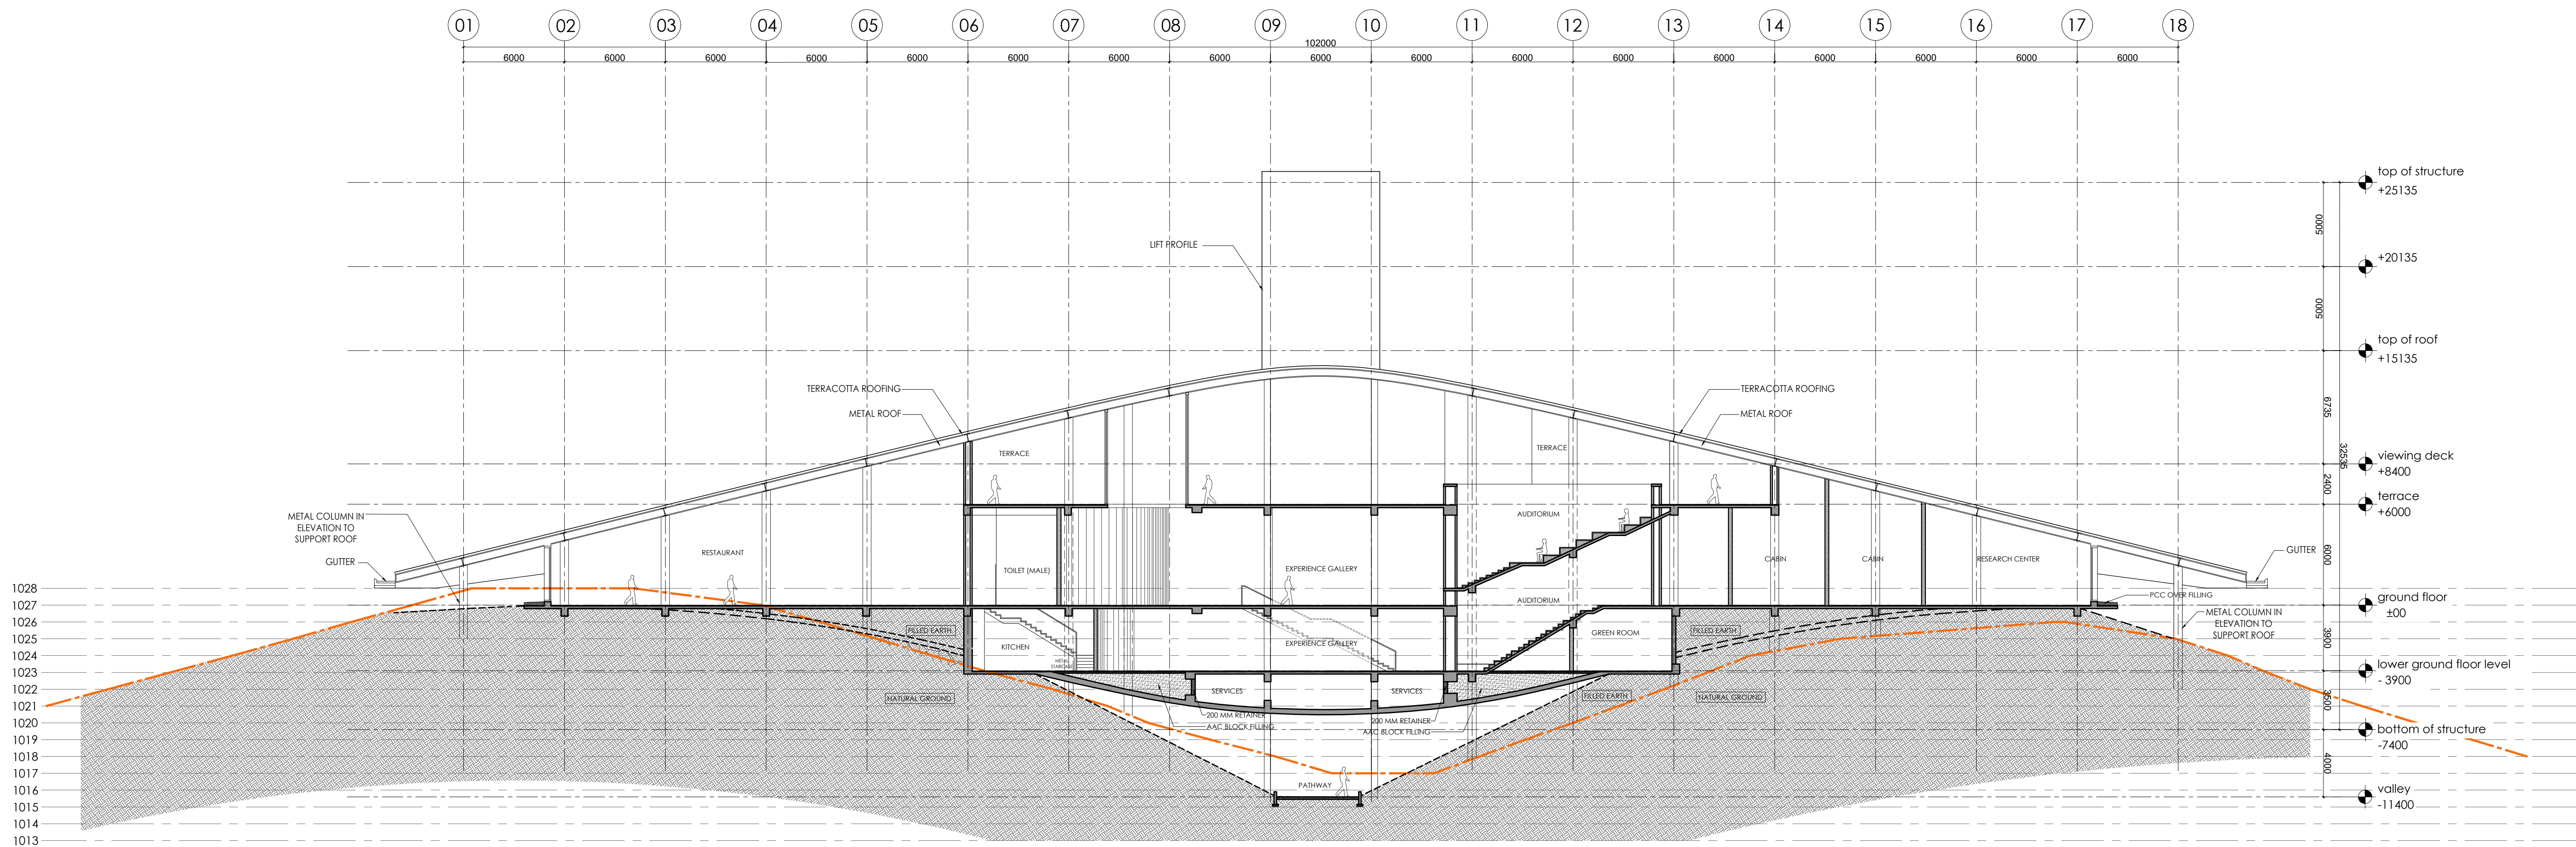

06 SECTION - 01
SCALE 1:200

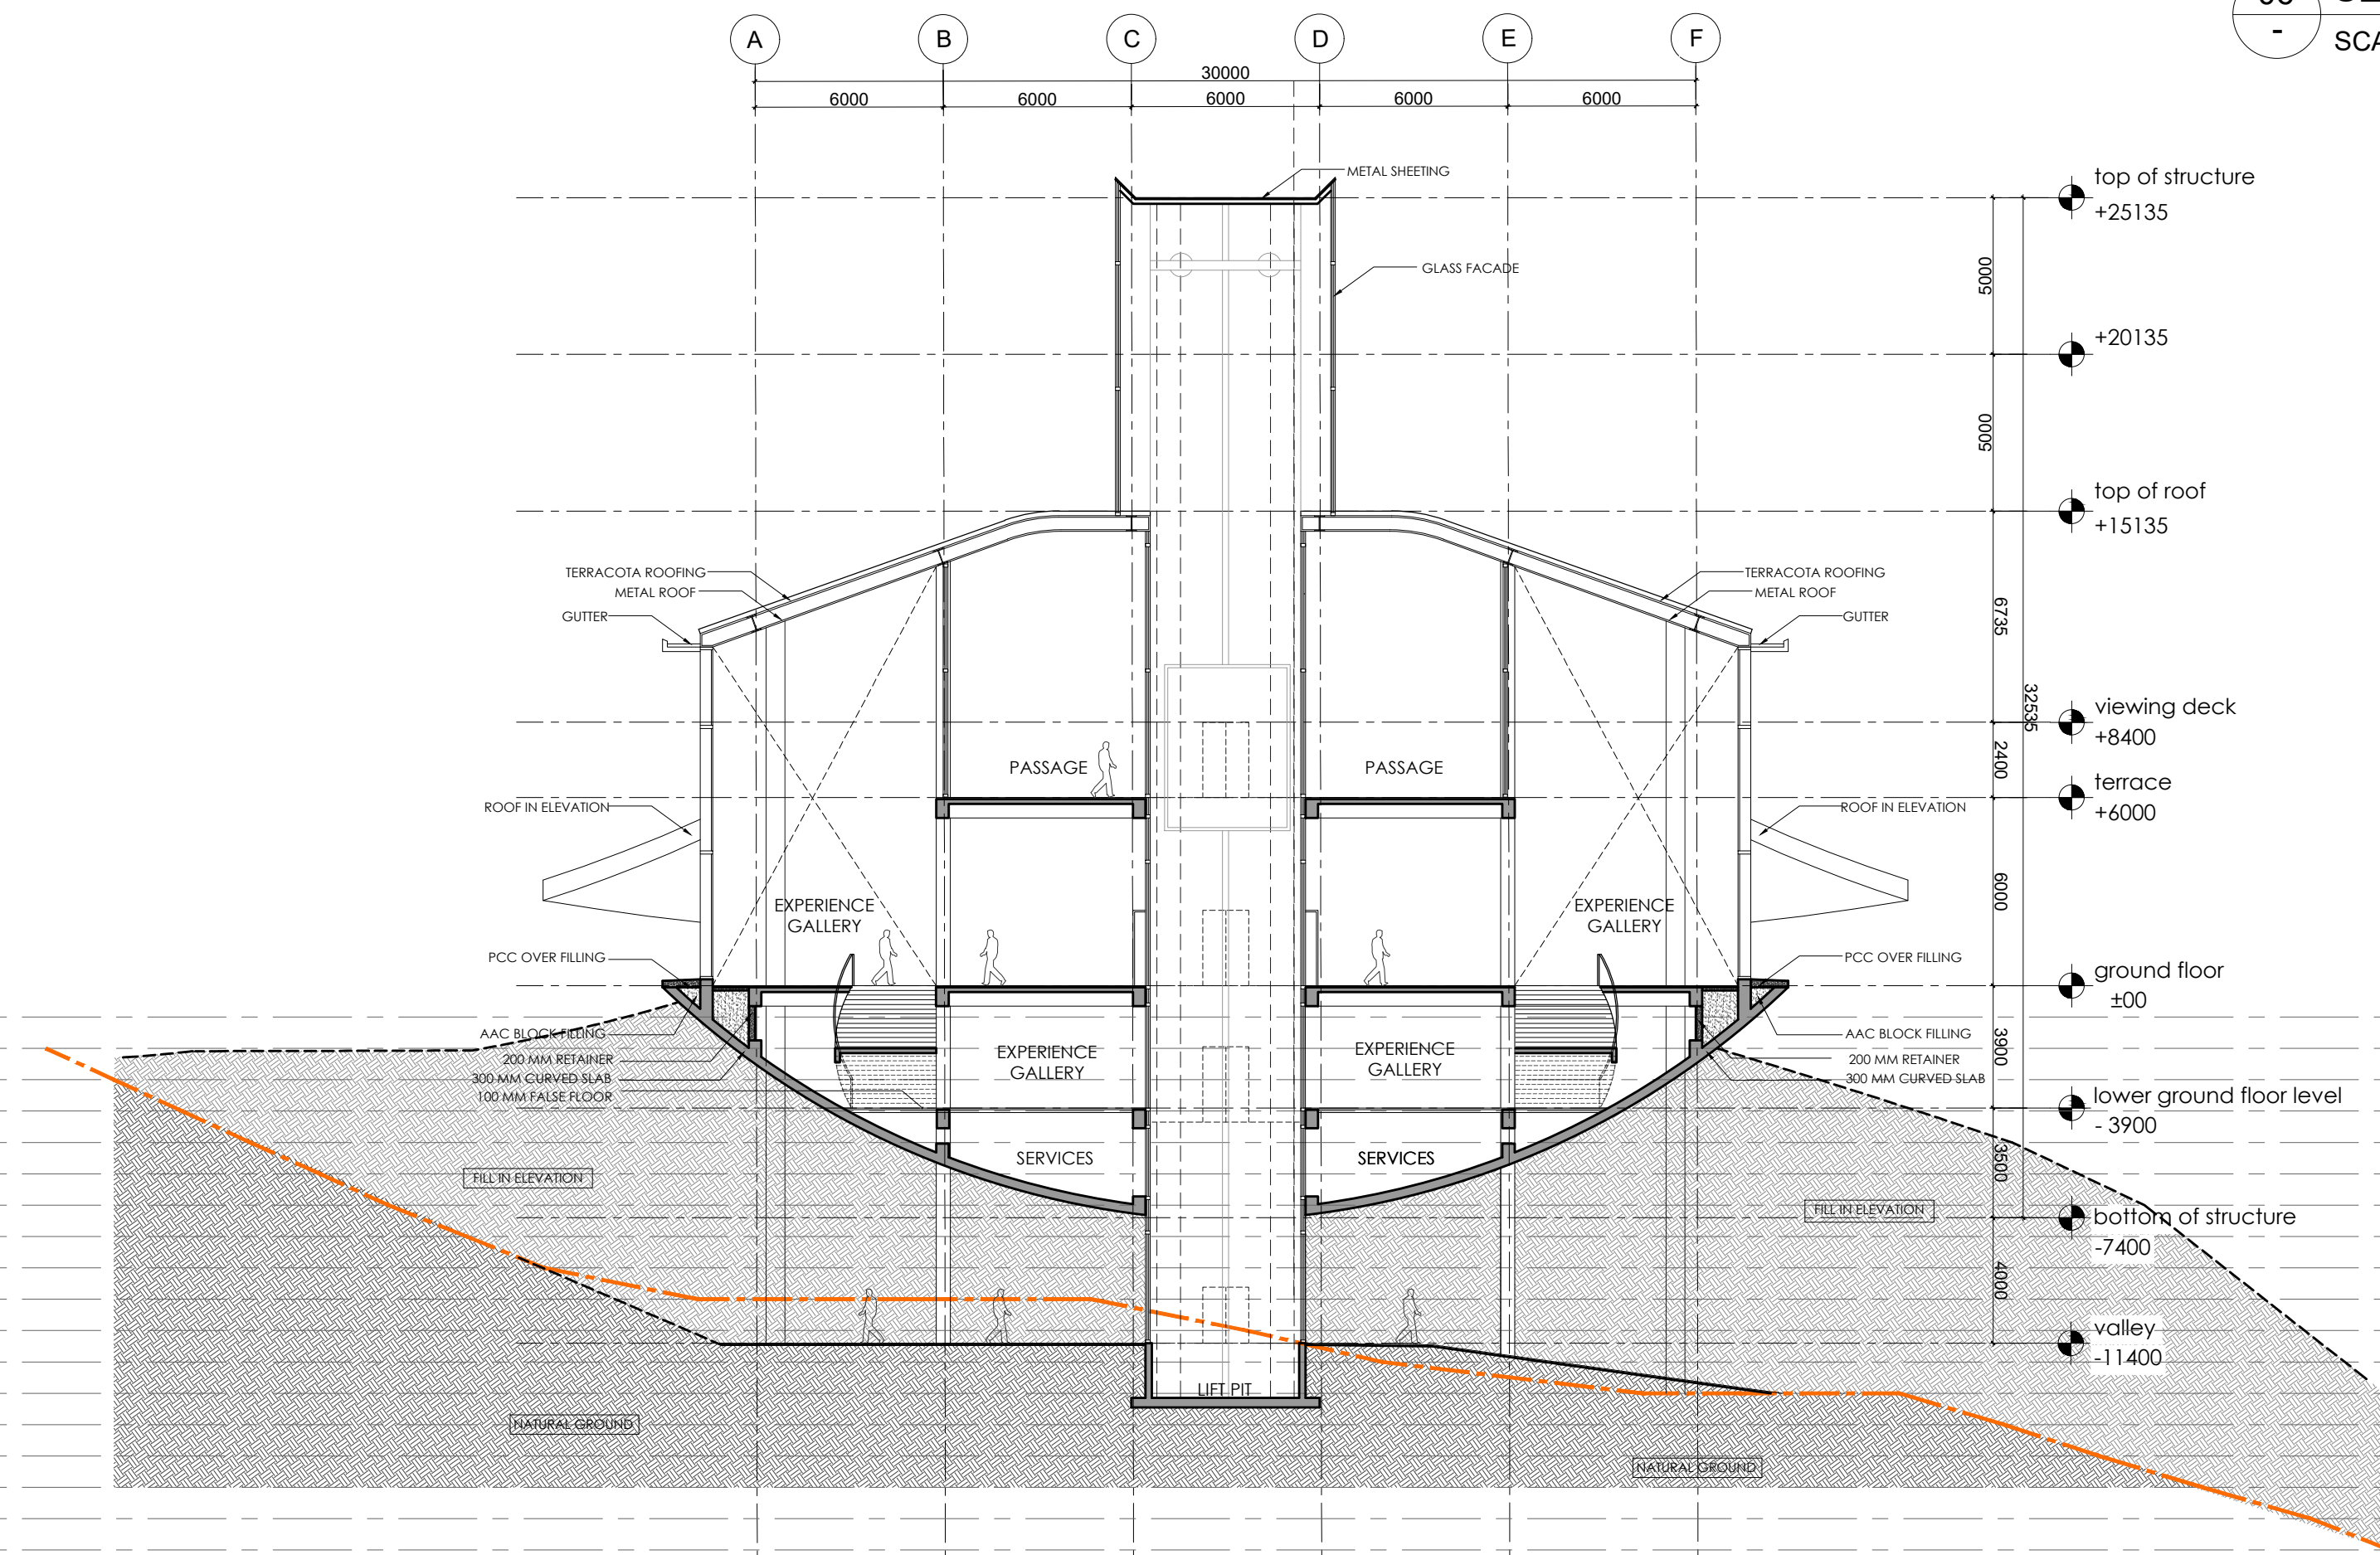

11 SECTION - 06
SCALE 1:200

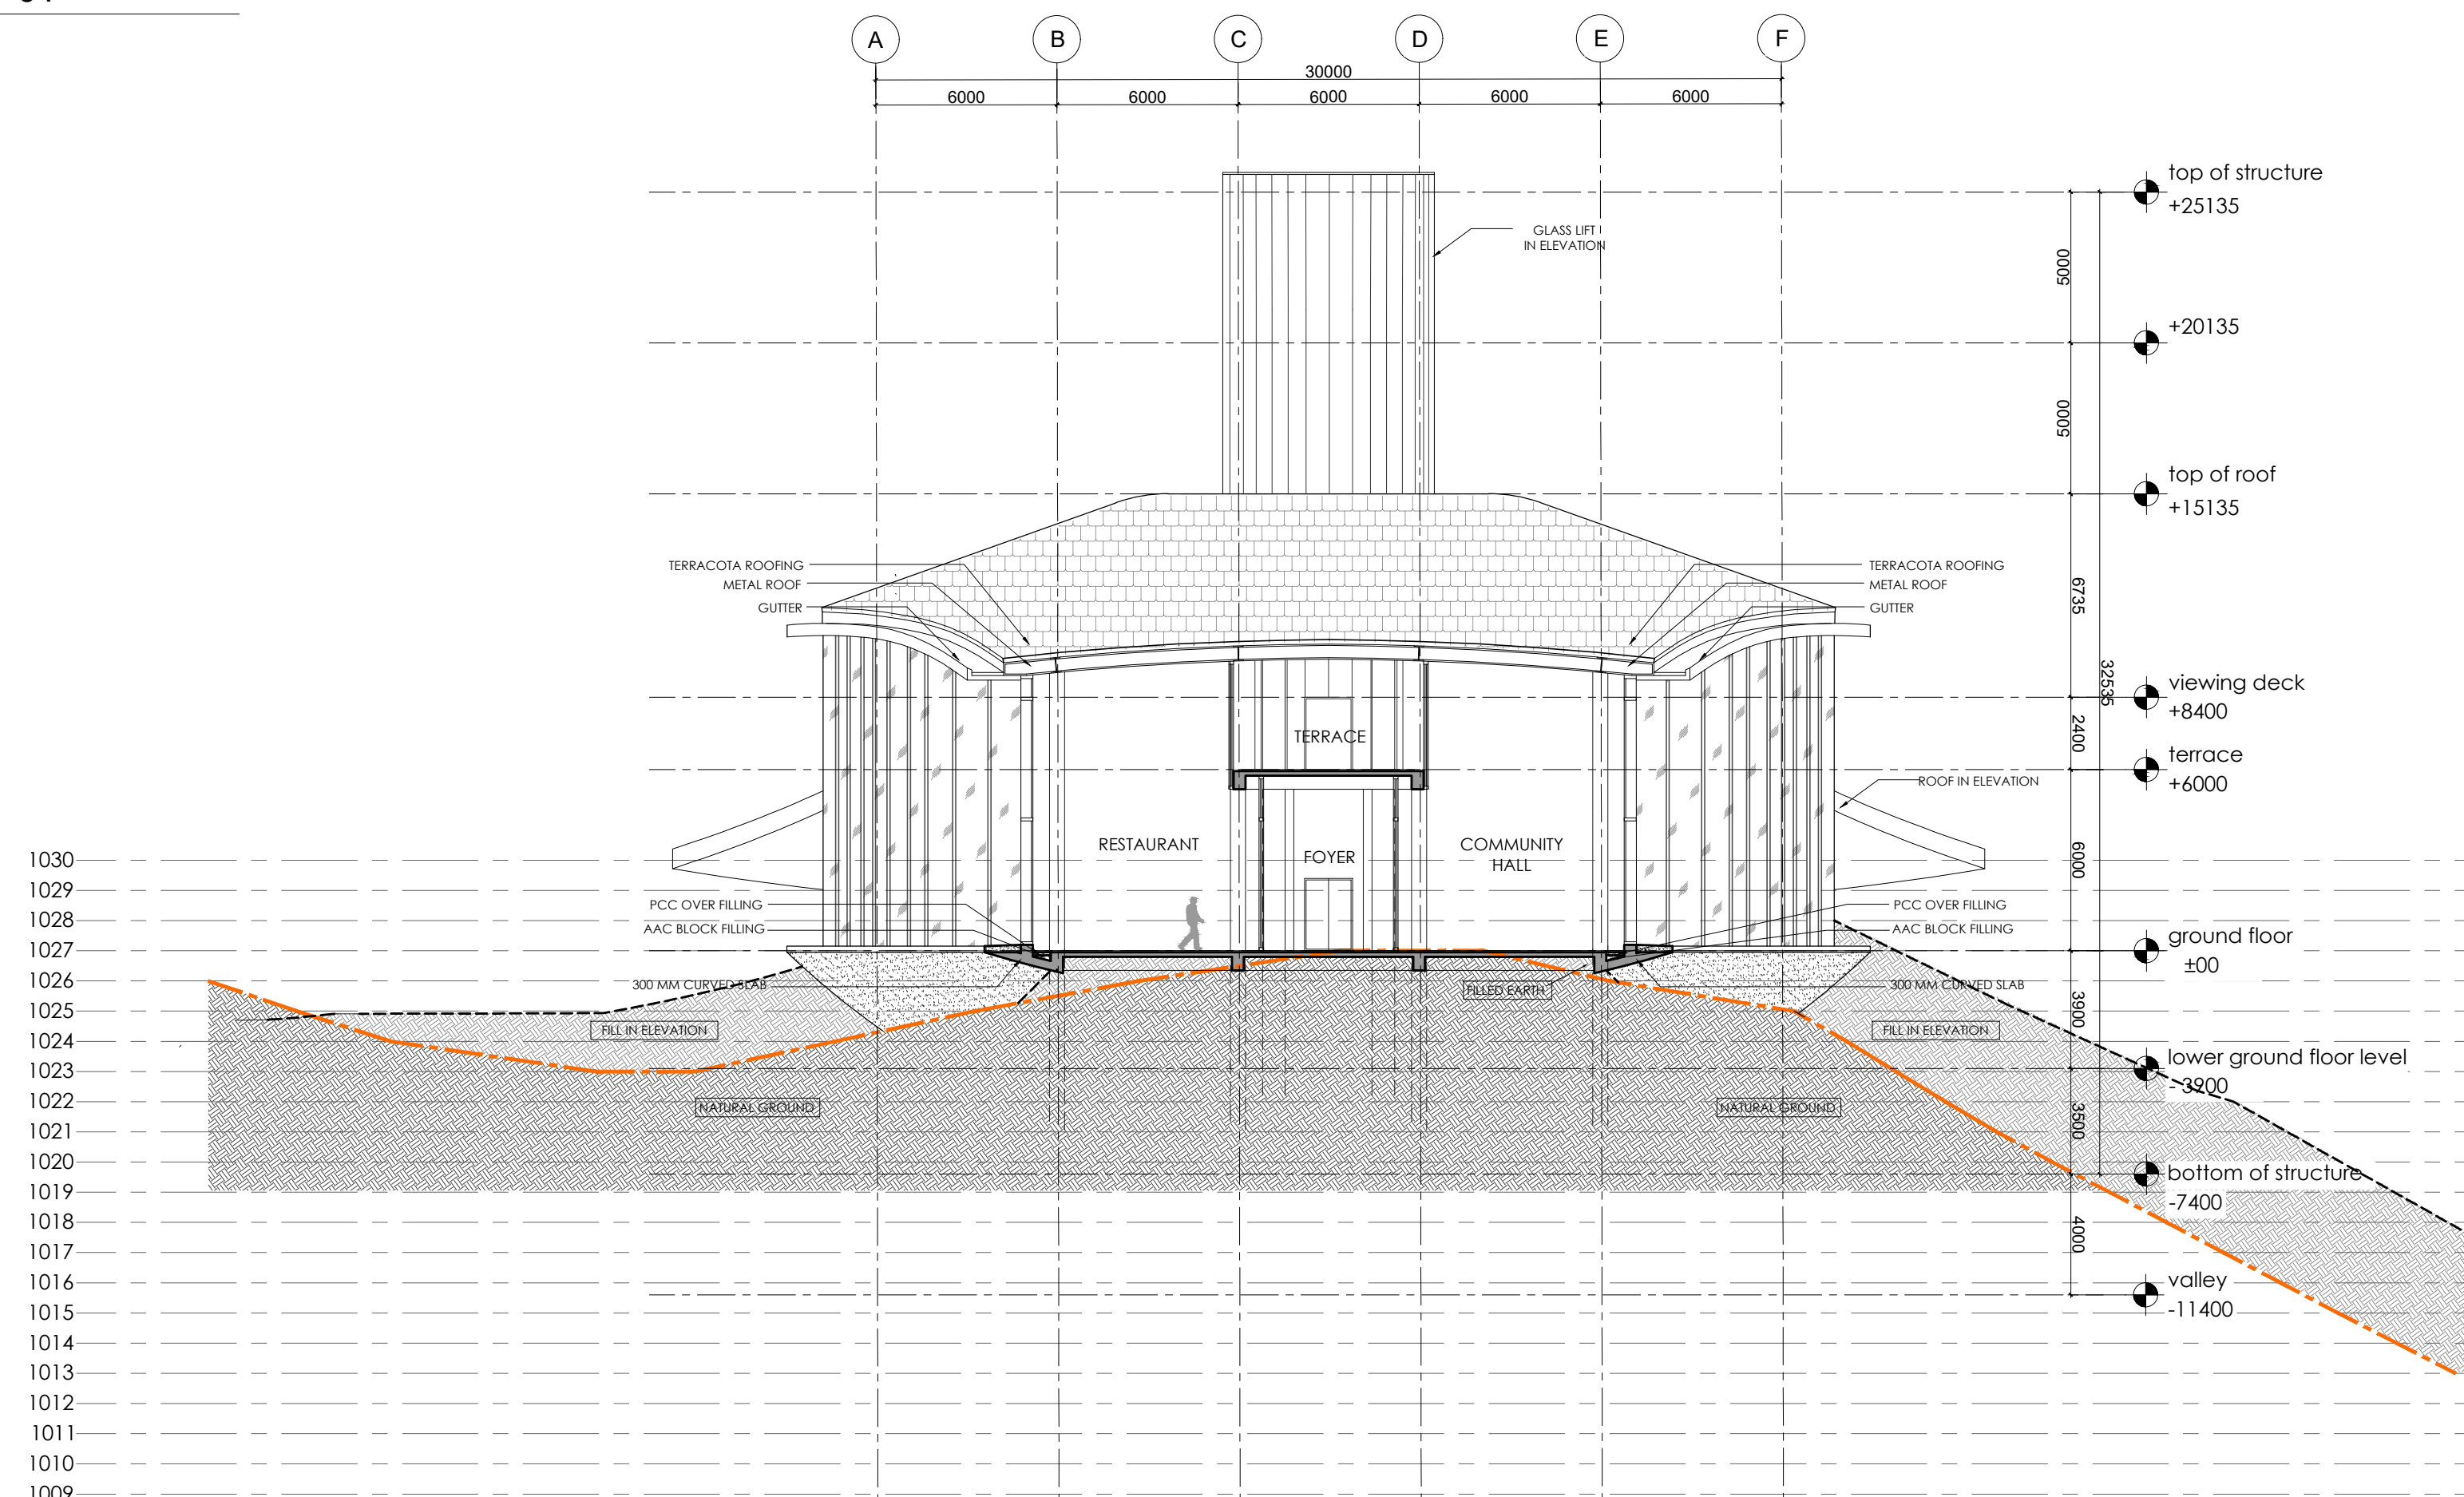

09 SECTION - 04
SCALE 1:200

NOTES:

- DO NOT SCALE THE DRAWING. FOLLOW ONLY FIGURED DIMENSIONS.
- ALL DIMENSIONS GIVEN IN THIS DRAWING ARE IN MILLIMETERS UNLESS NOTED OTHERWISE.
- ALL DIMENSIONS TO BE VERIFIED ON SITE AND APPROVED BY THE SITE ENGINEER.
- ANY DISCREPANCY OR AMBIGUITY IN THE DRAWINGS SHOULD IMMEDIATELY BE BROUGHT TO NOTICE OF THE ARCHITECT.
- ALL DRAWINGS SHOULD BE READ IN CONJUNCTION WITH OTHER RELEVANT ARCHITECTURAL, STRUCTURAL, PLUMBING, MECHANICAL AND ELECTRICAL DRAWINGS.
- THE ± 0 REFERS TO LEVEL ESTABLISHED AT SITE IN PRESENCE OF THE SITE SUPERVISOR AND THE ARCHITECT. ALL REMAINING LEVELS ARE RELATIVE TO THIS LEVEL.
- THIS DRAWING IS THE COPYRIGHT OF ARCHOHM CONSULTANTS AND MUST NOT BE RETAINED, COPIED OR USED WITHOUT THEIR AUTHORITY.

REVISIONS

No.	Date	Descriptions	Revision by

Client:

MEGHALAYAN AGE LIMITED (MAL)

Project:

TRIBAL HERITAGE CENTRE, MANDALGRE, MEGHALAYA

Architects:



Structural Consultants:



Electrical Consultants:



Mechanical Consultants:



Drawn By:

SJ

Checked By:

GK

Design By:

SG

Sheet Title:

TRIBAL HERITAGE CENTER EXHIBITION & RESEARCH CENTER SECTIONS (SHEET 01 OF 03)

Date: 30-08-2024





Scale: 1:200

Project No: A-232409


Drawing No: A-232409-B1-02-01

A1


R0

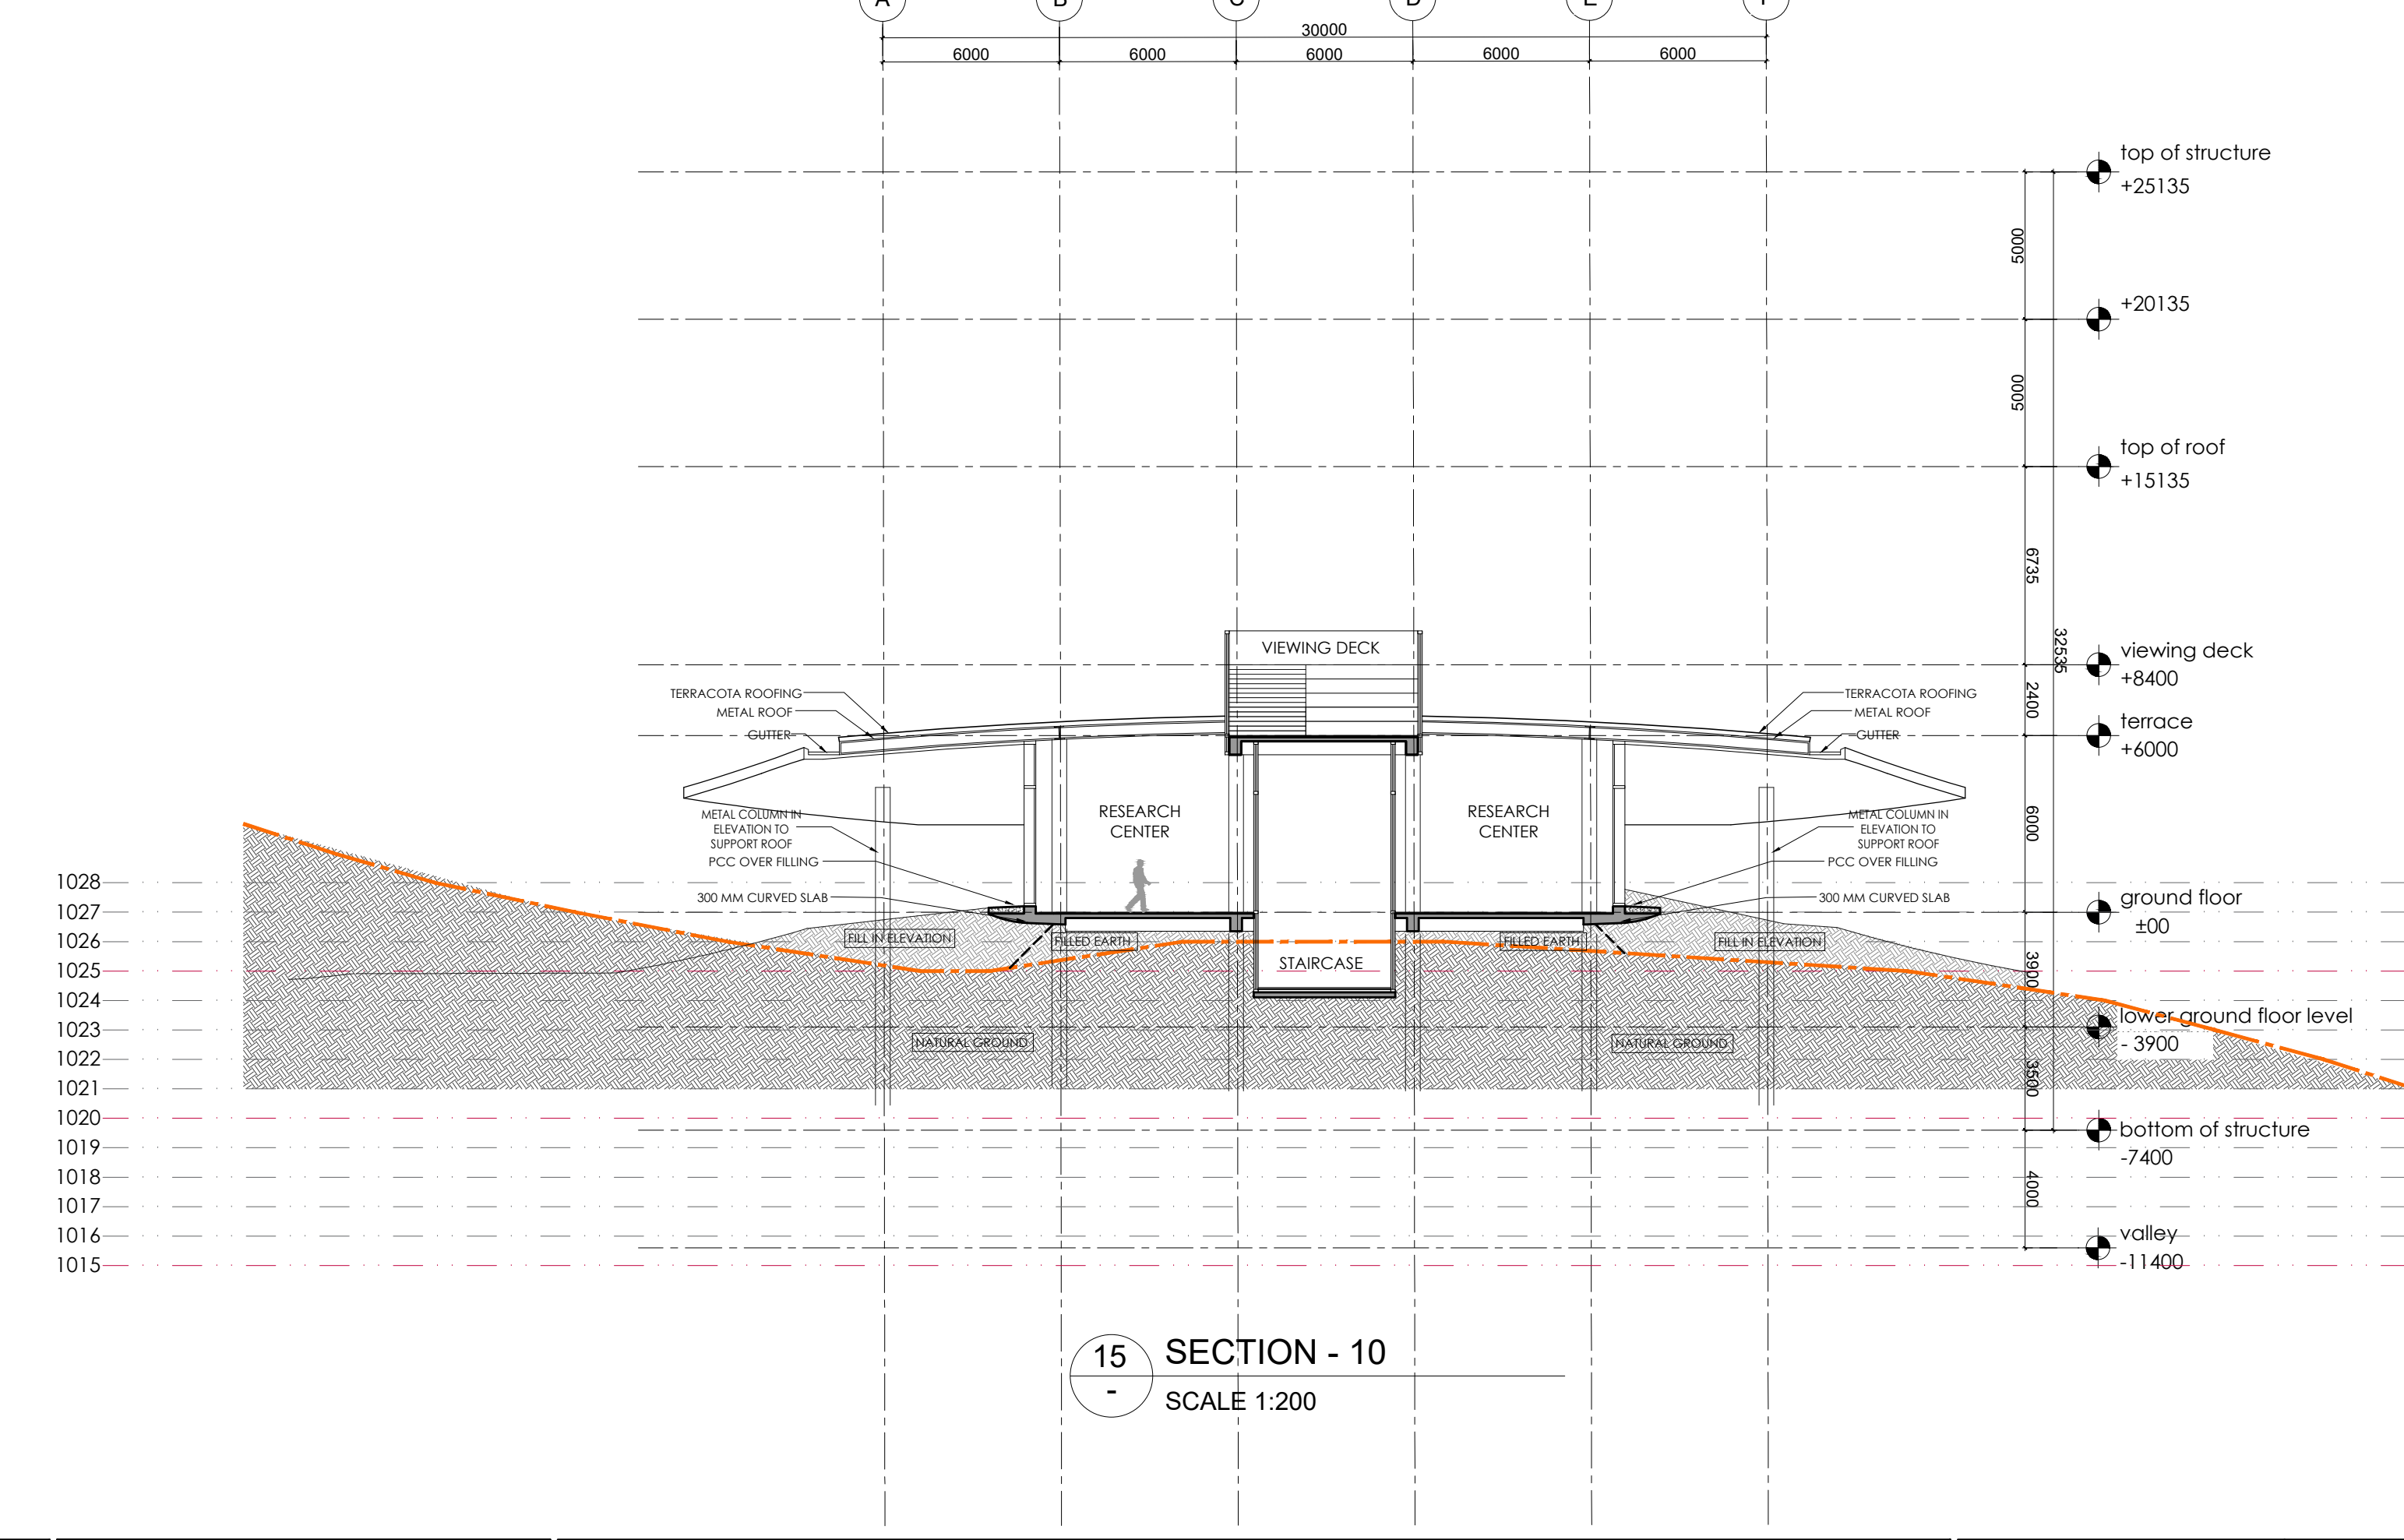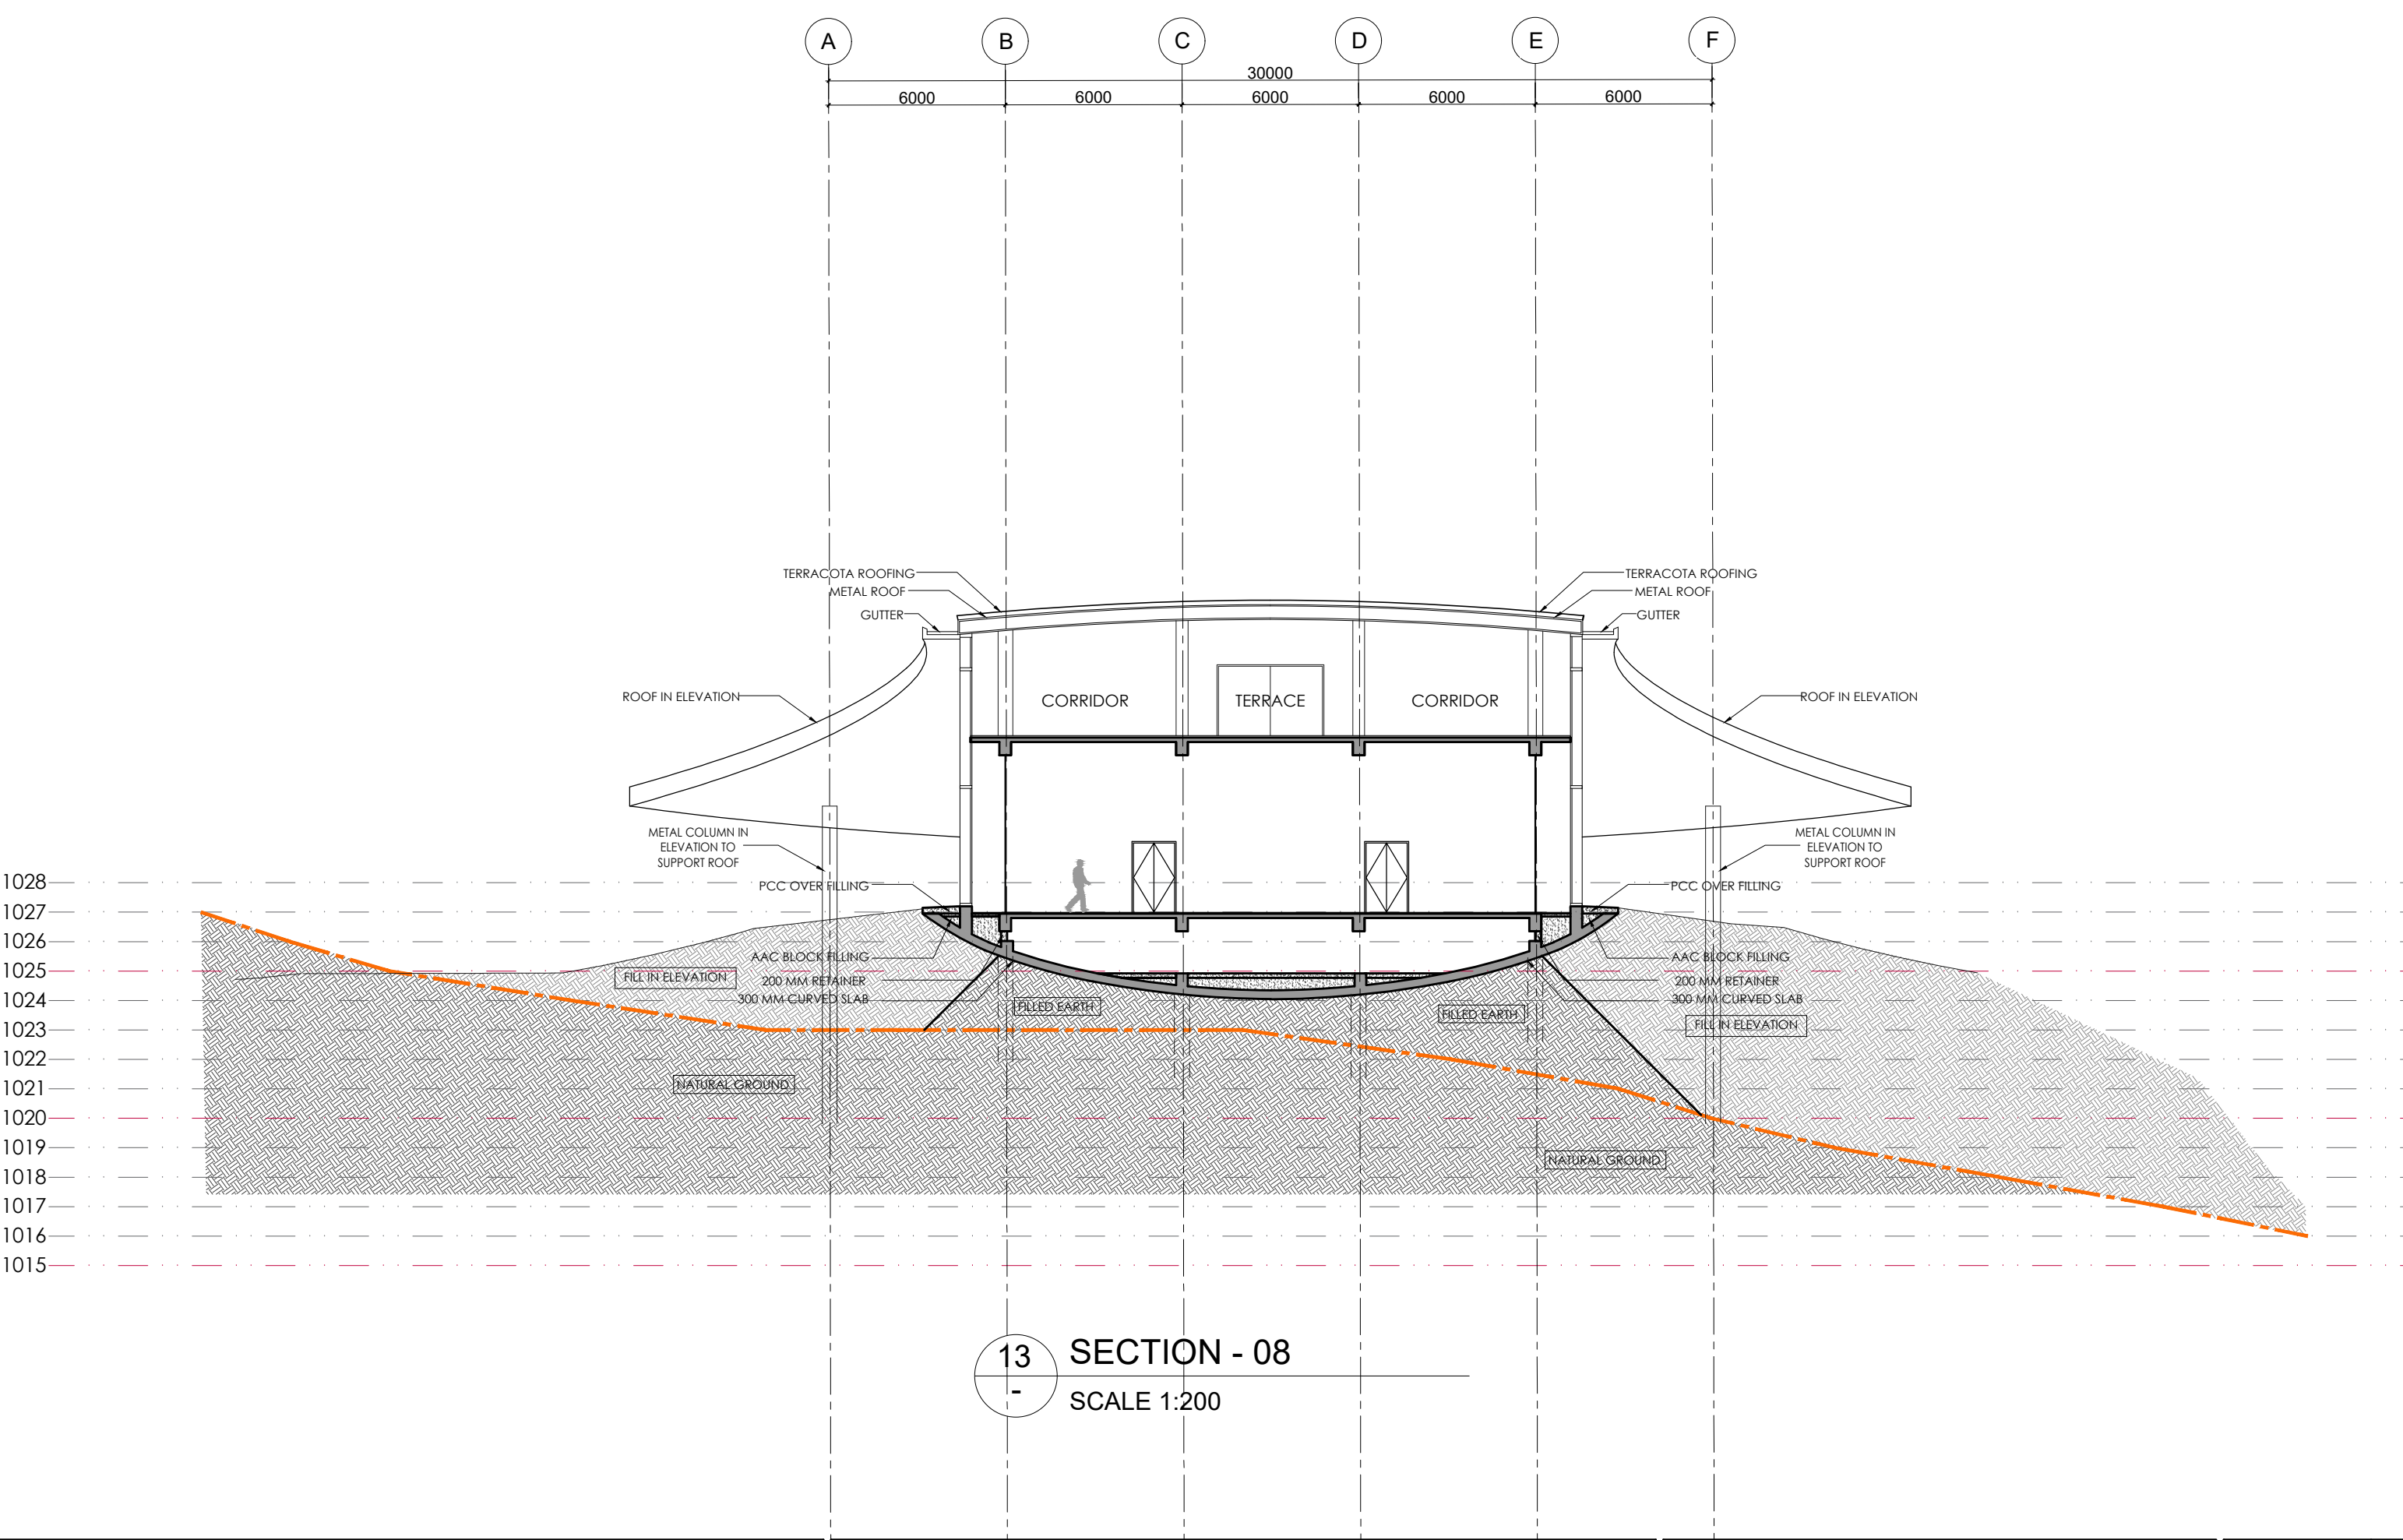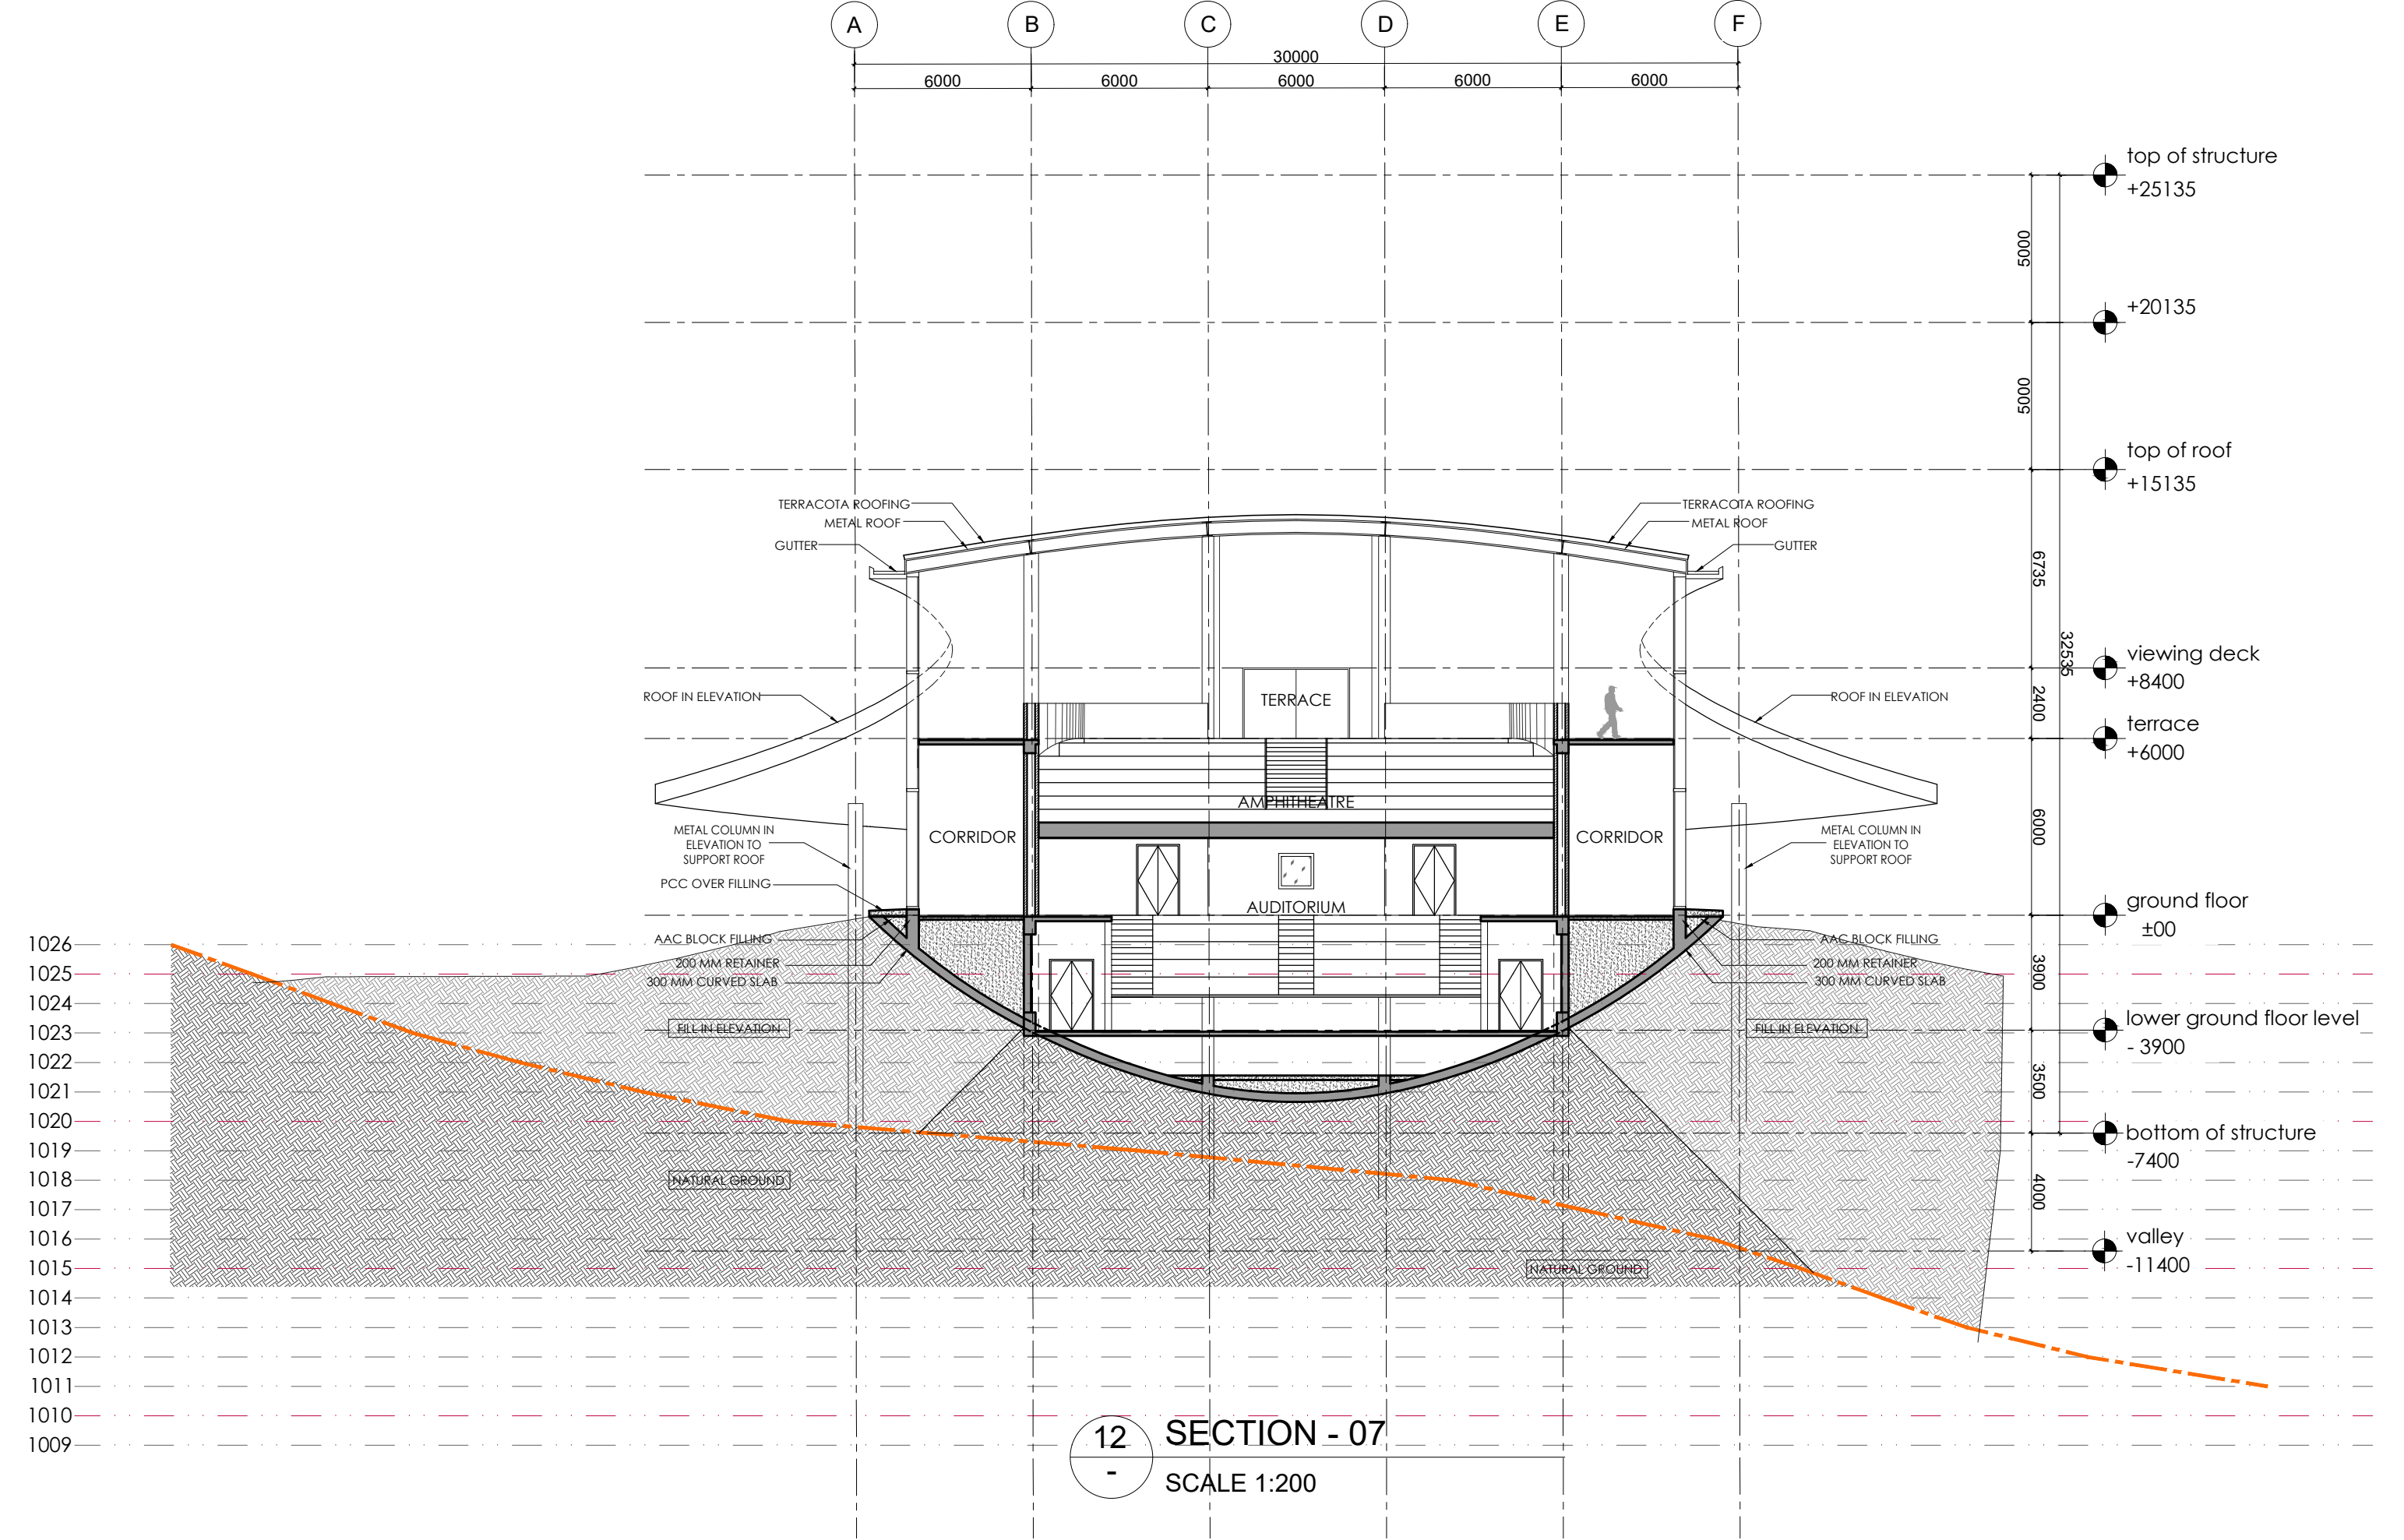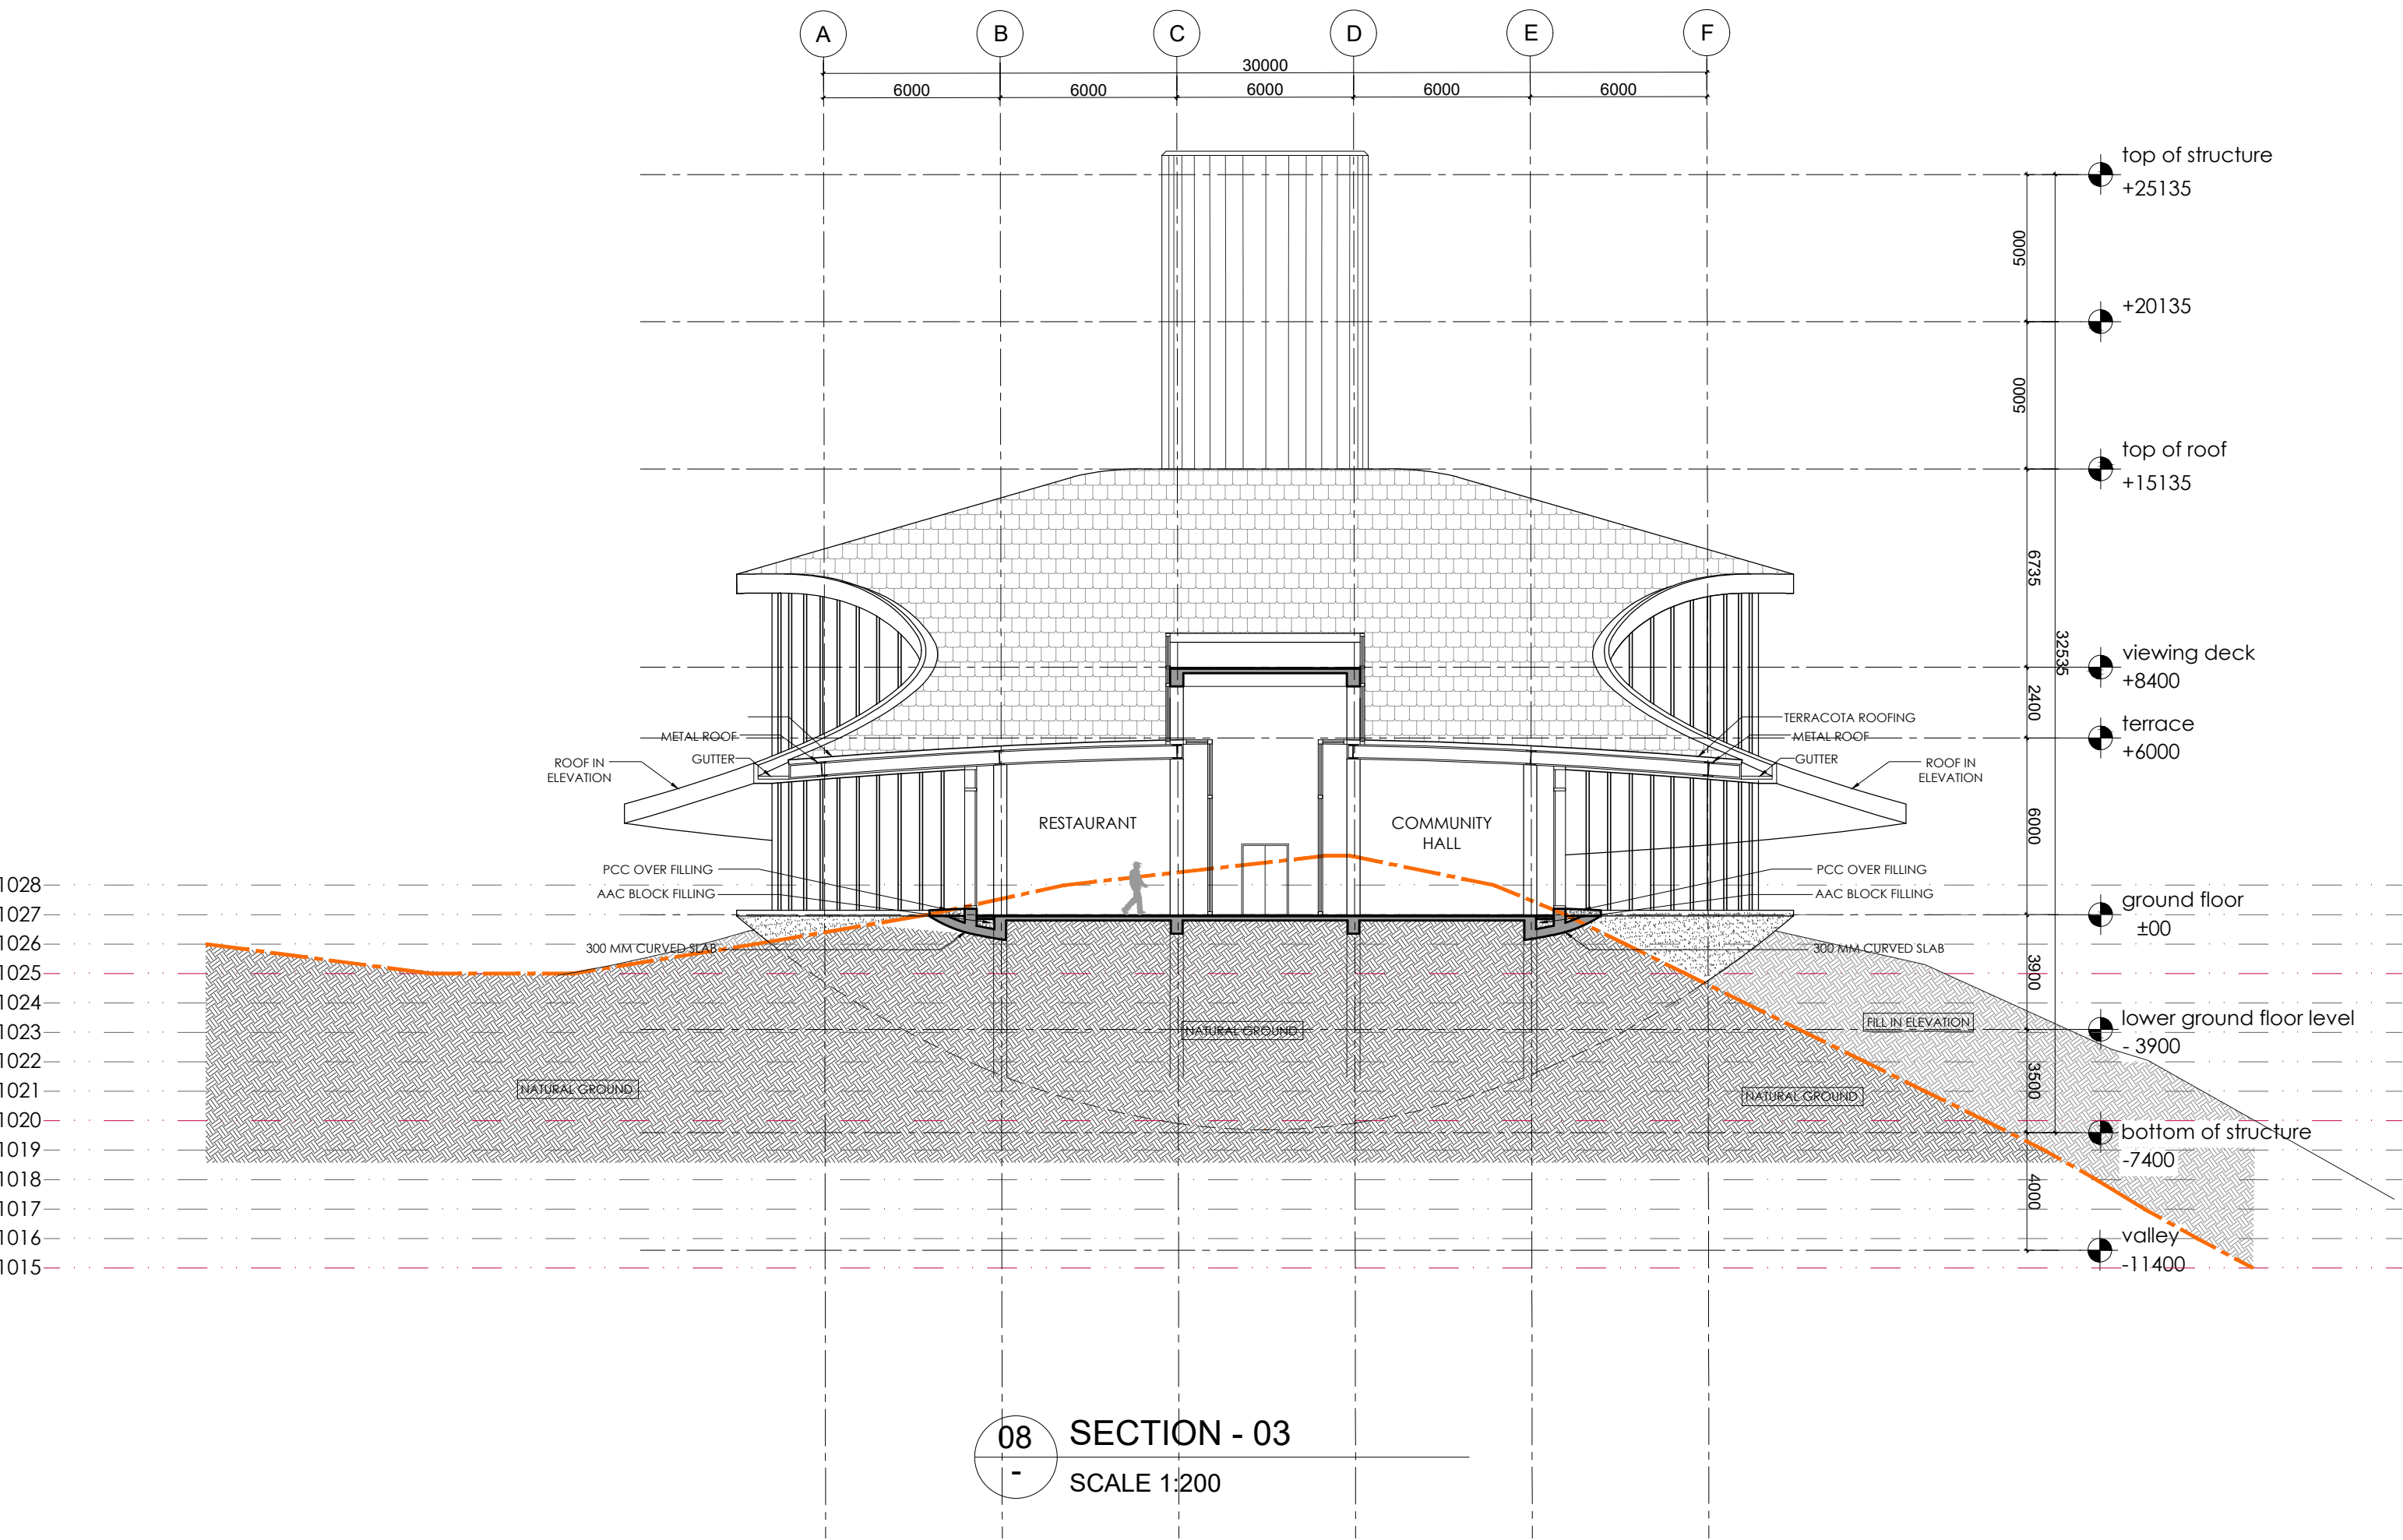

NOTES:								Client:		Project:		Architects:		Structural Consultants:		Electrical Consultants:		M&E Consultants:		Drawn By:		Checked By:		Design By:		Sheet Title:		Project No.:		Drawing No.:		A1		R0	
1. DO NOT SCALE THE DRAWING. FOLLOW ONLY FIGURED DIMENSIONS.								MEGHALAYAN AGE LIMITED (MAL)		TRIBAL HERITAGE CENTRE, MANDALGRE, MEGHALAYA		ARCHOHM CONSULTANTS PVT. LTD.		TPC TECHNICAL PROJECTS CONSULTANTS PVT. LTD.		ARCHOHM CONSULTANT PVT. LTD.		WAC Engineers INDIA PVT. LTD.		SJ		GK		SG		TRIBAL HERITAGE CENTER EXHIBITION & RESEARCH CENTER SECTIONS (SHEET 03 OF 03)		A-232409		A-232409-B1-02-03					
2. ALL DIMENSIONS GIVEN IN THIS DRAWING ARE IN MILLIMETERS UNLESS NOTED OTHERWISE.												c-295, sector-8, noida - 201301 (up)		c-295, sector-8, noida - 201301 (up)		c-295, sector-8, noida - 201301 (up)		c-295, sector-8, noida - 201301 (up)																	
3. ALL DIMENSIONS TO BE VERIFIED ON SITE AND APPROVED BY THE SITE ENGINEER.												p 110 46 40 300		p 110 46 40 300		p 110 46 40 300		p 110 46 40 300																	
4. ANY DISCREPANCY OR AMBIGUITY IN THE DRAWINGS SHOULD IMMEDIATELY BE BROUGHT TO NOTICE OF THE ARCHITECT.												f 91 120 42 48 788		f 91 120 42 48 788		f 91 120 42 48 788		f 91 120 42 48 788																	
5. ALL DRAWINGS SHOULD BE READ IN CONJUNCTION WITH OTHER RELEVANT ARCHITECTURAL, STRUCTURAL, PLUMBING, MECHANICAL AND ELECTRICAL DRAWINGS.												mail@archohm.com		mail@tpcprojects.com		mail@archohm.com		mail@wacindia.com																	
6. THE ± 0 REFERS TO LEVEL ESTABLISHED AT SITE IN PRESENCE OF THE SITE SUPERVISOR AND THE ARCHITECT. ALL REMAINING LEVELS ARE RELATIVE TO THIS LEVEL.												www.archohm.com		www.tpcprojects.com		www.archohm.com		www.wacindia.com																	
7. THIS DRAWING IS THE COPYRIGHT OF ARCHOHM CONSULTANTS AND MUST NOT BE RETAINED, COPIED OR USED WITHOUT THEIR AUTHORITY.																																			

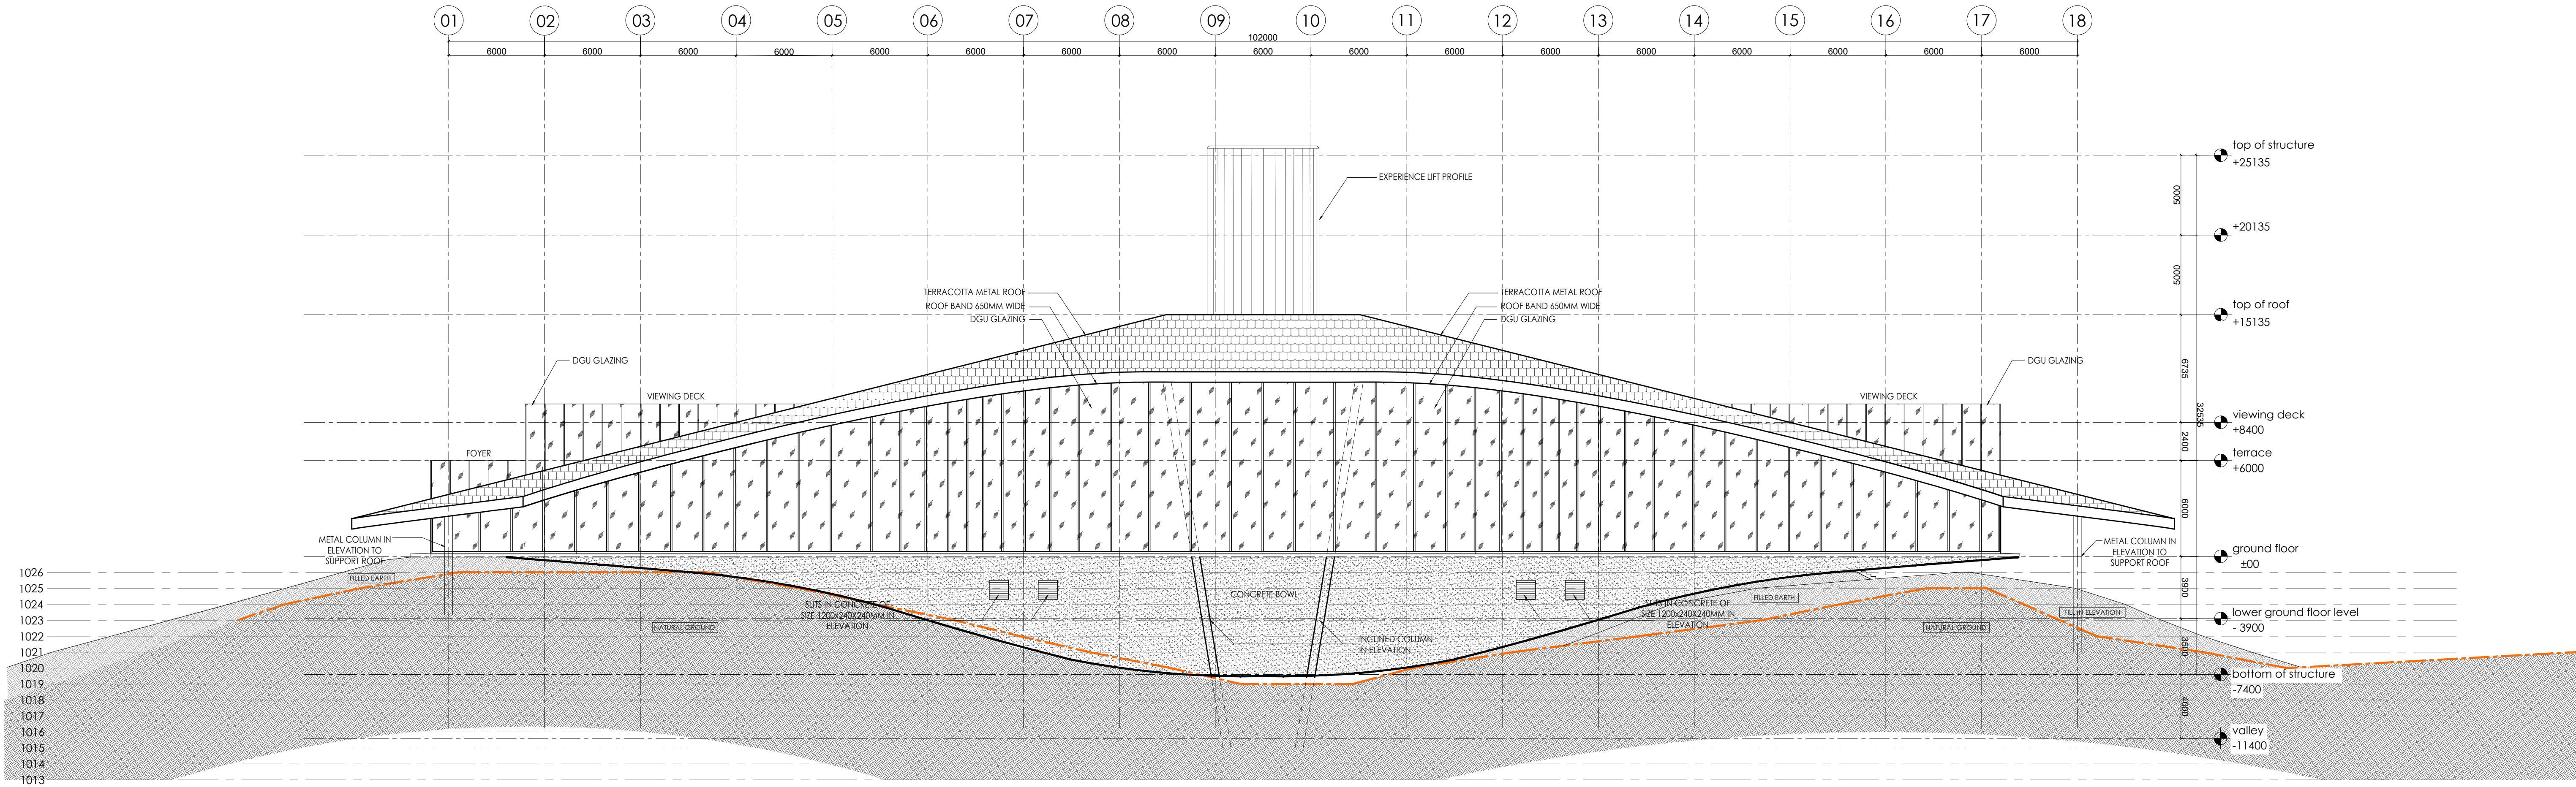

16 SIDE ELEVATION
SCALE 1:200

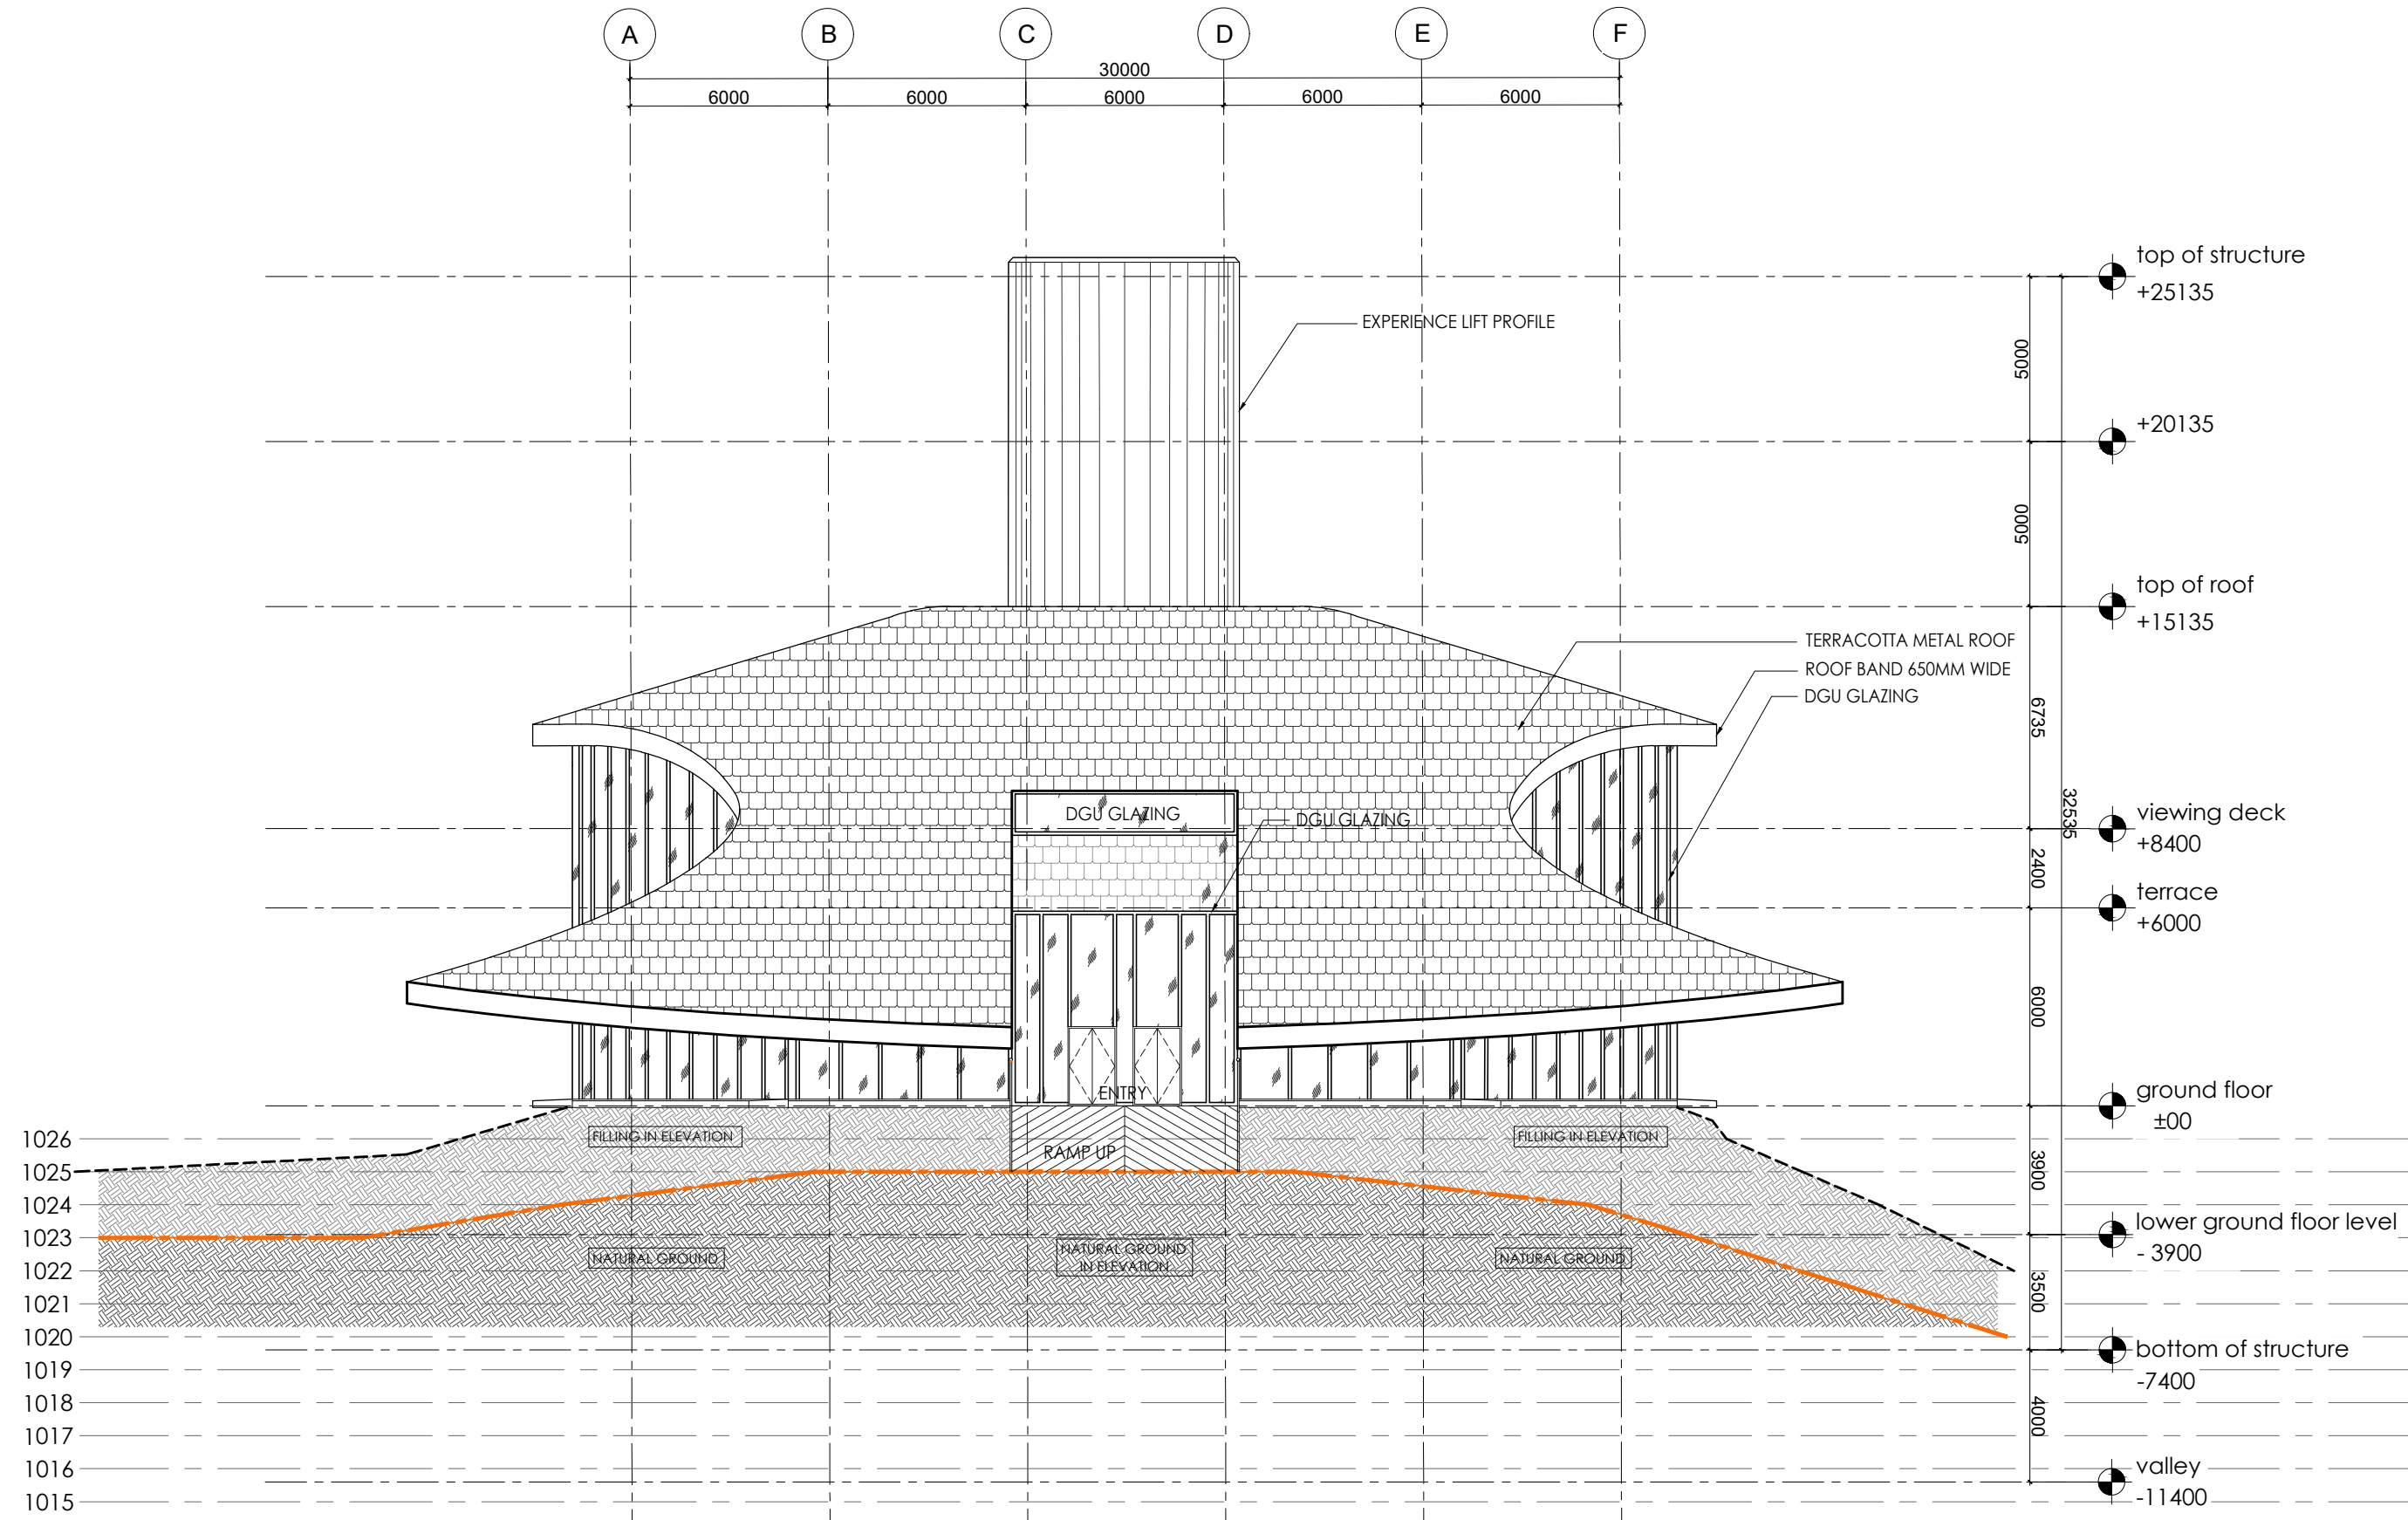

17 FRONT ELEVATION
SCALE 1:200

NOTES:

- DO NOT SCALE THE DRAWING. FOLLOW ONLY FIGURED DIMENSIONS.
- ALL DIMENSIONS GIVEN IN THIS DRAWING ARE IN MILLIMETERS UNLESS NOTED OTHERWISE.
- ALL DIMENSIONS TO BE VERIFIED ON SITE AND APPROVED BY THE SITE ENGINEER.
- ANY DISCREPANCY OR AMBIGUITY IN THE DRAWINGS SHOULD IMMEDIATELY BE BROUGHT TO NOTICE OF THE ARCHITECT.
- ALL DRAWINGS SHOULD BE READ IN CONJUNCTION WITH OTHER RELEVANT ARCHITECTURAL, STRUCTURAL, PLUMBING, MECHANICAL AND ELECTRICAL DRAWINGS.
- THE ± 0 REFERS TO LEVEL ESTABLISHED AT SITE IN PRESENCE OF THE SITE SUPERVISOR AND THE ARCHITECT. ALL REMAINING LEVELS ARE RELATIVE TO THIS LEVEL.
- THIS DRAWING IS THE COPYRIGHT OF ARCHOHM CONSULTANTS AND MUST NOT BE RETAINED, COPIED OR USED WITHOUT THEIR AUTHORITY.

REVISIONS

No.	Date	Descriptions	Revision by

Client:

MEGHALAYAN AGE LIMITED (MAL)

Project:

TRIBAL HERITAGE CENTRE, MANDALGRE, MEGHALAYA

Architects:



Structural Consultants:

TPC TECHNICAL PROJECTS CONSULTANTS PVT. LTD.
10/10, B-14, Sector 02, Noida, U.P.
110 028
T: 91 120 46 40 300
F: 91 120 42 46 788
mail@tpctechnical.com
www.tpctechnical.com

Electrical Consultants:

ARCHOHM CONSULTANT PVT. LTD.
10/10, B-14, Sector 02, Noida, U.P.
110 028
T: 91 120 46 40 300
F: 91 120 42 46 788
mail@archohm.com
www.archohm.com

M/E Consultants:

WAC Engineers INDIA PVT. LTD.
MEP Consultants & Project Managers
P: 011-26464646
F: 011-26464646
E: wac@wacindia.com

Drawn By:

SJ

Checked By:

GK

Design By:

SG

Sheet Title:

TRIBAL HERITAGE CENTRE
EXHIBITION & RESEARCH CENTER
ELEVATIONS

Date:

30-08-2024

Drawing No.:

A-232409-B1-03-01

Scale:


1:200

Project No.:


A-232409

Sheet No.:


A1 R0

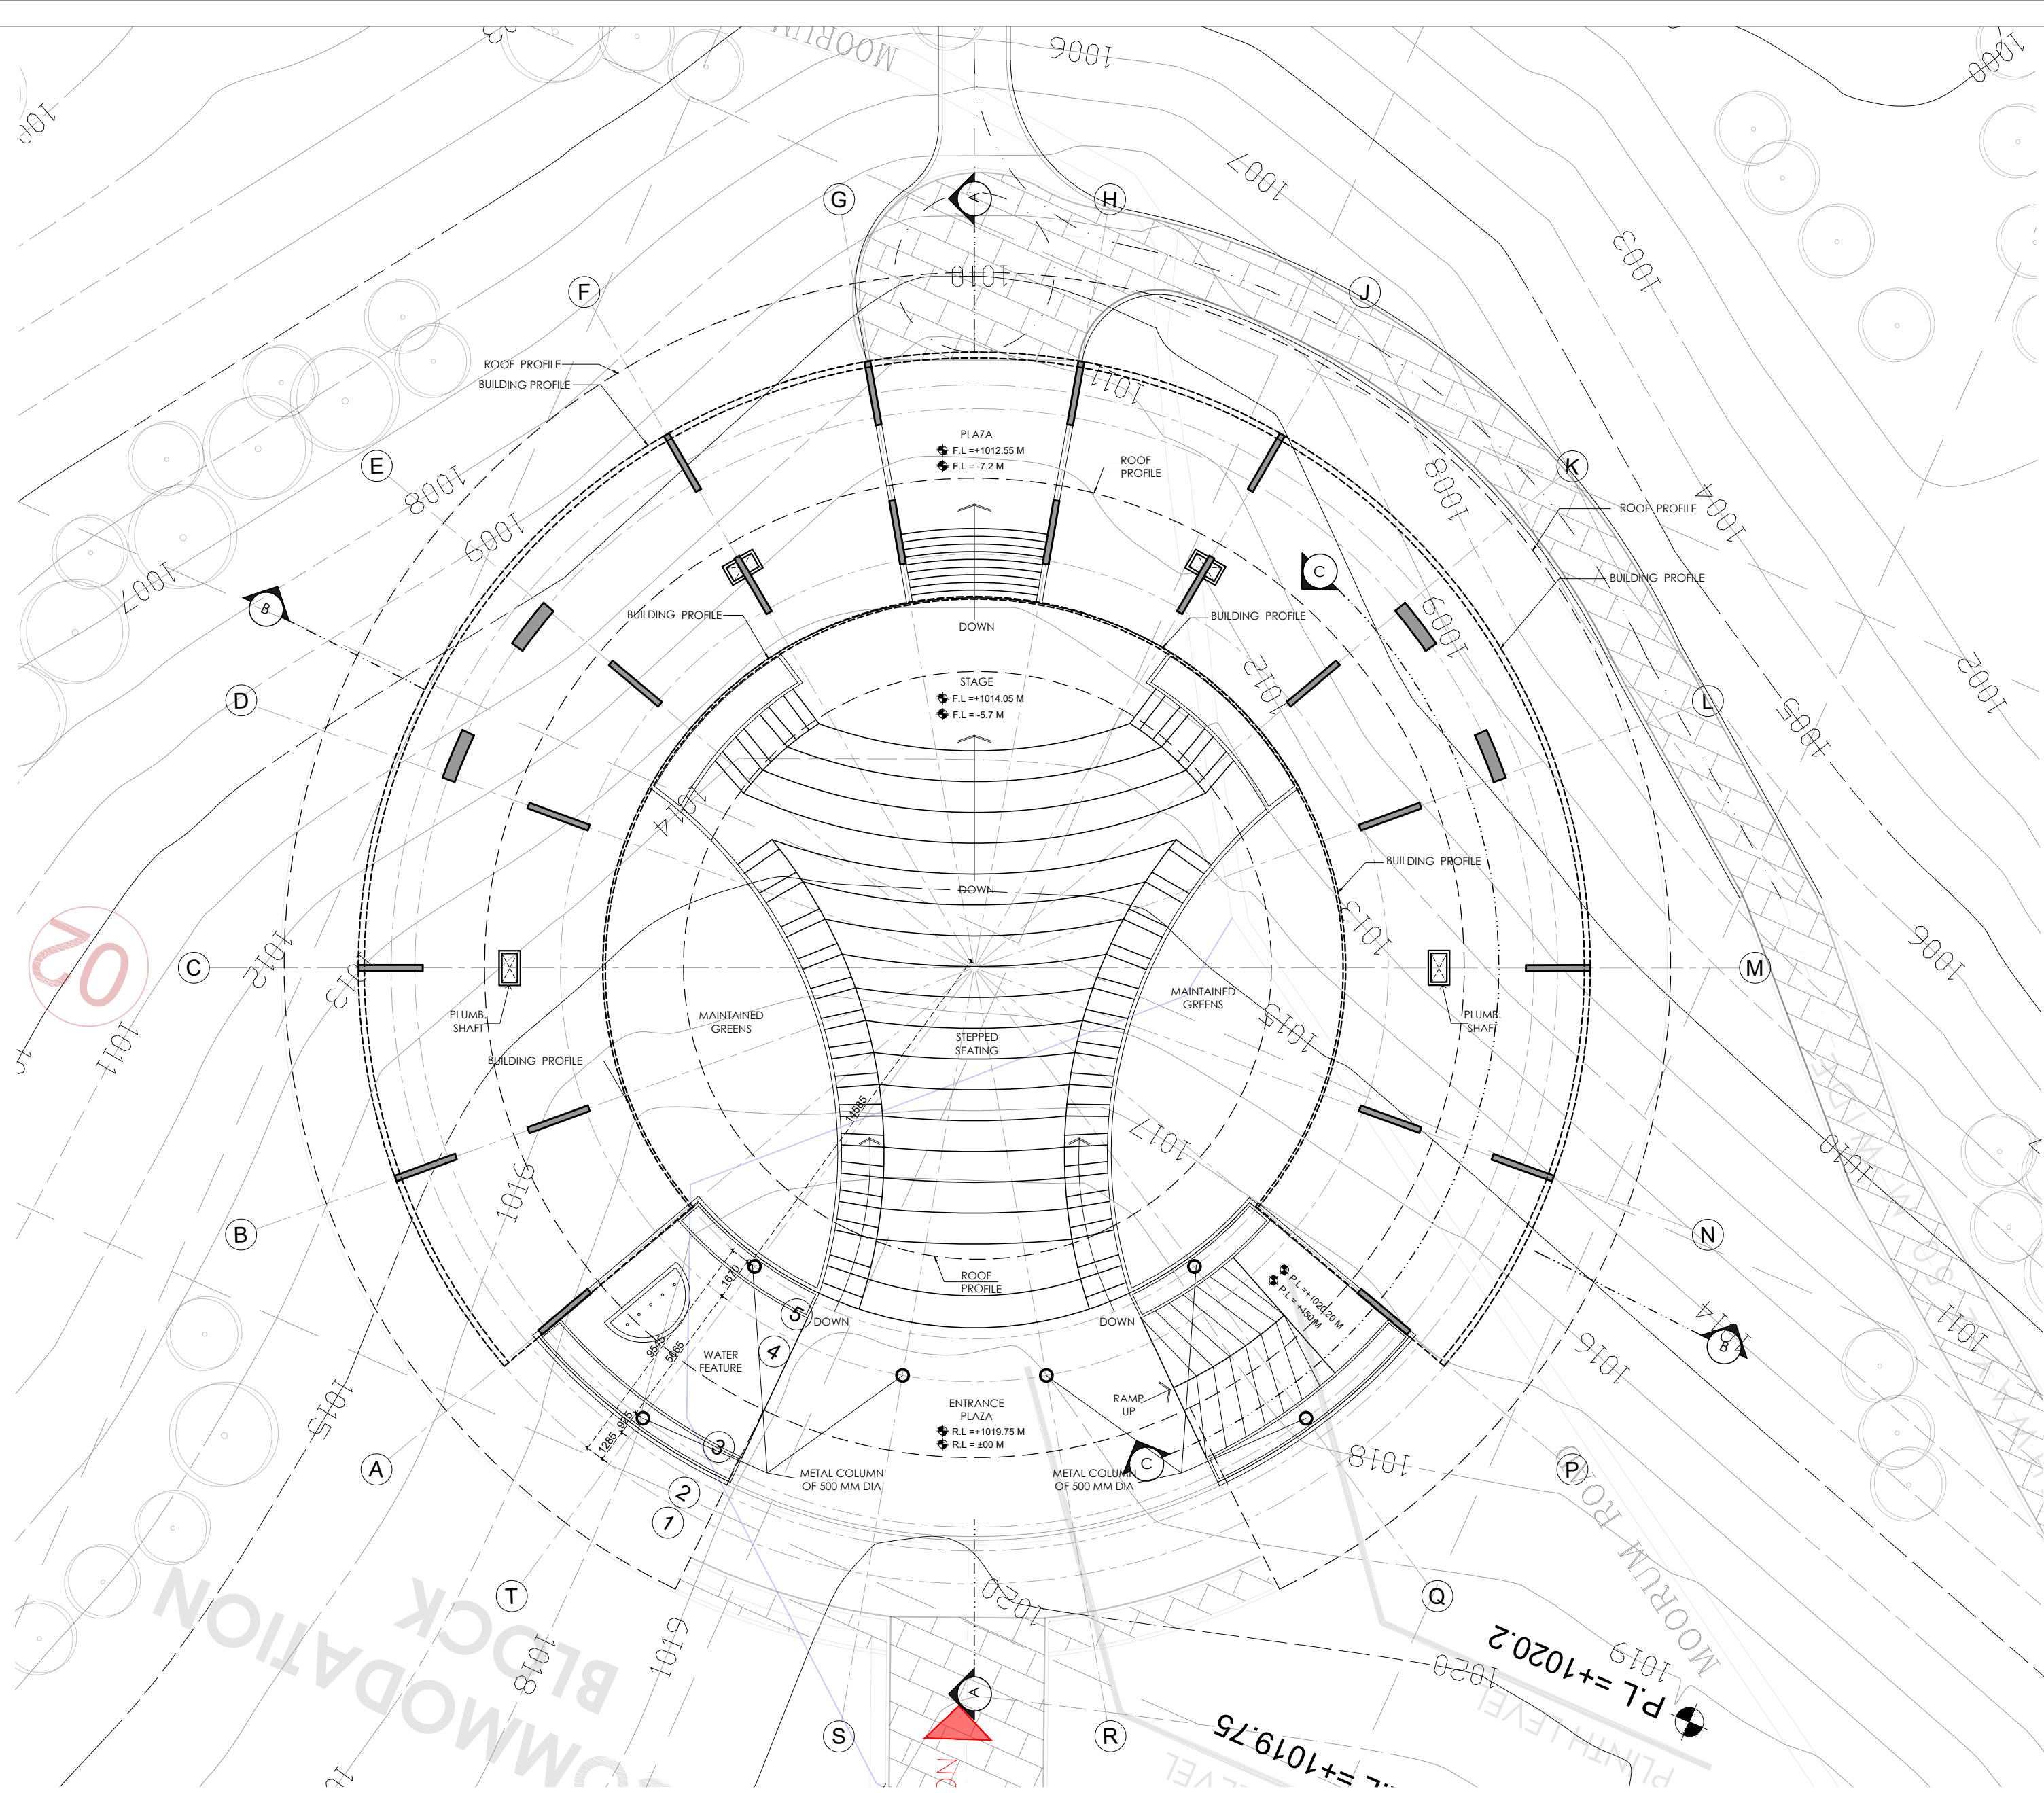


LOWER GROUND FLOOR PLAN
SCALE 1:200

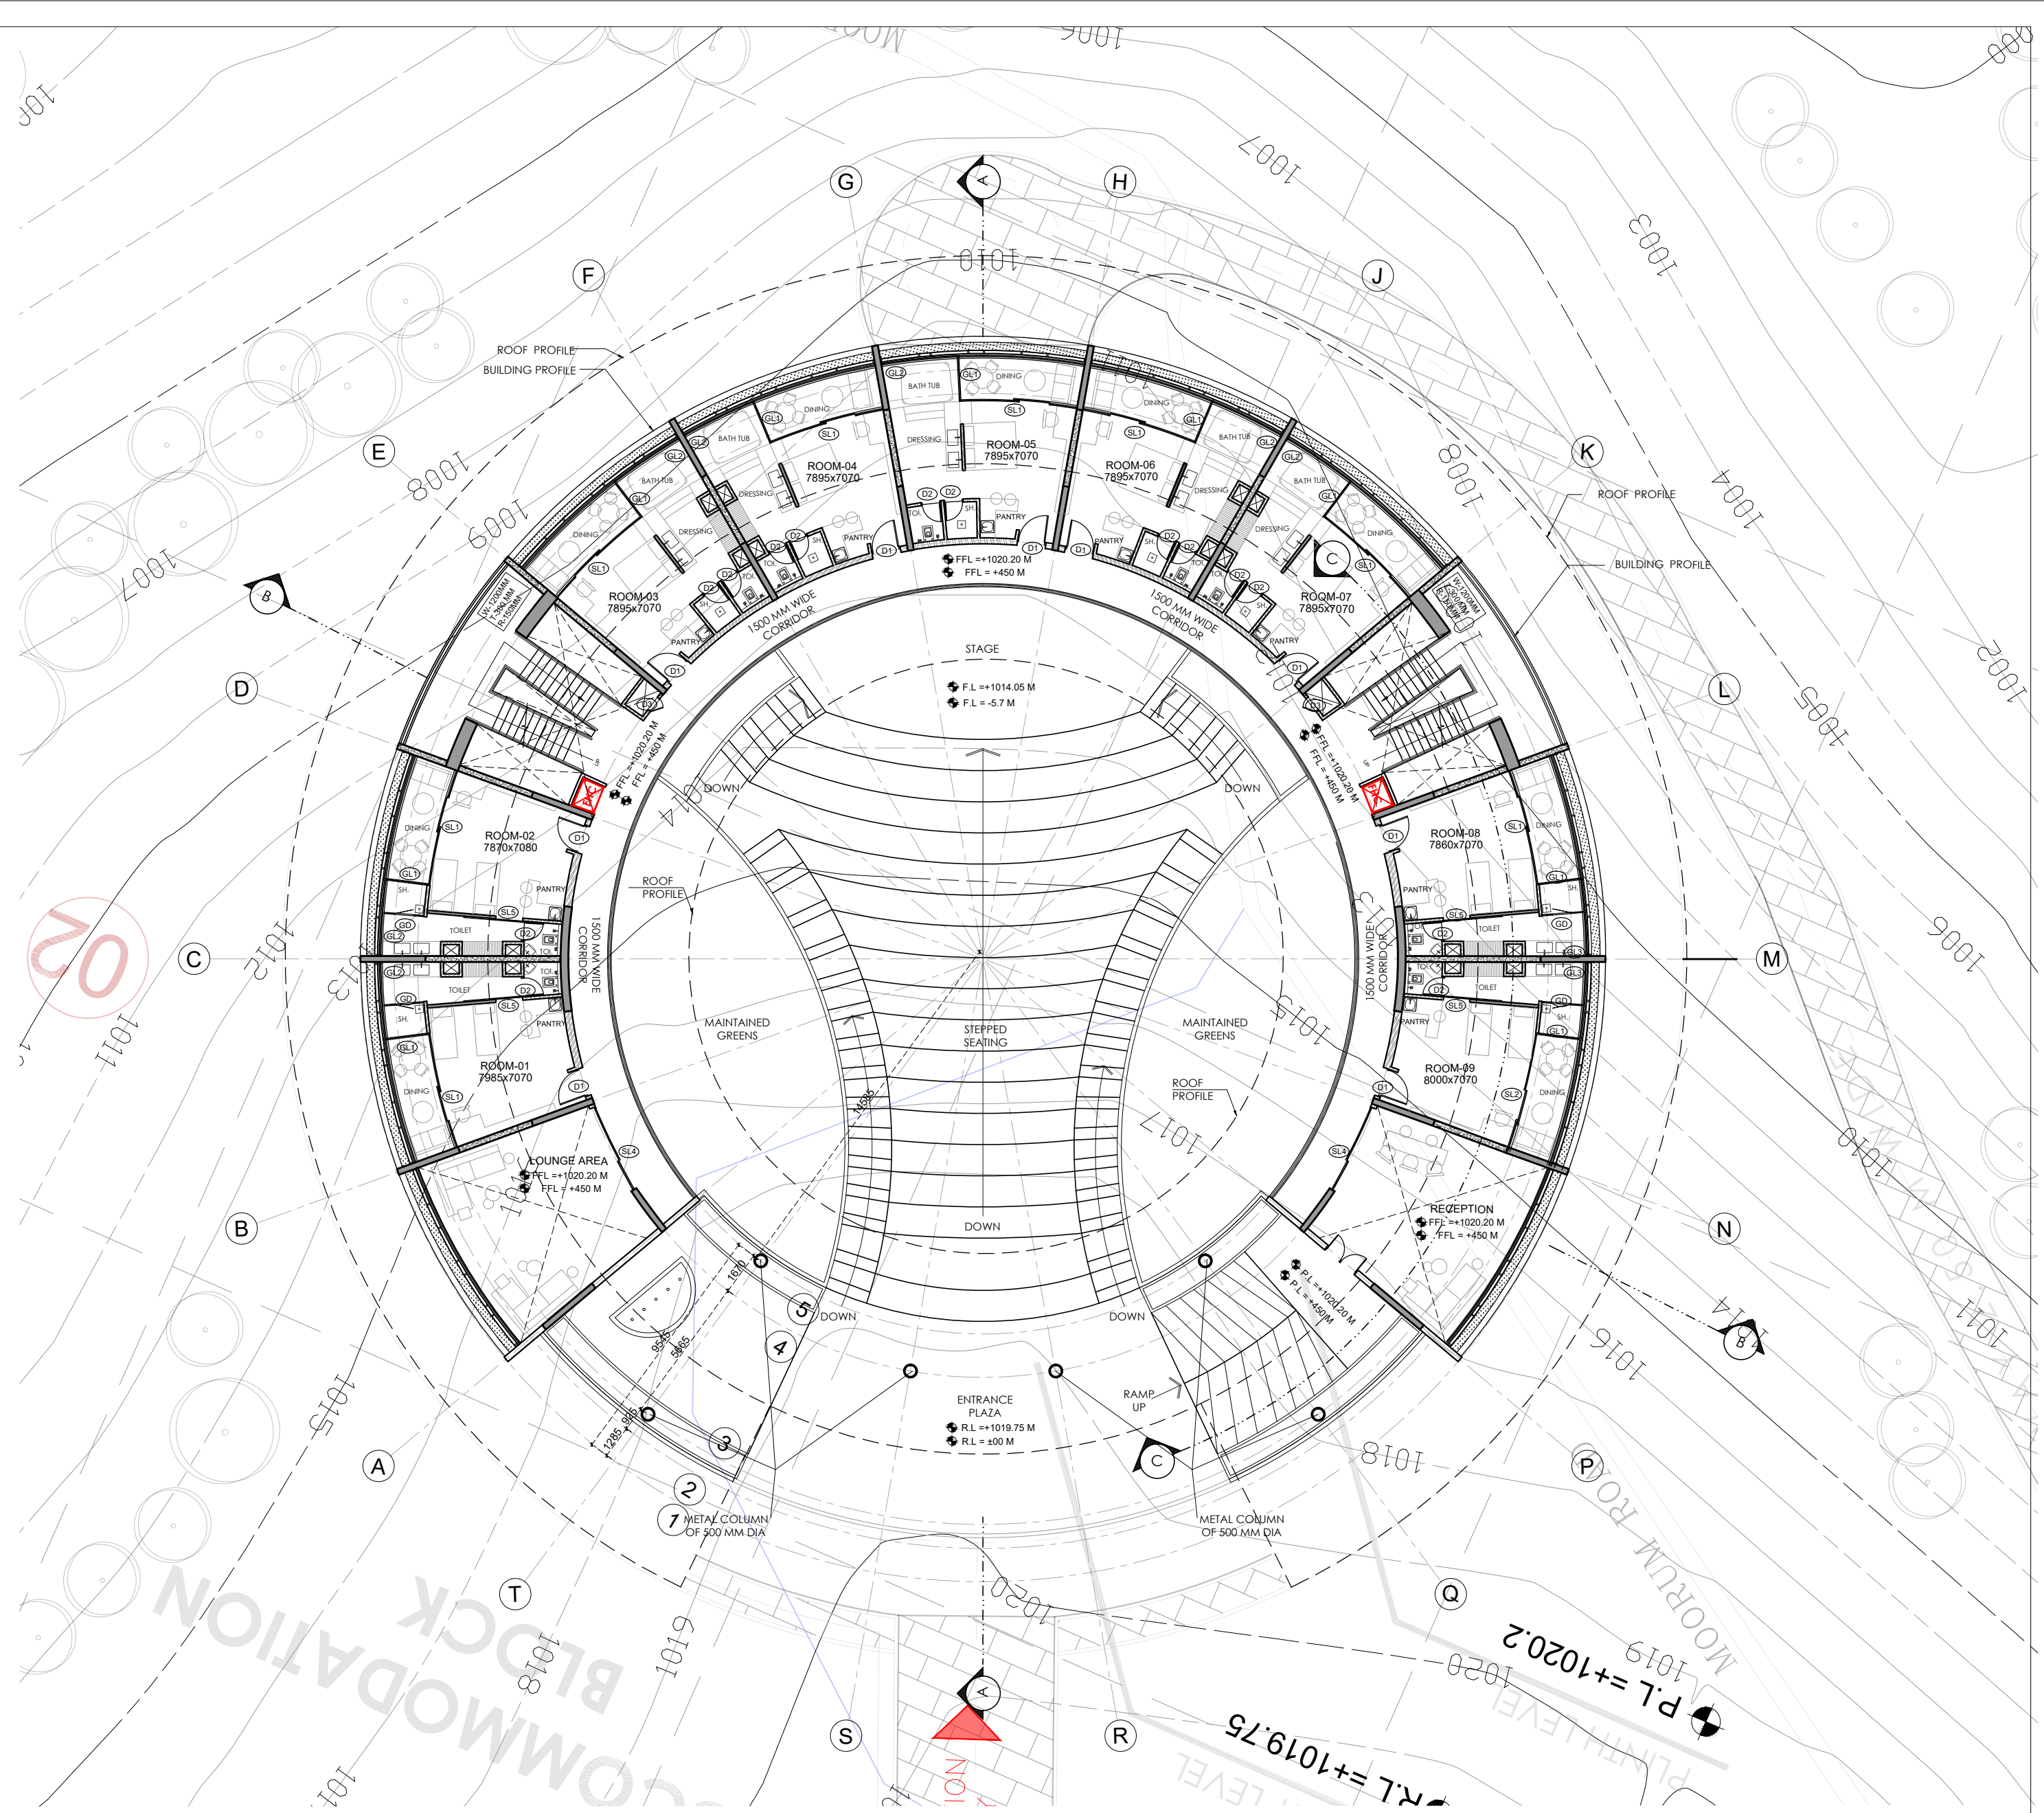

GROUND FLOOR PLAN
SCALE 1:200

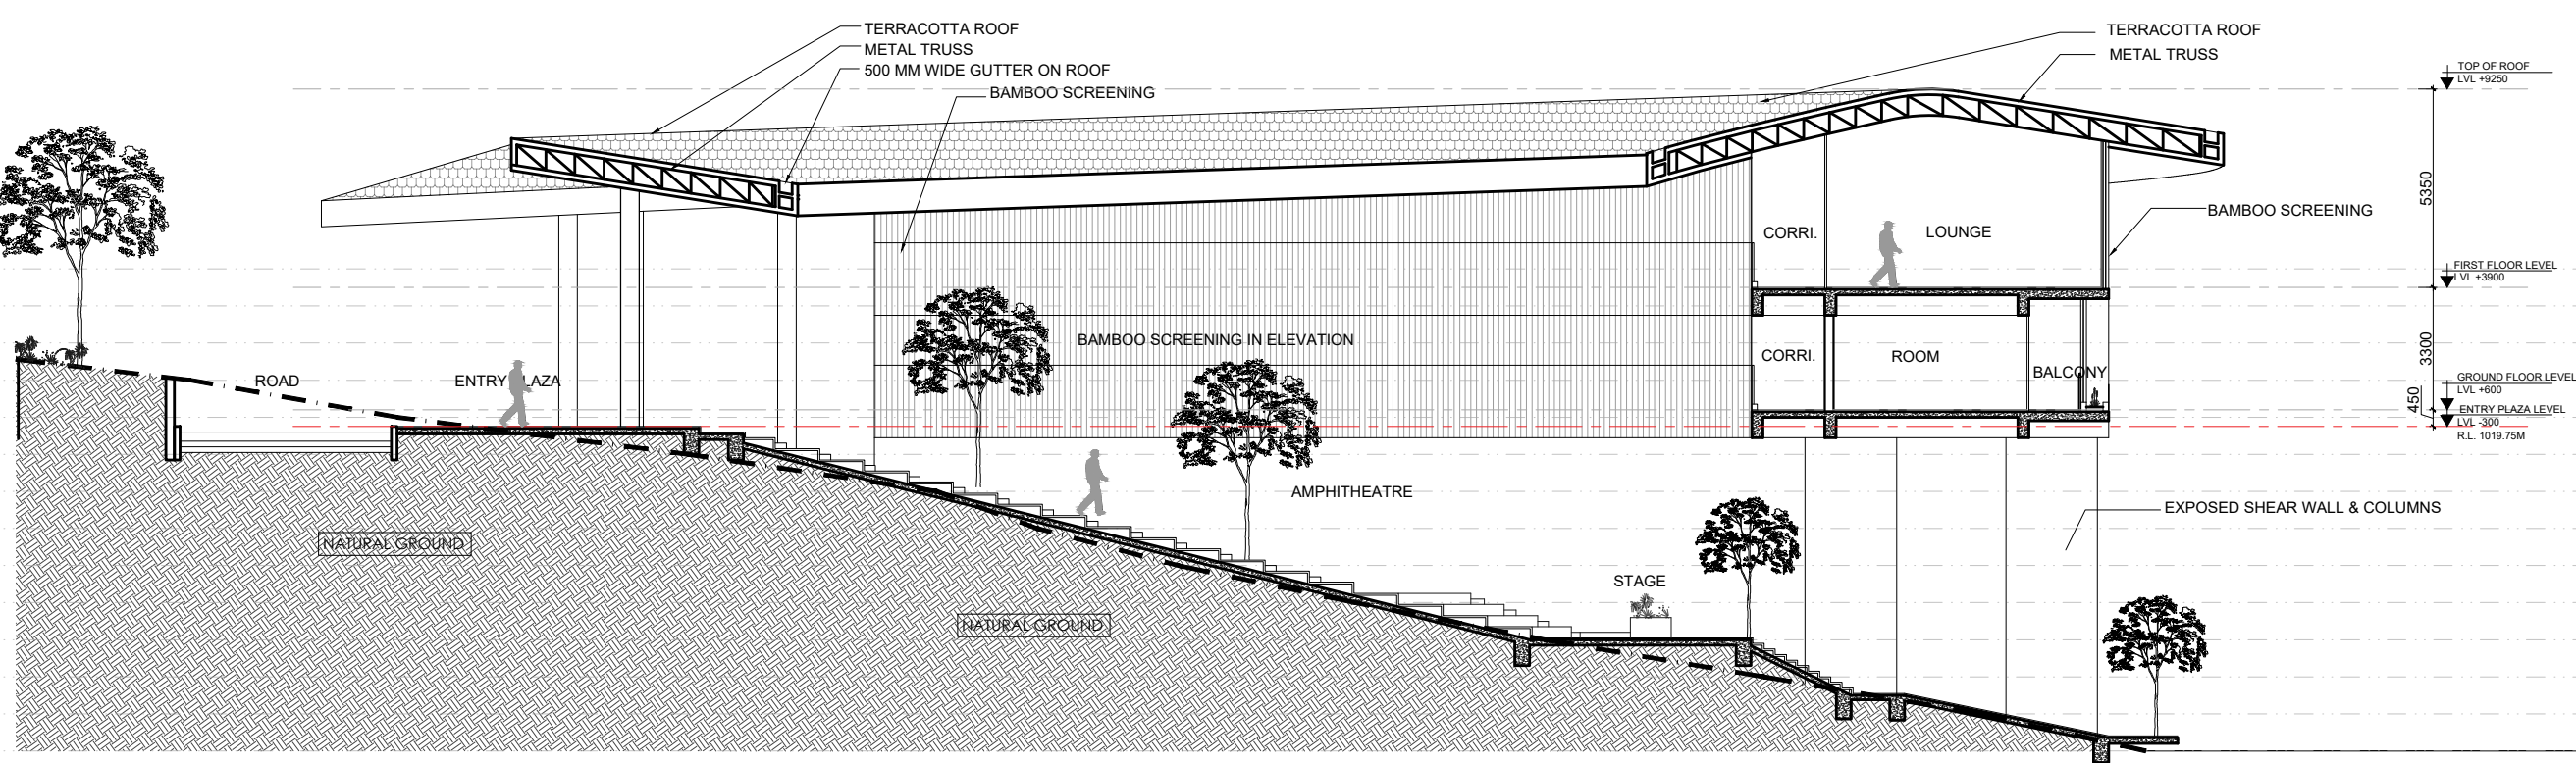

SECTION AA'
SCALE 1:200

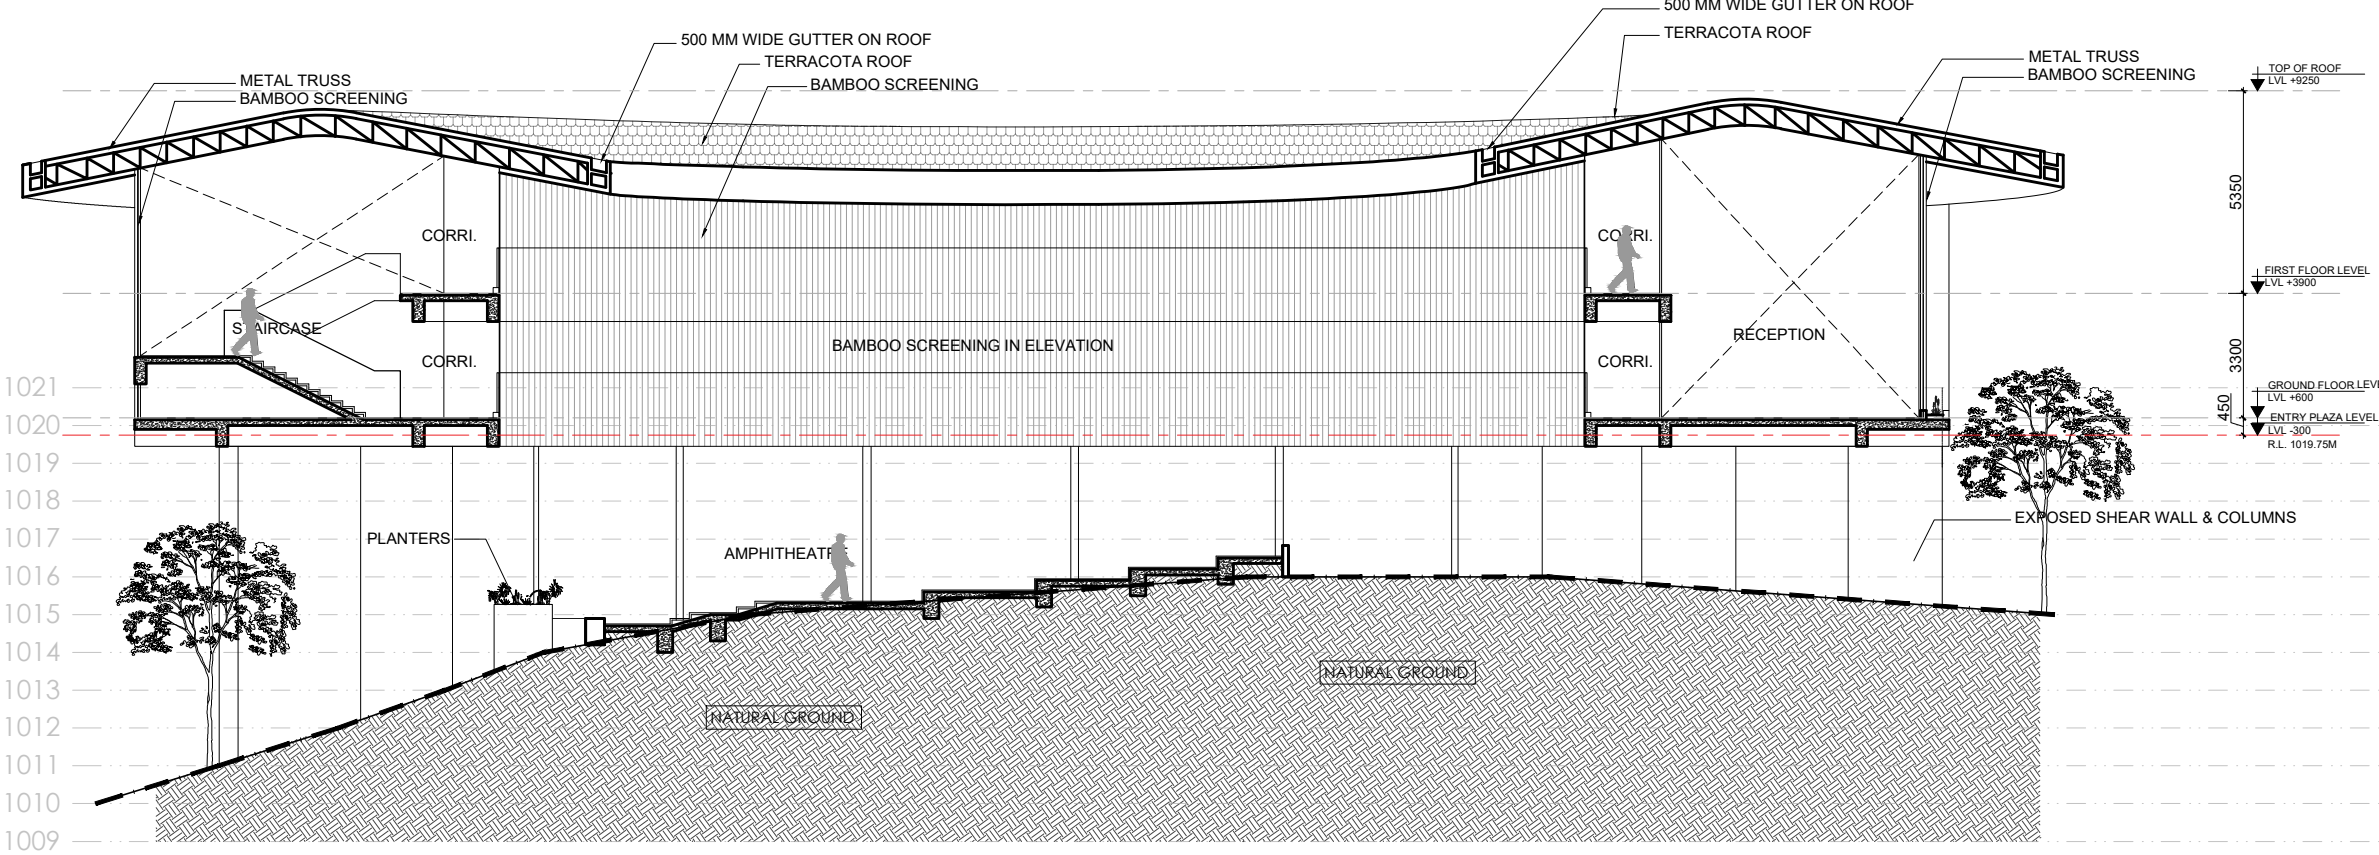

SECTION BB'
SCALE 1:200

DOOR WINDOW SCHEDULE TRIBAL HERITAGE CENTRE, MANDALGRE						
ACCOMMODATION BLOCK						
DOOR WINDOW SCHEDULE						
TAG	WIDTH	HEIGHT	CILL	LINTEL	MATERIAL	REMARK
D1	1100	2400	0	2400	WOODEN DOOR	SINGLE SWING DOOR
D2	750	2400	0	2400	WOODEN DOOR	SINGLE SWING DOOR
D3	600	2400	0	2400	WOODEN DOOR	SINGLE SWING DOOR
D4	1550	2400	0	2400	GLASS DOOR	Shower outside Glass Door-750
S1	4535	BEAM BOTTOM	0	BEAM BOTTOM	SLIDING GLASS DOOR	SLIDING Glass wall with Sliding Door-1150
S2	4675	BEAM BOTTOM	0	BEAM BOTTOM	SLIDING GLASS DOOR	SLIDING Glass wall with Sliding Door-1150
S3	5485	BEAM BOTTOM	0	BEAM BOTTOM	SLIDING GLASS DOOR	SLIDING Glass wall with Sliding Door-1150
S4	3500	BEAM BOTTOM	0	BEAM BOTTOM	SLIDING GLASS DOOR	SLIDING Glass wall with Sliding Door-1150
S5	1035	BEAM BOTTOM	0	BEAM BOTTOM	SLIDING GLASS DOOR	SLIDING Glass wall
GLAZING SCHEDULE						
GL1	1770	BEAM BOTTOM	100	BEAM BOTTOM	GLAZING	FIXED GLASS
GL2	2950	BEAM BOTTOM	100	BEAM BOTTOM	GLAZING	FIXED GLASS
GL3	3010	BEAM BOTTOM	100	BEAM BOTTOM	GLAZING	FIXED GLASS
GL4	8000	BEAM BOTTOM	100	BEAM BOTTOM	GLAZING	FIXED GLASS

- NOTES:
- DO NOT SCALE THE DRAWING. FOLLOW ONLY FIGURED DIMENSIONS.
 - ALL DIMENSIONS GIVEN IN THIS DRAWING ARE IN MILLIMETERS UNLESS NOTED OTHERWISE.
 - ALL DIMENSIONS TO BE VERIFIED ON SITE AND APPROVED BY THE SITE ENGINEER.
 - ANY DISCREPANCY OR AMBIGUITY IN THE DRAWINGS SHOULD IMMEDIATELY BE BROUGHT TO NOTICE OF THE ARCHITECT.
 - ALL DRAWINGS SHOULD BE READ IN CONJUNCTION WITH OTHER RELEVANT ARCHITECTURAL, STRUCTURAL, PLUMBING, MECHANICAL AND ELECTRICAL DRAWINGS.
 - THE ± 0 REFERS TO LEVEL ESTABLISHED AT SITE IN PRESENCE OF THE SITE SUPERVISOR AND THE ARCHITECT. ALL REMAINING LEVELS ARE RELATIVE TO THIS LEVEL.
 - THIS DRAWING IS THE COPYRIGHT OF ARCHOHM CONSULTANTS AND MUST NOT BE RETAINED, COPIED OR USED WITHOUT THEIR AUTHORITY.

REVISIONS			
No.	Date	Descriptions	Revision by

Client:
MEGHALAYAN AGE LIMITED (MAL)

Project:
TRIBAL HERITAGE CENTRE, MANDALGRE, MEGHALAYA

Architects:



TPC TECHNICAL PROJECTS CONSULTANTS PVT. LTD.
H/O B-14, Sector 07, Noida, UP
T: 91 120 42 48 788
F: 91 120 42 48 788
www.archohm.com

Structural Consultants:

TPC TECHNICAL PROJECTS CONSULTANTS PVT. LTD.
H/O B-14, Sector 07, Noida, UP
T: 91 120 42 48 788
F: 91 120 42 48 788
www.archohm.com

Electrical Consultants:

ARCHOHM CONSULTANTS PVT. LTD.
H/O B-14, Sector 07, Noida, UP
T: 91 120 42 48 788
F: 91 120 42 48 788
www.archohm.com

Mechanical Consultants:

ARCHOHM CONSULTANTS PVT. LTD.
H/O B-14, Sector 07, Noida, UP
T: 91 120 42 48 788
F: 91 120 42 48 788
www.archohm.com

MEP Consultants & Project Managers

Drawn By: SJ

Checked By: GK

Design By: SG

Date:

30-08-2024

Scale:

1:200

Project No.:

A-232409

Drawing No.:

A-232409-B2-01-01

Sheet Title:





TRIBAL HERITAGE CENTER

ACCOMMODATION BLOCK

(SHEET 01 OF 02)

A1

R0

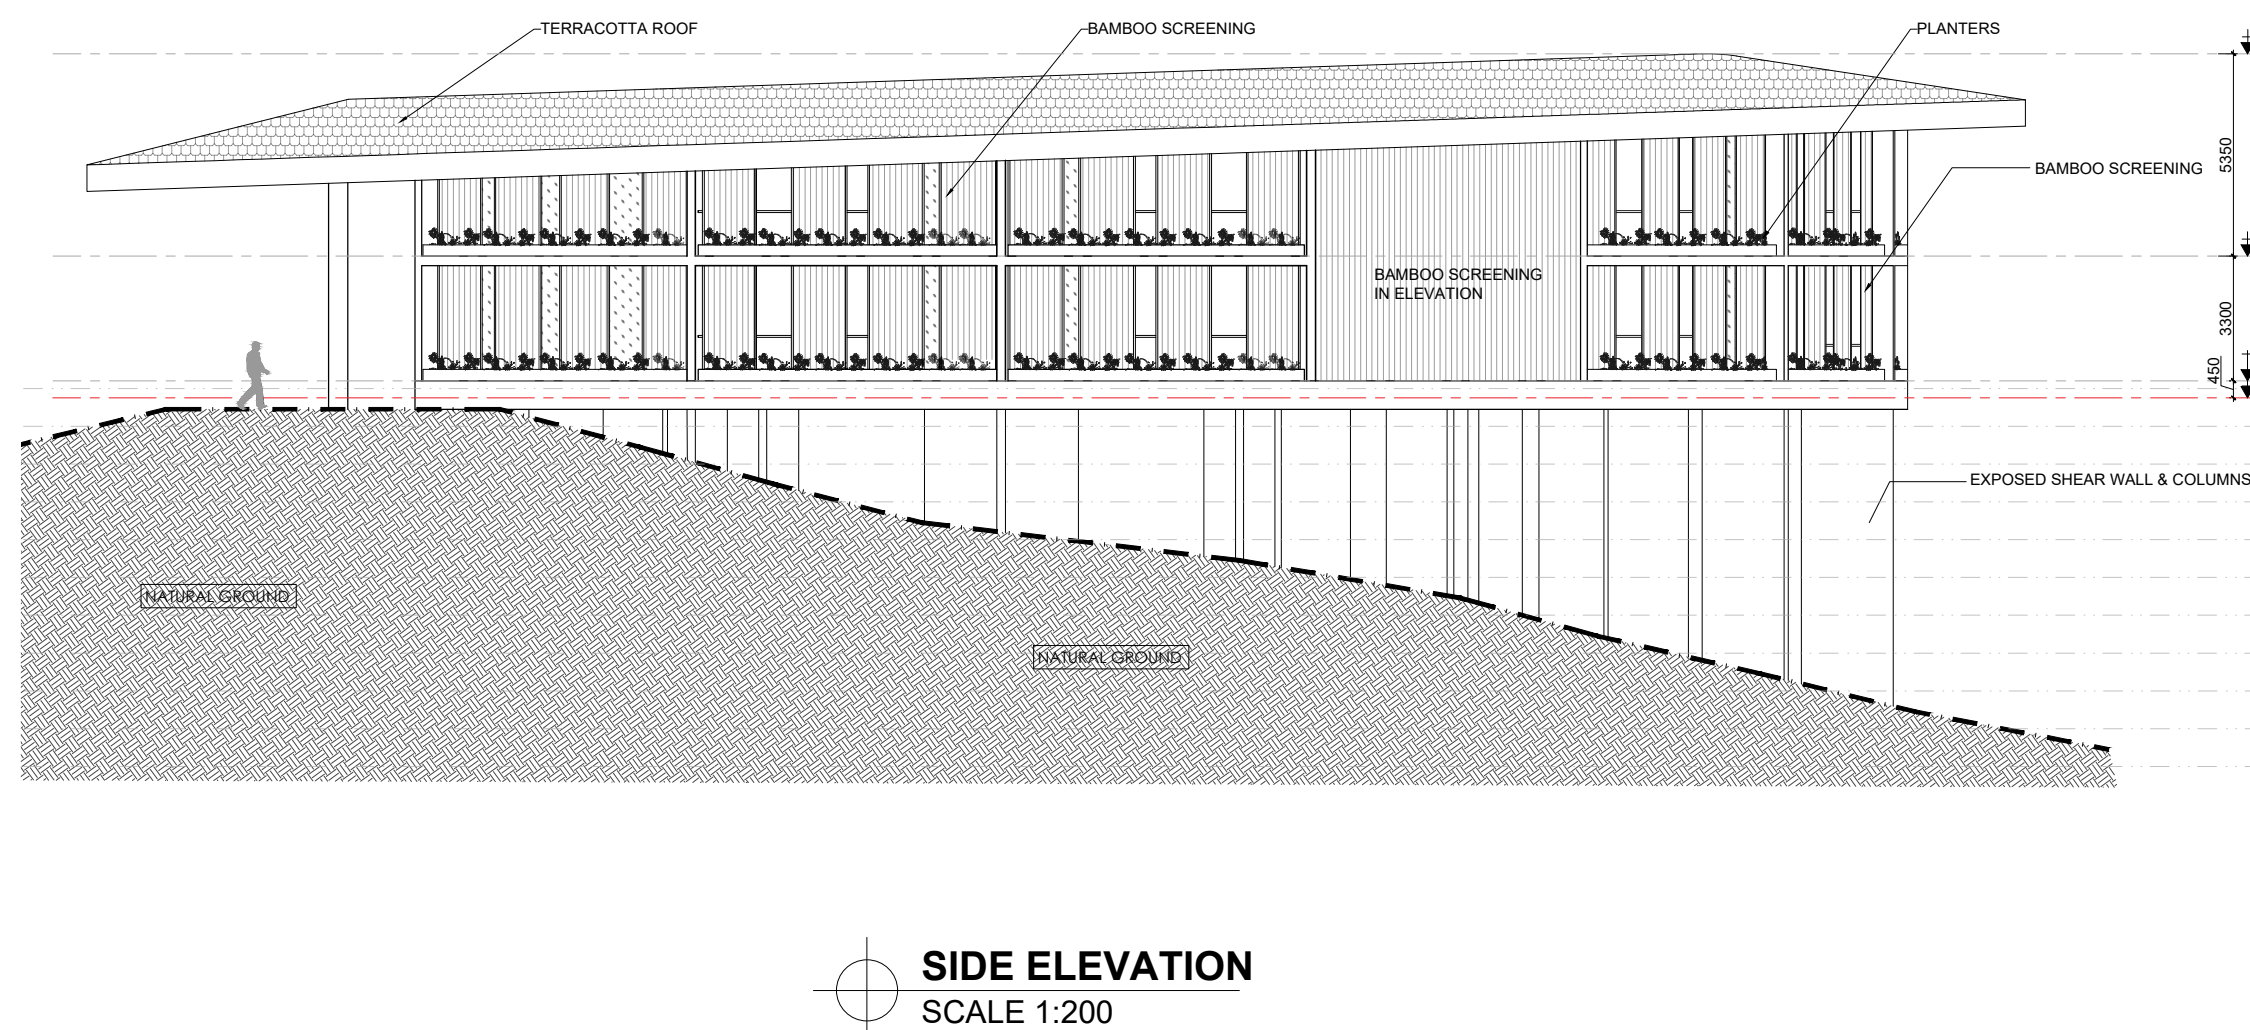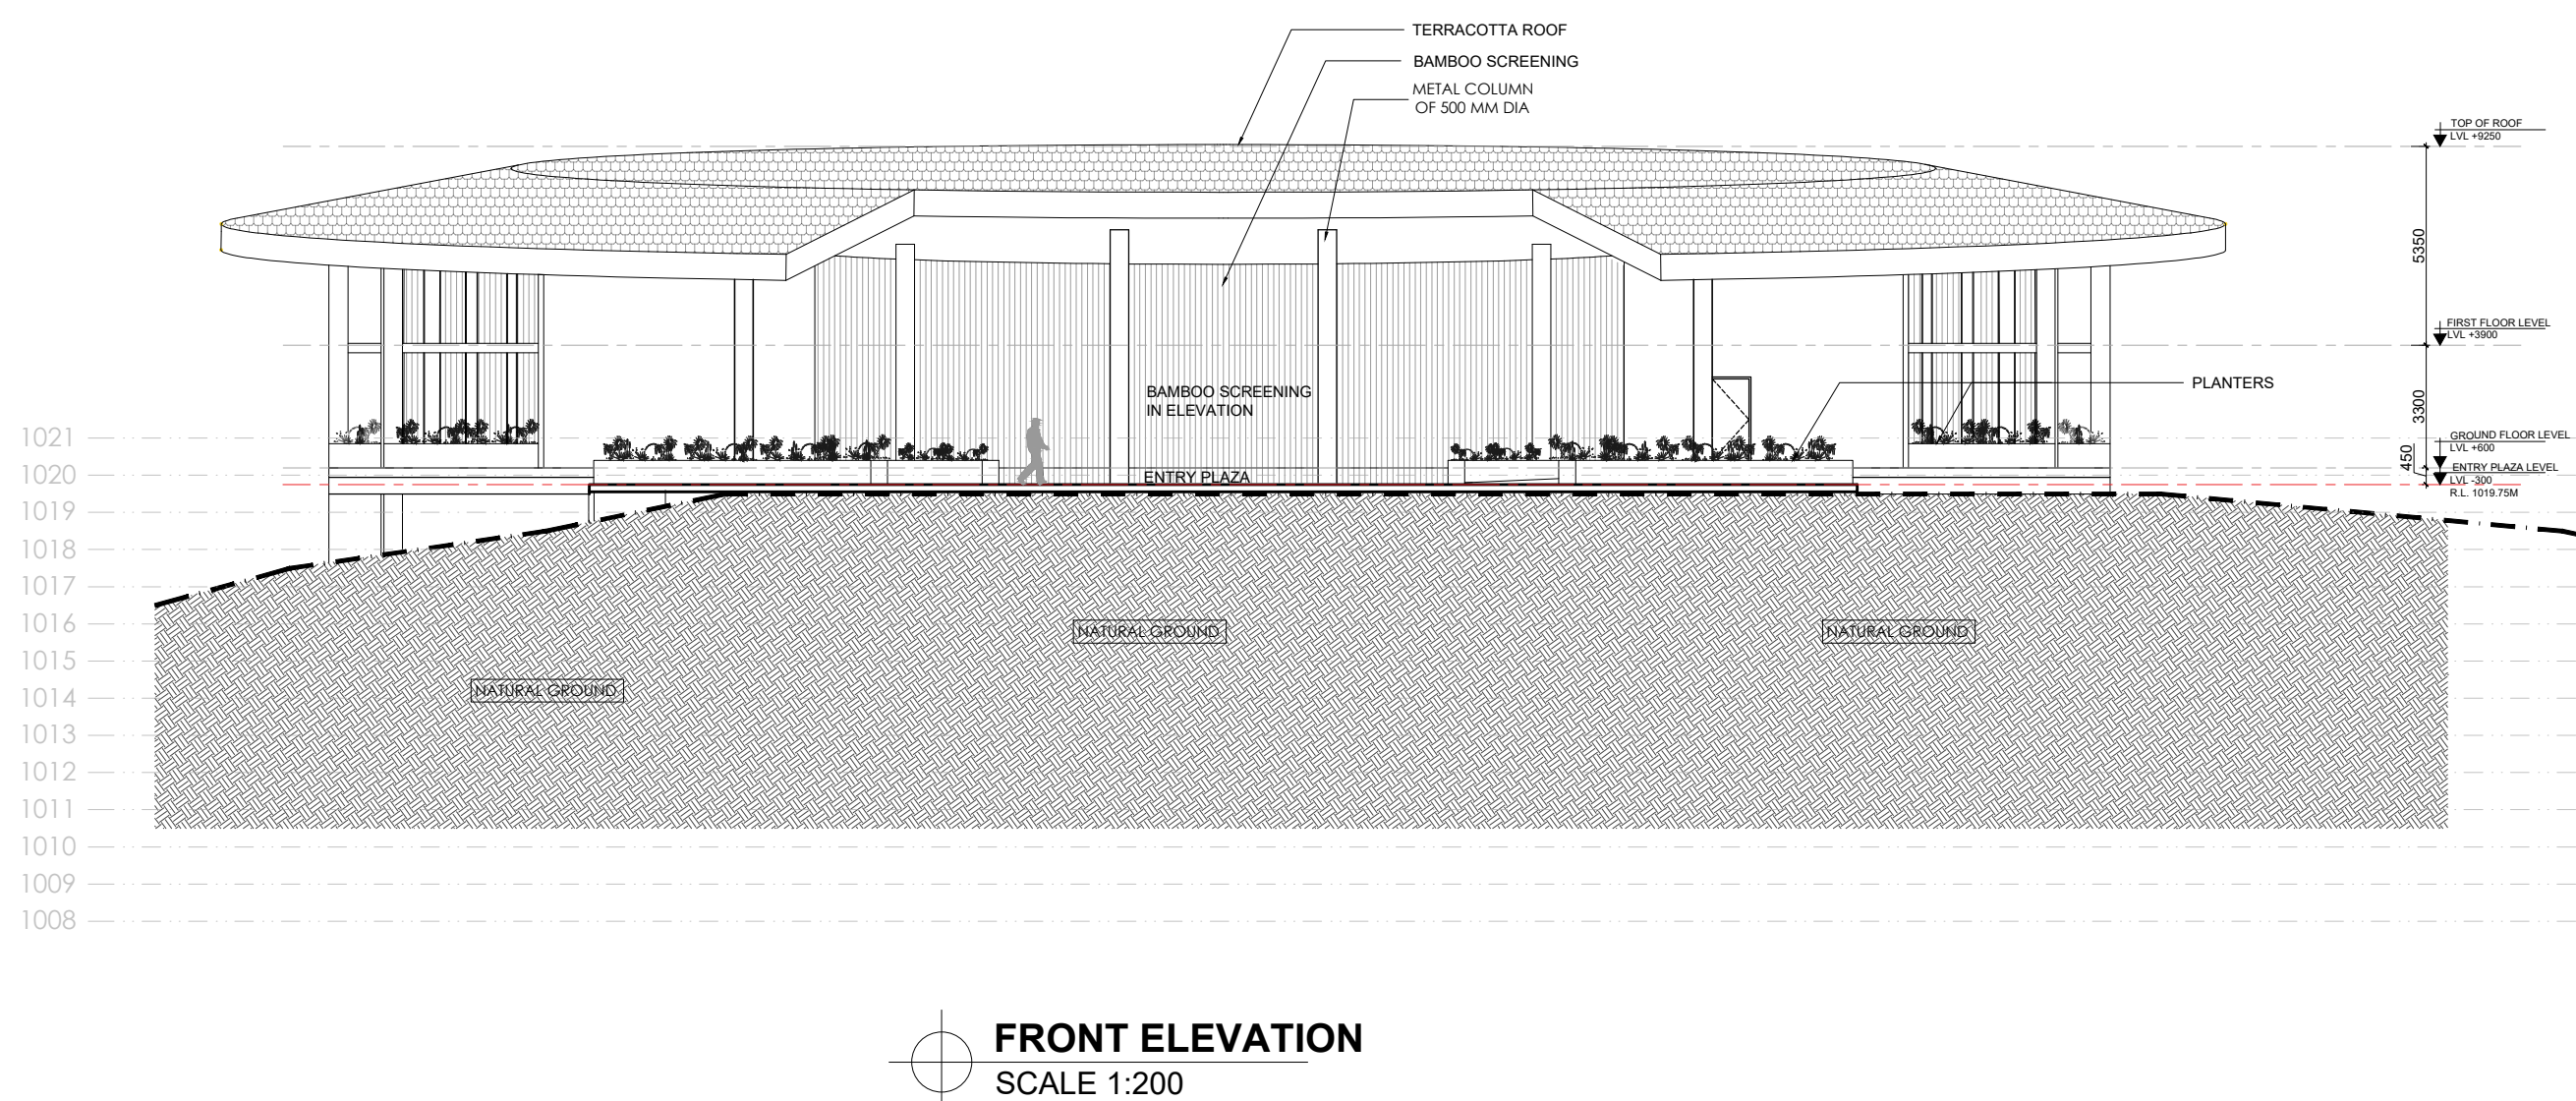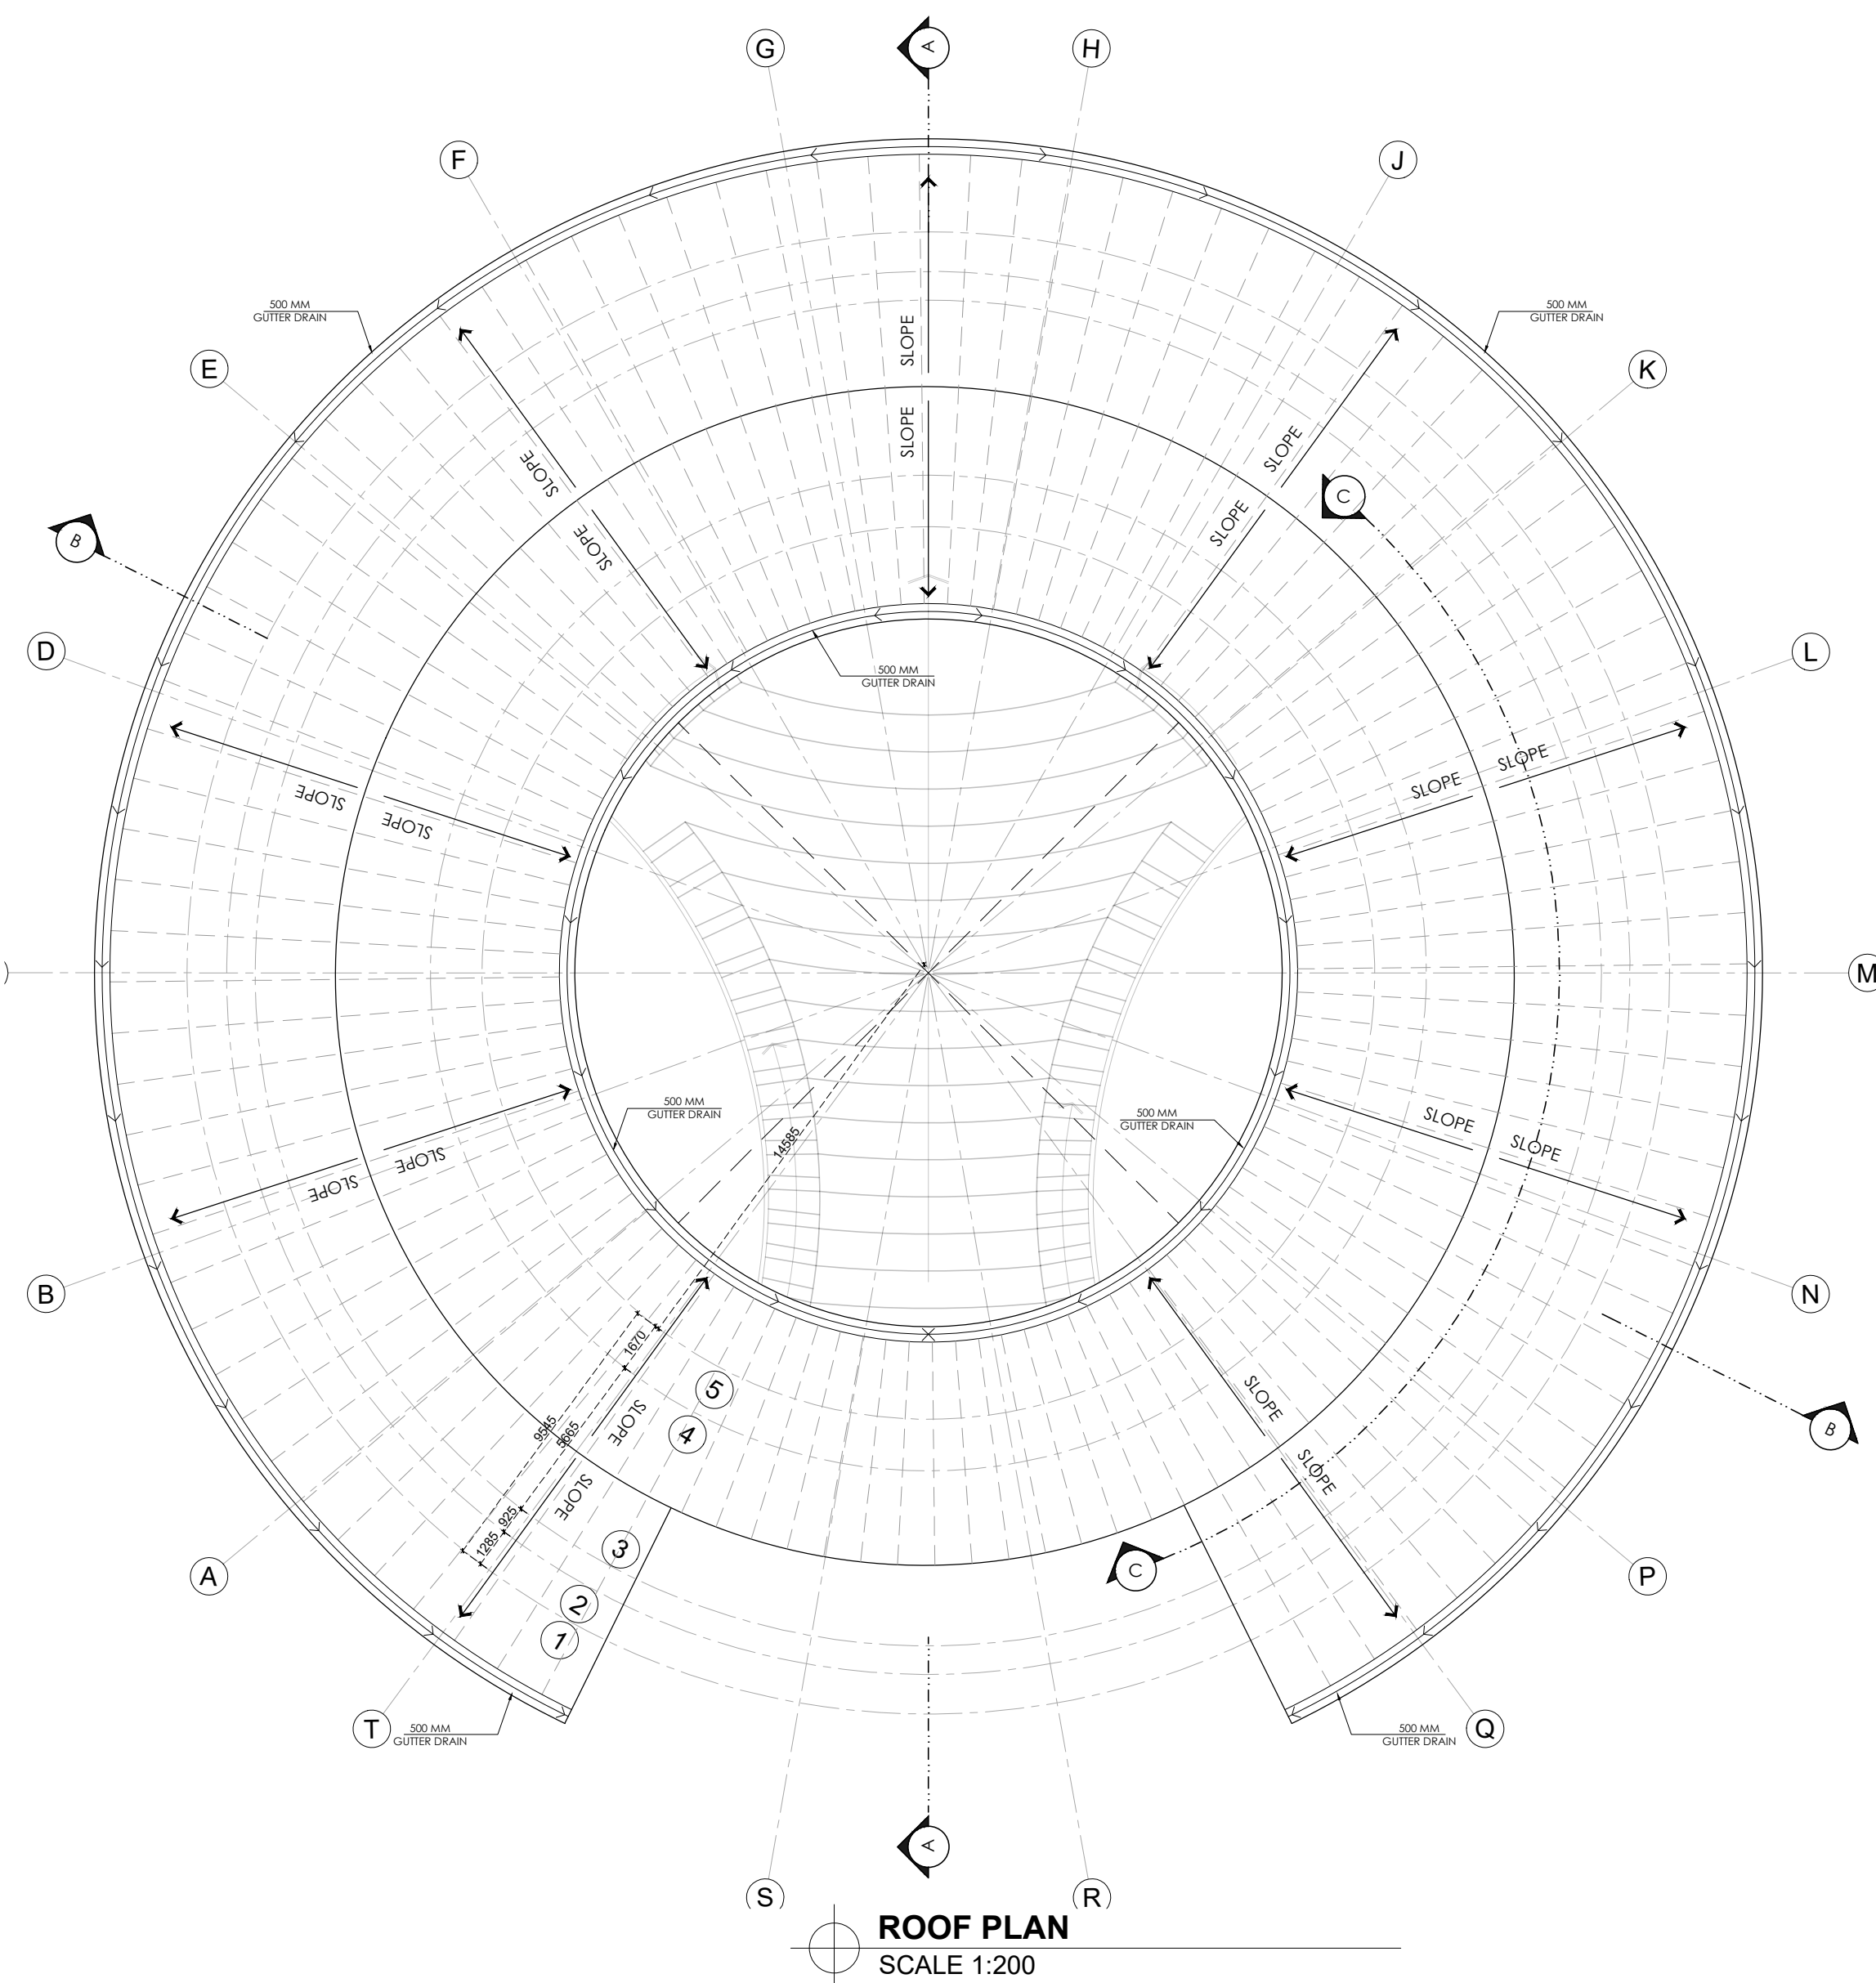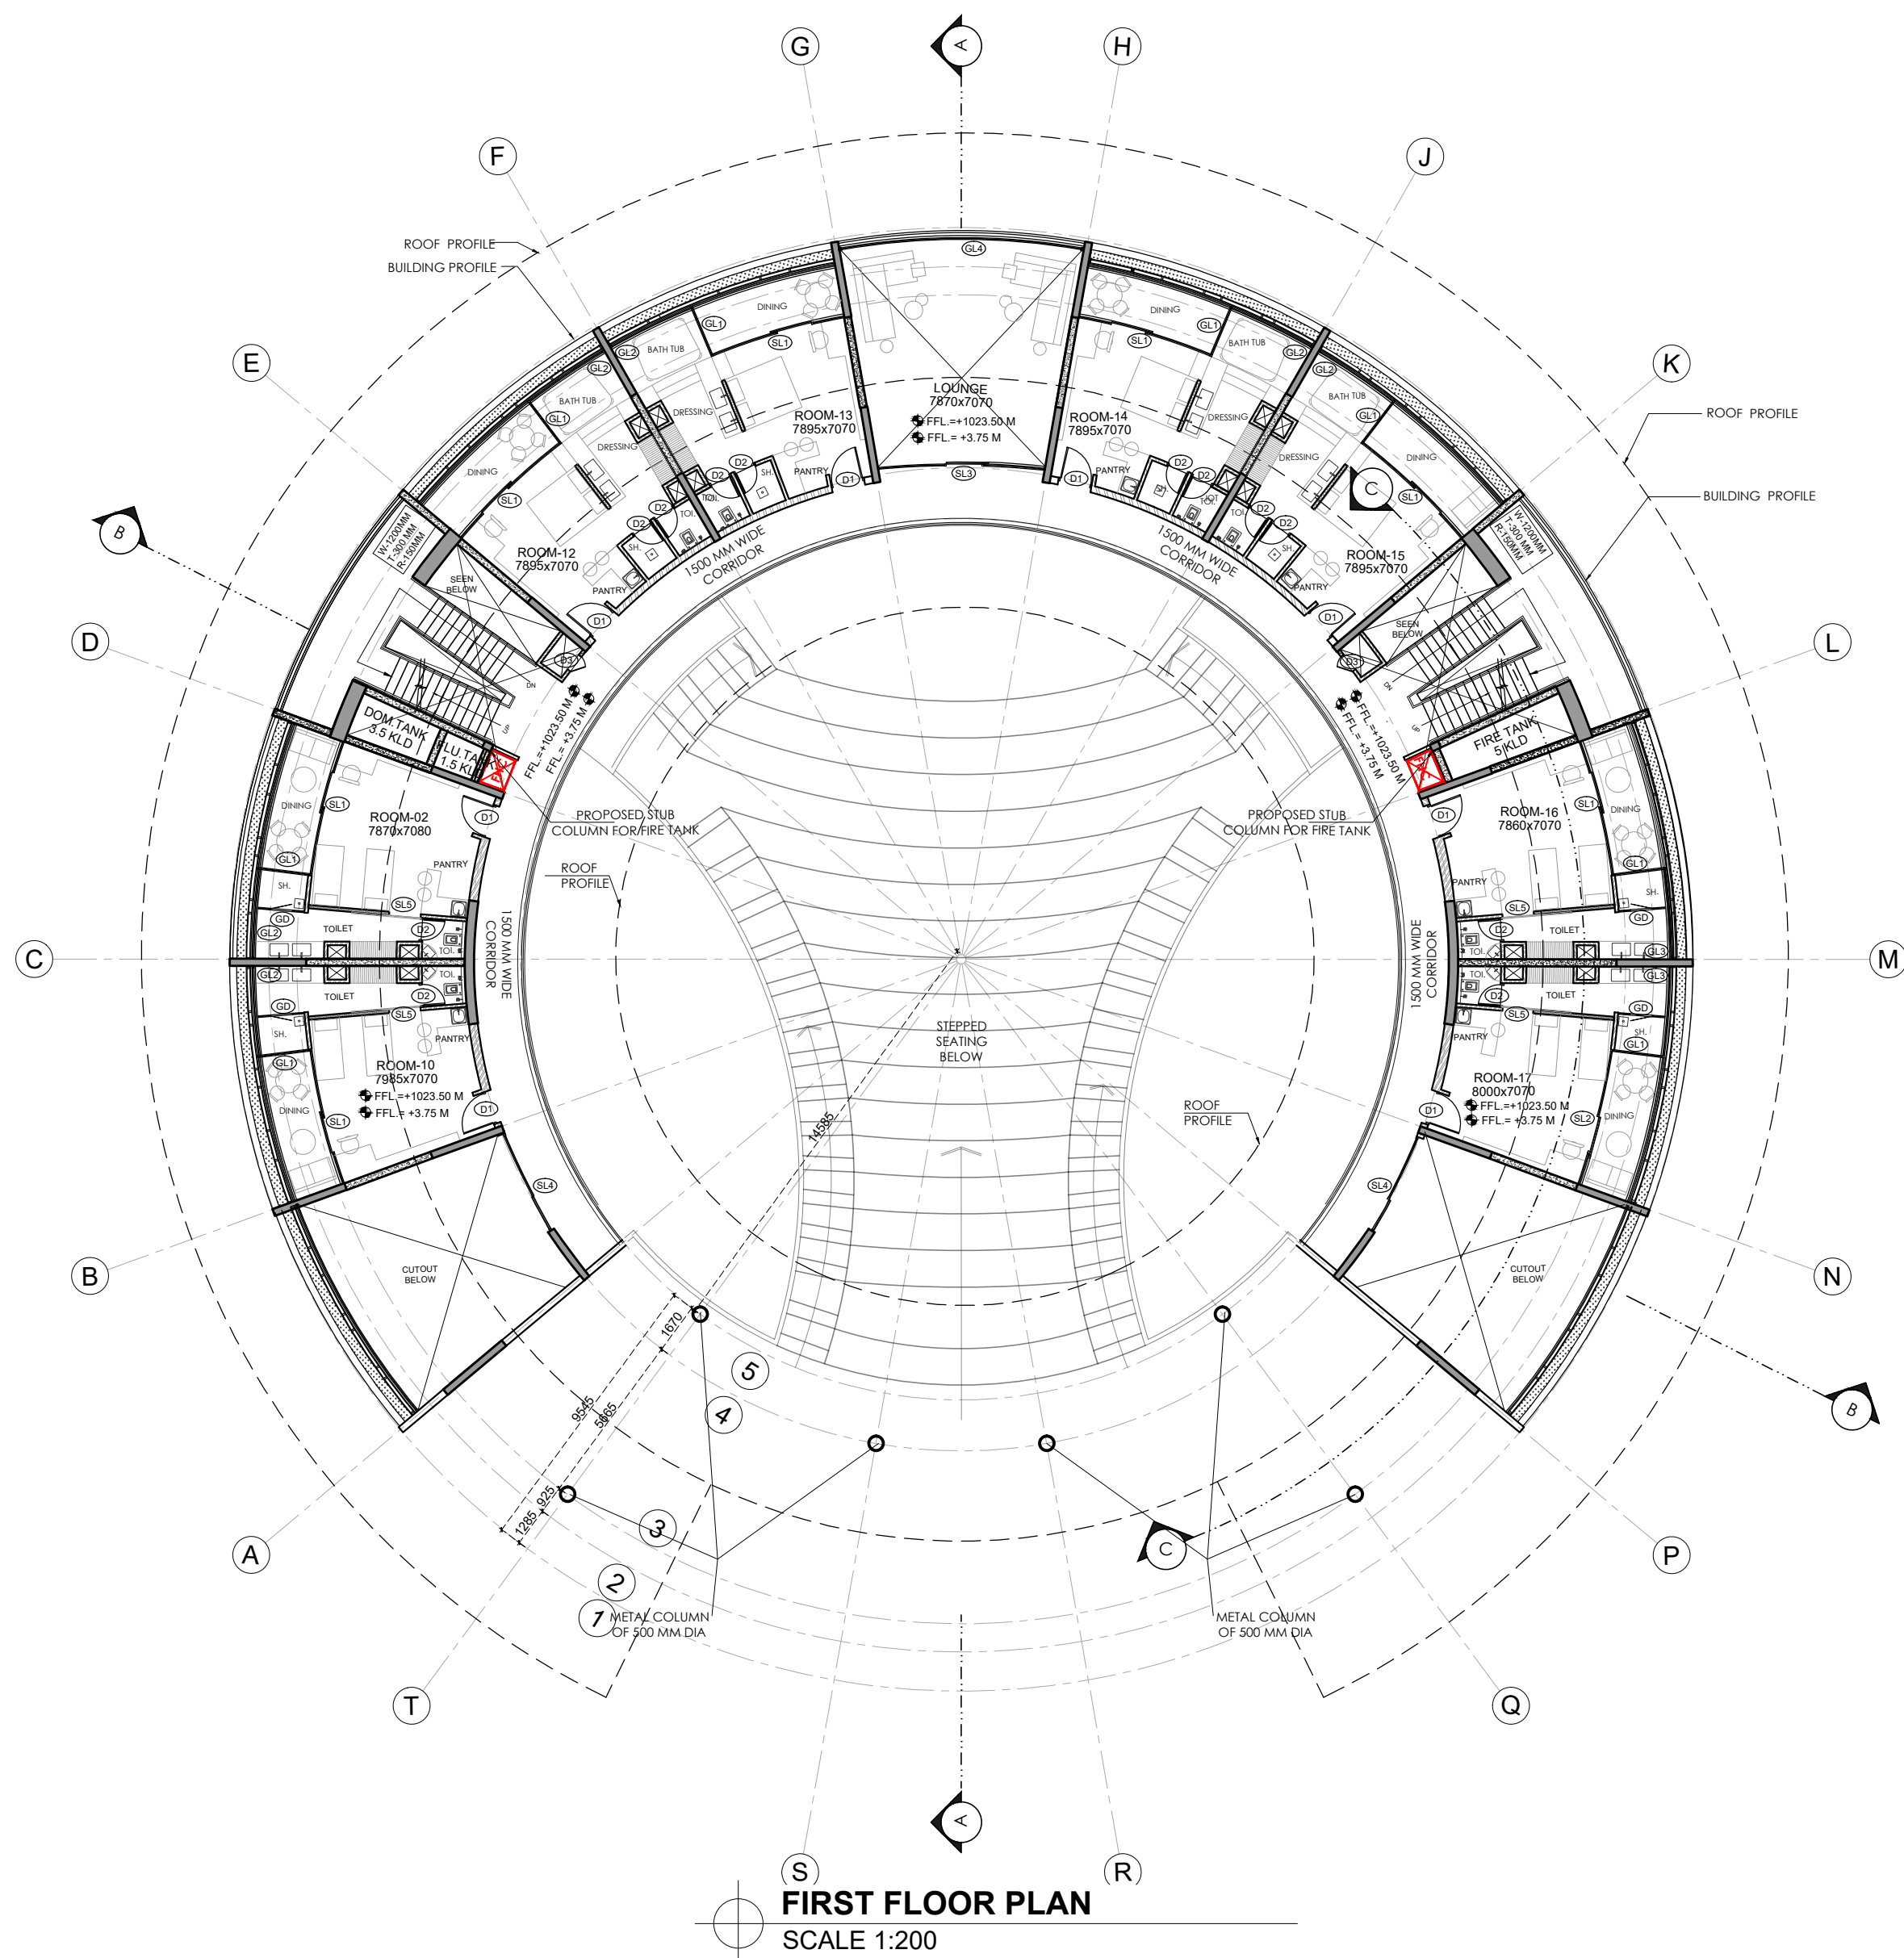

DOOR WINDOW SCHEDULE TRIBAL HERITAGE CENTRE, MANDALGRE						
ACCOMMODATION BLOCK						
DOOR WINDOW SCHEDULE						
TAG	WIDTH	HEIGHT	CILL	LINTEL	MATERIAL	TYPE
D1	1100	2400	0	2400	WOODEN DOOR	SINGLE SWING
D2	750	2400	0	2400	WOODEN DOOR	SINGLE SWING
D3	600	2400	0	2400	WOODEN DOOR	SINGLE SWING
D4	1550	2400	0	2400	GLASS DOOR	SINGLE SWING
D5	4535	BEAM BOTTOM	0	BEAM BOTTOM	SLIDING GLASS DOOR	SLIDING
D6	4675	BEAM BOTTOM	0	BEAM BOTTOM	SLIDING GLASS DOOR	SLIDING
D7	5485	BEAM BOTTOM	0	BEAM BOTTOM	SLIDING GLASS DOOR	SLIDING
D8	3500	BEAM BOTTOM	0	BEAM BOTTOM	SLIDING GLASS DOOR	SLIDING
D9	1035	BEAM BOTTOM	0	BEAM BOTTOM	SLIDING GLASS DOOR	SLIDING
GLAZING SCHEDULE						
GL1	1770	BEAM BOTTOM	100	BEAM BOTTOM	GLAZING	FIXED GLASS
GL2	2950	BEAM BOTTOM	100	BEAM BOTTOM	GLAZING	FIXED GLASS
GL3	3010	BEAM BOTTOM	100	BEAM BOTTOM	GLAZING	FIXED GLASS
GL4	8000	BEAM BOTTOM	100	BEAM BOTTOM	GLAZING	FIXED GLASS

- NOTES:
- DO NOT SCALE THE DRAWING. FOLLOW ONLY FIGURED DIMENSIONS.
 - ALL DIMENSIONS GIVEN IN THIS DRAWING ARE IN MILLIMETERS UNLESS NOTED OTHERWISE.
 - ALL DIMENSIONS TO BE VERIFIED ON SITE AND APPROVED BY THE SITE ENGINEER.
 - ANY DISCREPANCY OR AMBIGUITY IN THE DRAWINGS SHOULD IMMEDIATELY BE BROUGHT TO NOTICE OF THE ARCHITECT.
 - ALL DRAWINGS SHOULD BE READ IN CONJUNCTION WITH OTHER RELEVANT ARCHITECTURAL, STRUCTURAL, PLUMBING, MECHANICAL AND ELECTRICAL DRAWINGS.
 - THE ± 0 REFERS TO LEVEL ESTABLISHED AT SITE IN PRESENCE OF THE SITE SUPERVISOR AND THE ARCHITECT. ALL REMAINING LEVELS ARE RELATIVE TO THIS LEVEL.
 - THIS DRAWING IS THE COPYRIGHT OF ARCHOHM CONSULTANTS.
 - AND MUST NOT BE RETAINED, COPIED OR USED WITHOUT THEIR AUTHORITY.

REVISIONS			
No.	Date	Descriptions	Revision by

Client:
MEGHALAYAN AGE LIMITED (MAL)

Project:
TRIBAL HERITAGE CENTRE, MANDALGRE, MEGHALAYA

Architects:



Structural Consultants:
TPC TECHNICAL PROJECTS CONSULTANTS (PVT.) LTD.
C-286, Sector-45, Gurgaon-122009
T: 91 120 42 48 7888
F: 91 120 42 48 7888
www.tpcindia.com

Electrical Consultants:
ARCHOHM CONSULTANT PVT. LTD.
B-10, Sector-45, Gurgaon-122009
T: 91 120 42 48 7888
F: 91 120 42 48 7888
www.archohm.com


Mechanical Consultants:
WAC Engineers
INDIA PVT. LTD.
MEP Consultants & Project Managers
P: 91 120 42 48 7888
F: 91 120 42 48 7888
www.wacindia.com

Drawn By: SJ
Checked By: GK
Design By: SG


Sheet Title:
**TRIBAL HERITAGE CENTRE
ACCOMMODATION BLOCK
(SHEET 02 OF 02)**

Date: 30-08-2024
Scale: 1:200
Drawing No.: A-232409-B2-01-02

Project No.: A-232409
A1 R0

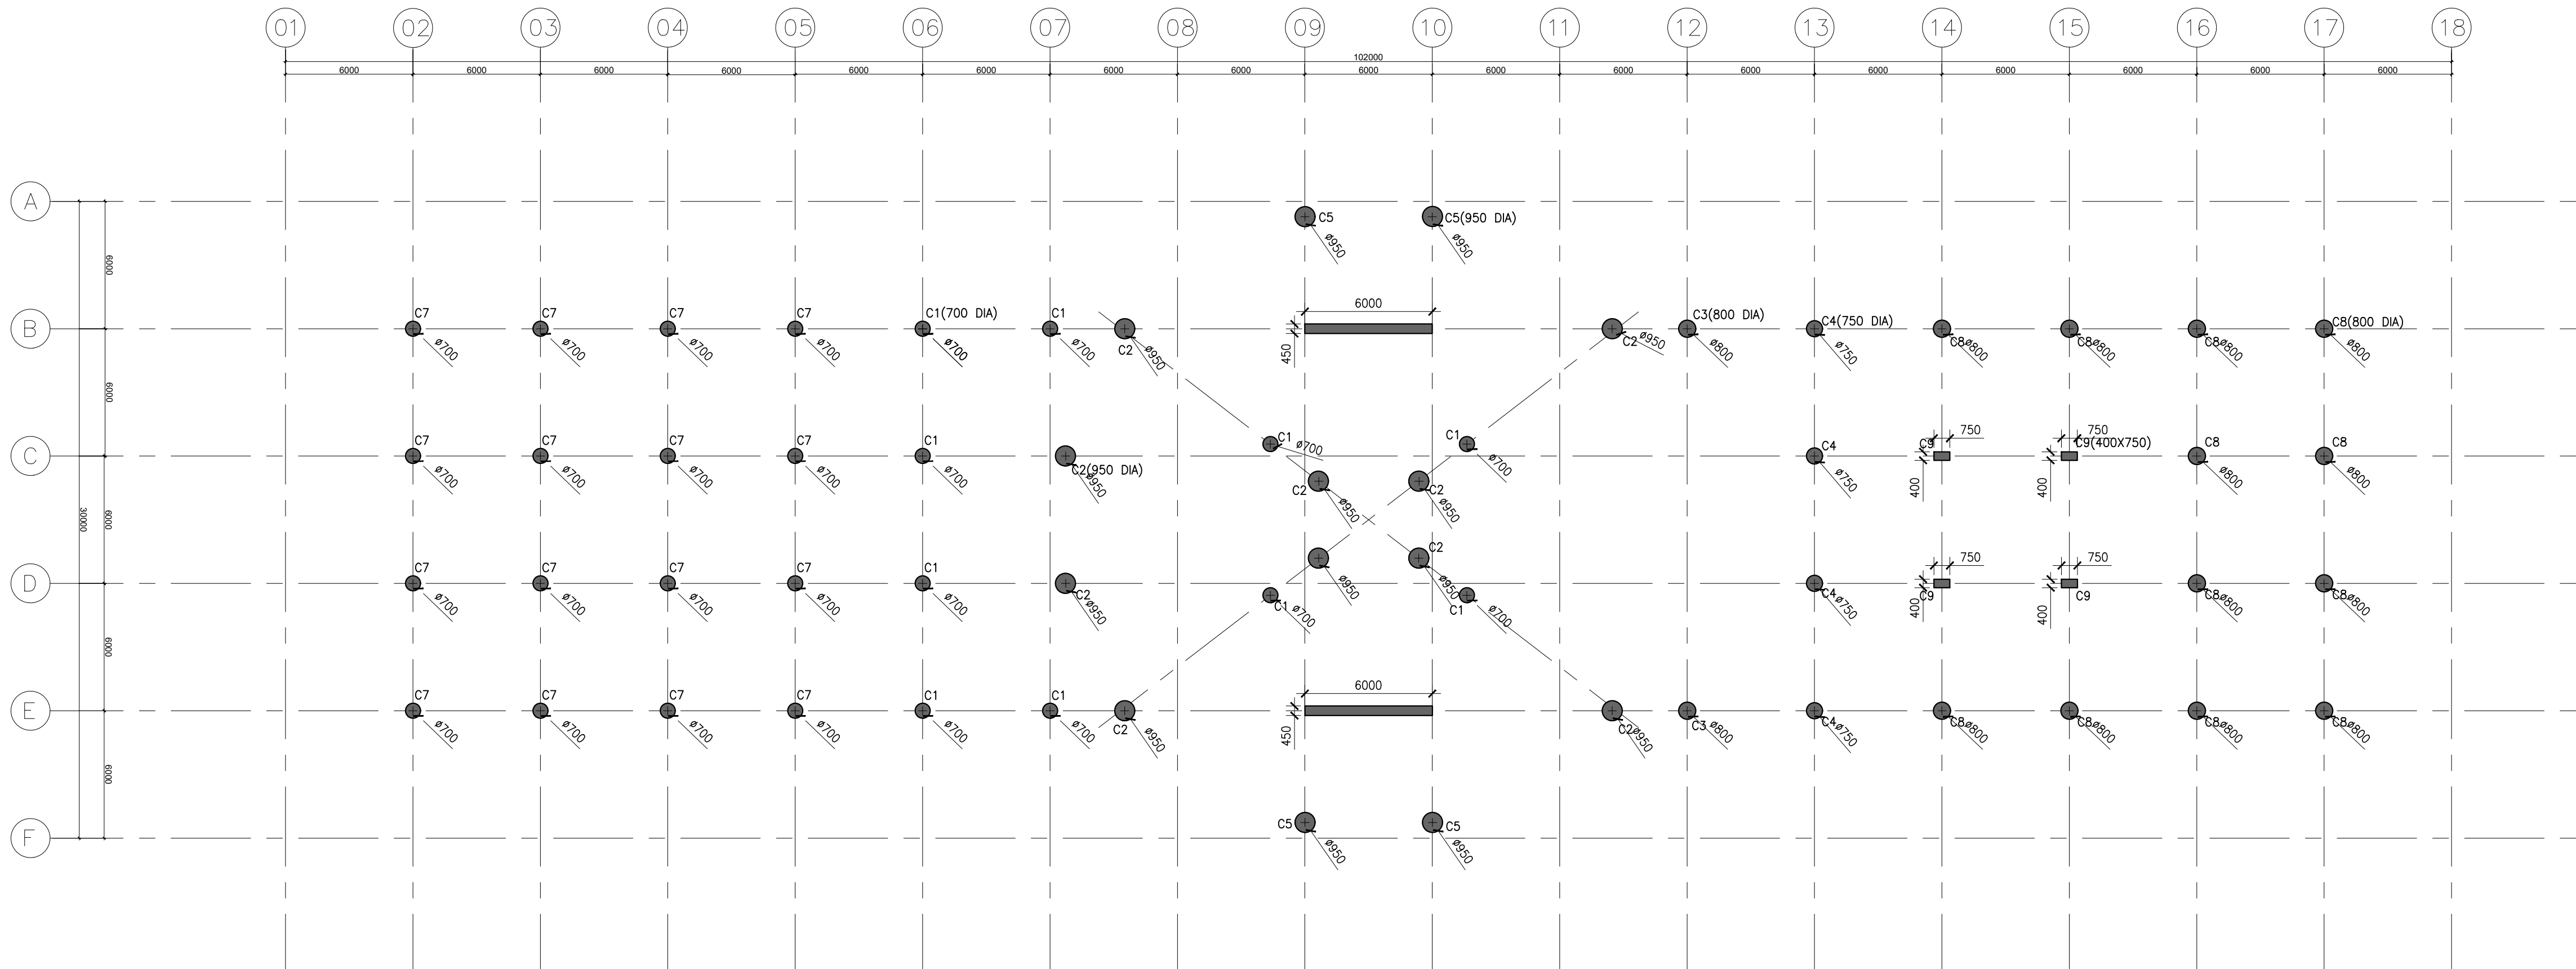

USABLE TERRACE PLAN AT +9850 LVL.

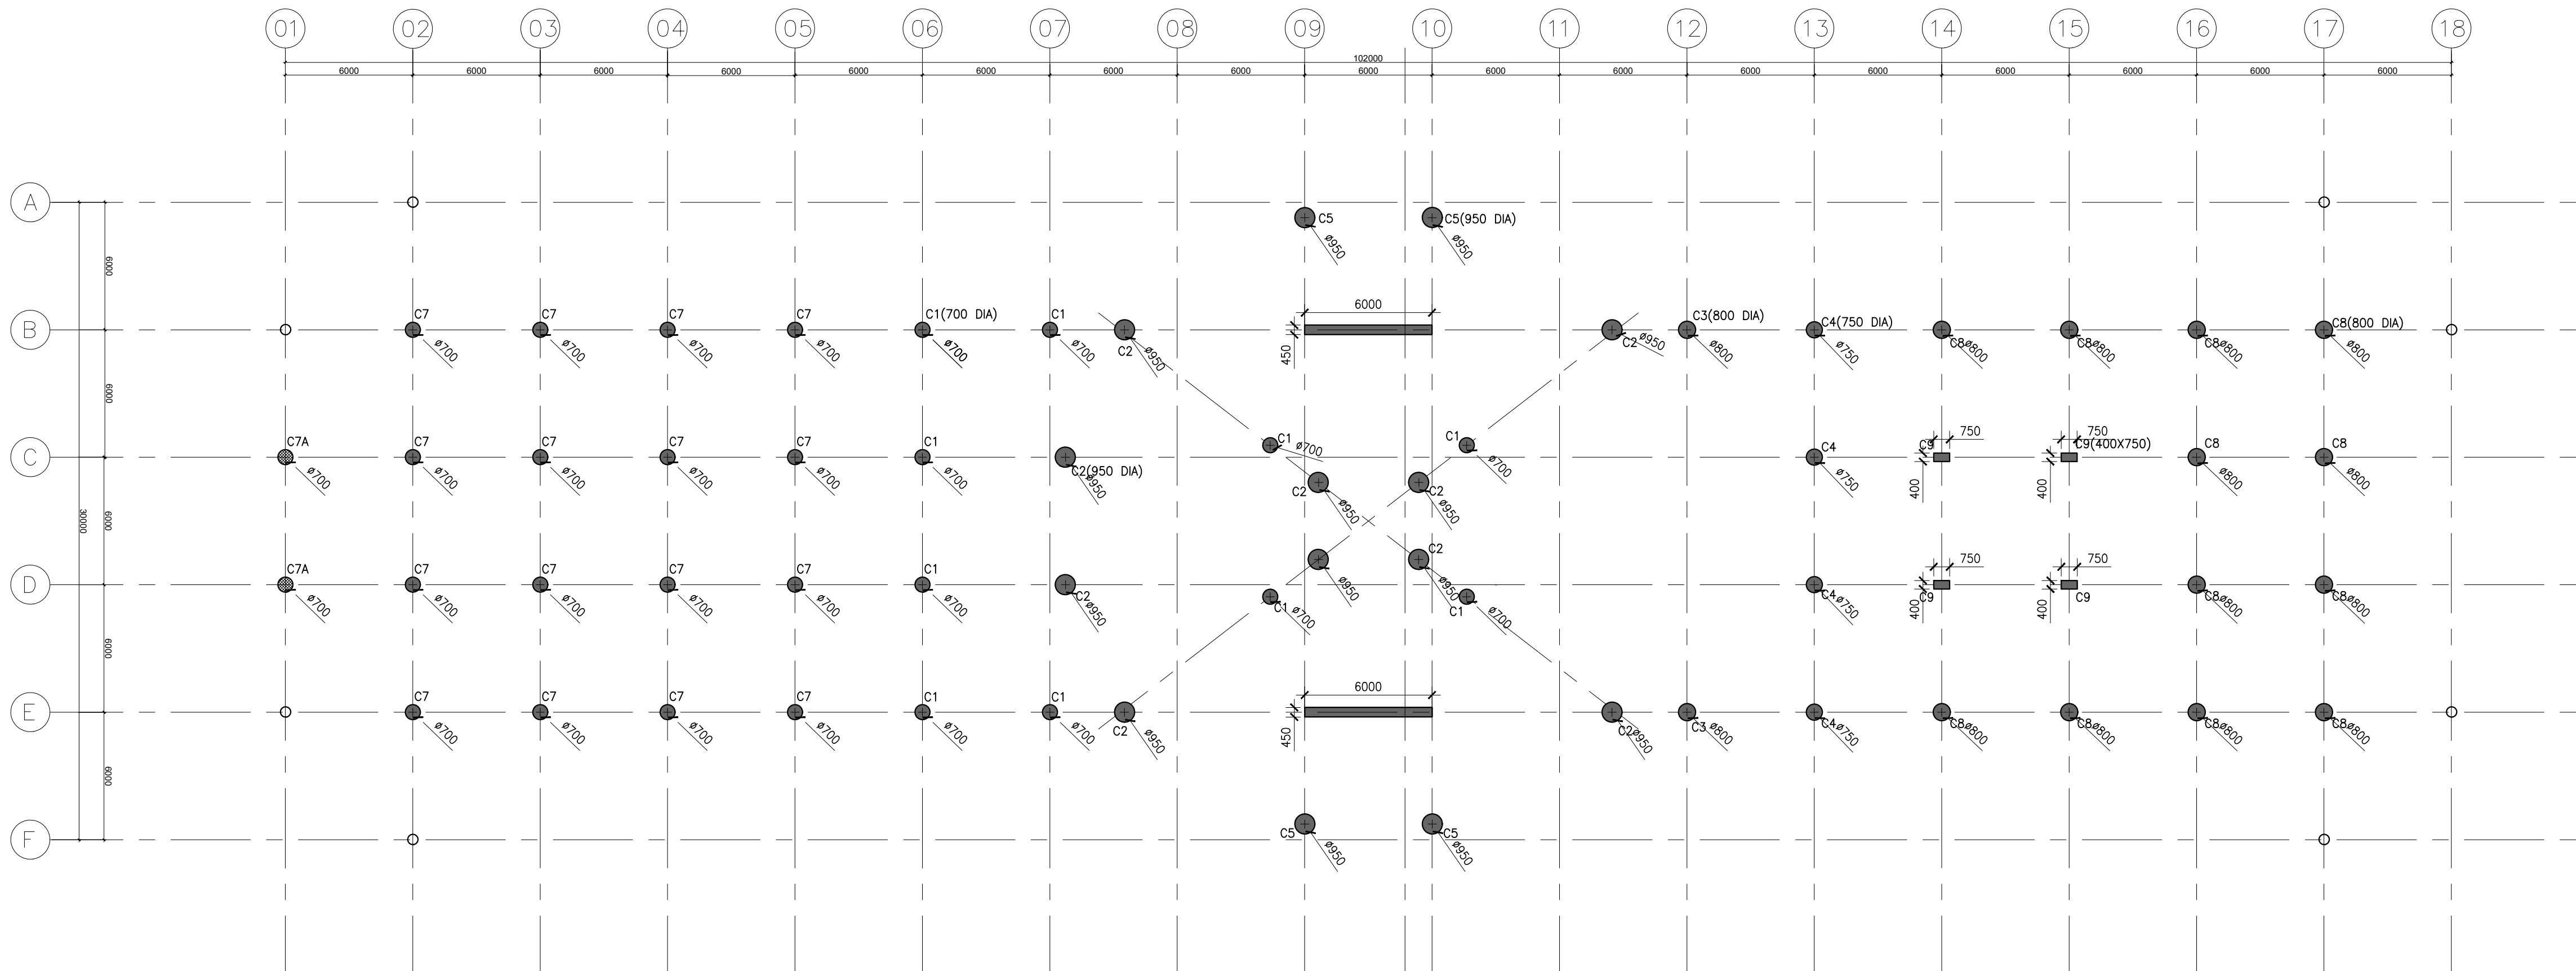

GROUND FLOOR PLAN AT +3850 LVL.

This approval is based on review of the submitted structural modeling, analysis and design of the structure under reference and it does not absolve the structural design engineer of his responsibility regarding correctness, adequacy, accuracy and safety of the design and drawings and nor does it relieve him from any of his contractual obligations.

Dr. Bhupinder Singh
Dr. Bhupinder Singh
Principal
Department of Civil Engineering
Noida Institute of Engineering & Technology
Noida-201301 (U.P.)

Sept. 23, 2024

RELEASED FOR
CONSTRUCTION
20.09.2024
TECHNICAL PROJECTS
CONSULTANTS
NODA-INDIA

NOTES:

- DO NOT SCALE THE DRAWING. FOLLOW ONLY FIGURED DIMENSIONS.
- ALL DIMENSIONS GIVEN IN THIS DRAWING ARE IN MILLIMETERS UNLESS NOTED OTHERWISE.
- ALL DIMENSIONS TO BE VERIFIED ON SITE AND APPROVED BY THE SITE ENGINEER.
- ANY DISCREPANCY OR AMBIGUITY IN THE DRAWINGS SHOULD IMMEDIATELY BE BROUGHT TO NOTICE OF THE ARCHITECT.
- ALL DRAWINGS SHOULD BE READ IN CONJUNCTION WITH OTHER RELEVANT ARCHITECTURAL, STRUCTURAL, PLUMBING, MECHANICAL AND ELECTRICAL DRAWINGS.
- THE '0' REFERS TO LEVEL ESTABLISHED AT SITE IN PRESENCE OF THE SITE SUPERVISOR AND THE ARCHITECT. ALL REMAINING LEVELS ARE RELATIVE TO THIS LEVEL.
- THIS DRAWING IS THE COPYRIGHT OF ARCHOHM CONSULTANTS AND MUST NOT BE RETAINED, COPIED OR USED WITHOUT THEIR AUTHORITY.

REVISIONS

No.	Date	Descriptions	Revision by

Client:

MEGHALAYAN AGE LIMITED (MAL)

Project:

TRIBAL HERITAGE CENTRE, MANDALGRE, MEGHALAYA

Architects:



Structural Consultants:

TPC TECHNICAL PROJECTS
CONSULTANTS PVT. LTD.
G-28C, Sector-8, Noida - 201301 (U.P.)
Mobile: +91 93120 42 40 300
Fax: +91 93120 42 40 300
Email: mail@archohm.com
www.archohm.com

Electrical Consultants:

ARCHOHM CONSULTANT
PVT. LTD.
G-28C, Sector-8, Noida - 201301 (U.P.)
Mobile: +91 93120 42 40 300
Fax: +91 93120 42 40 300
Email: mail@archohm.com
www.archohm.com

P&E Consultants:

WAC Engineers
INDIA PVT. LTD.
MEP Consultants &
Project Managers
B-76 Sector-6, Noida-201301
Ph: +91 93120 42 40 300
E-mail: wac@wacindia.com

Drawn By:

SJ

Checked By:

GK

Design By:

SG

Sheet Title:

EXHIBITION & RESEARCH CENTRE
GROUND FLOOR PLAN AT +3850 LVL.
USABLE TERRACE PLAN AT +9850 LVL.

COLUMN LAYOUT PLANS

Date:

20.09.2024

Drawing No:

2024-024-S-02.1

Scale:


1:200

Project No:

2024-024

Sheet No:

A1 R0

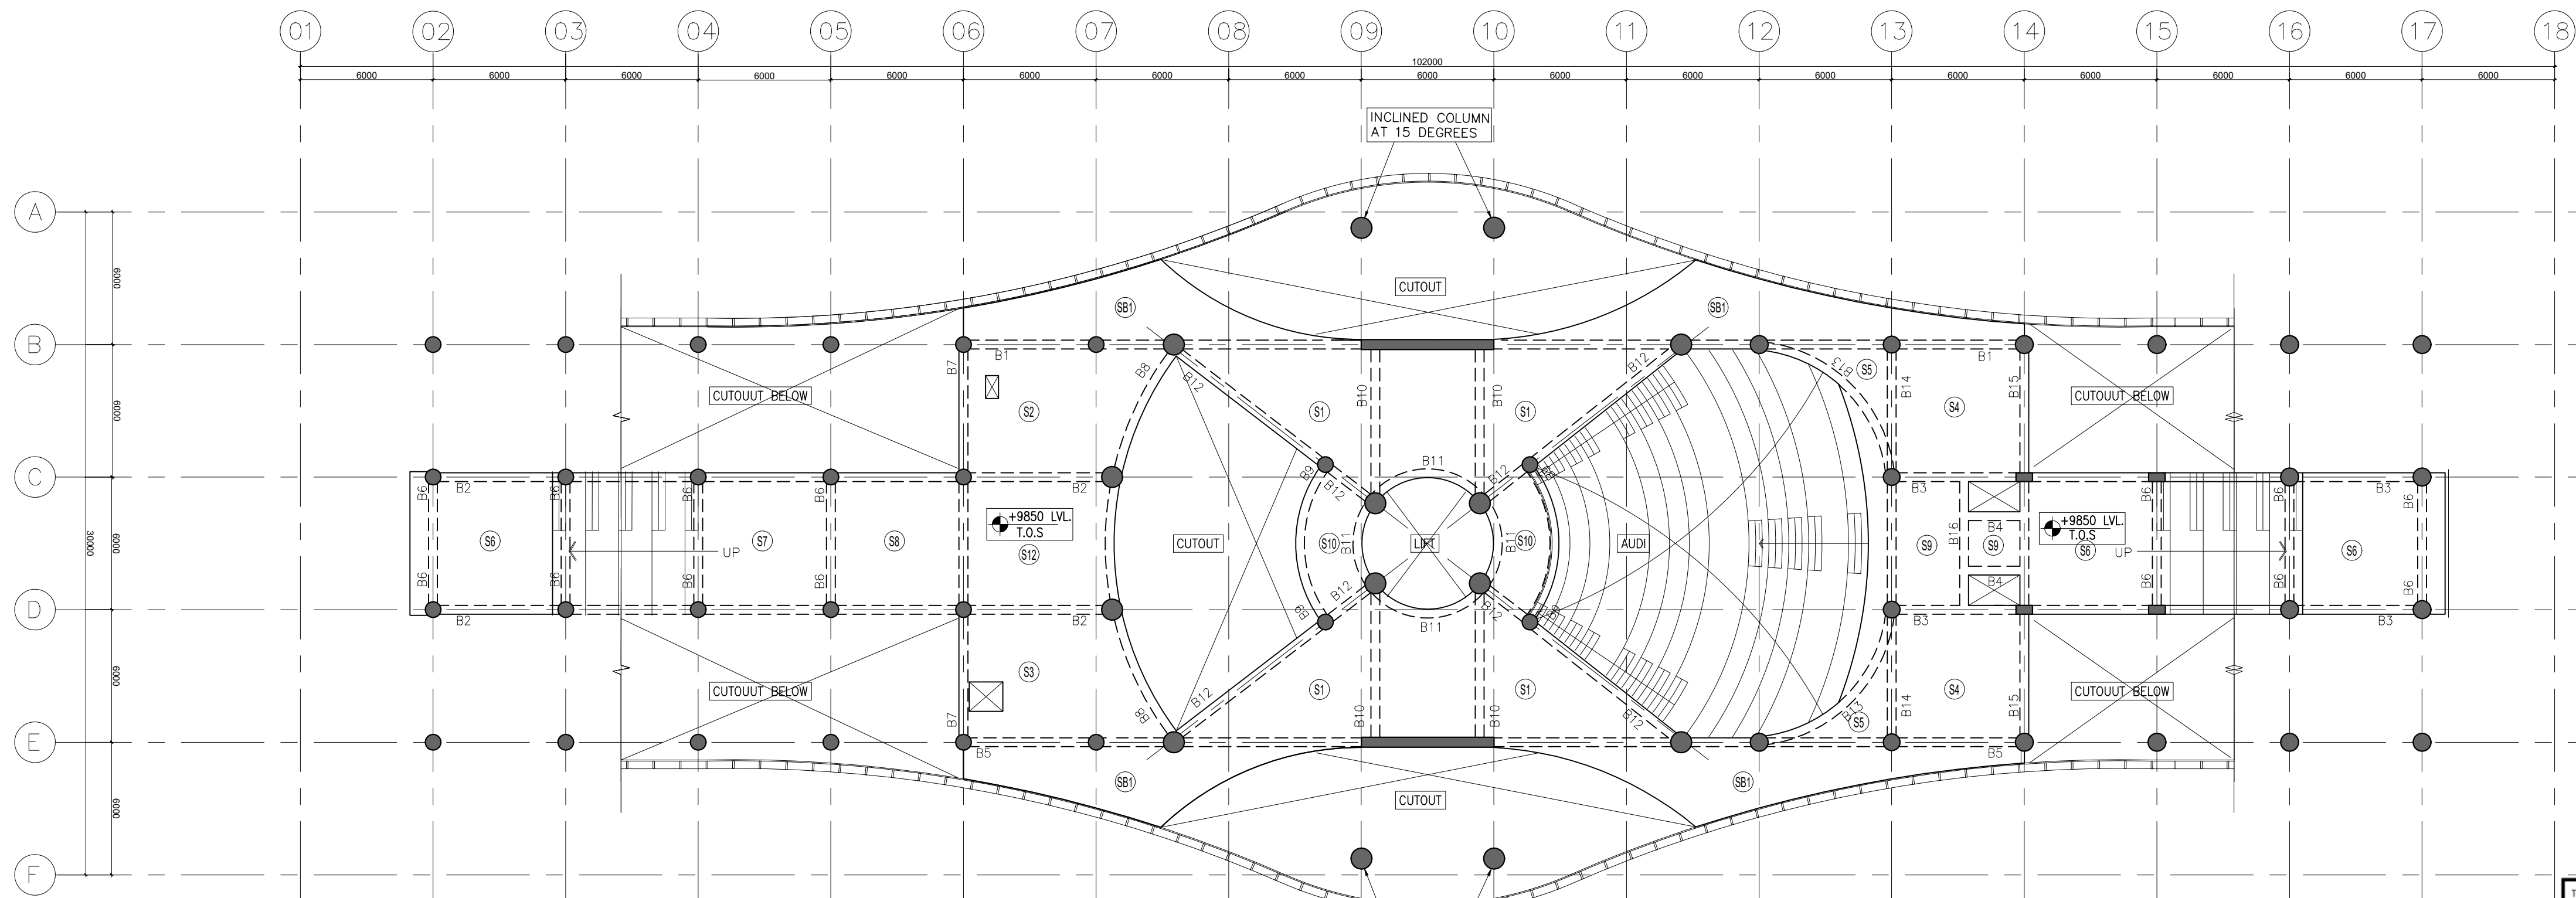

ALL BEAM SIZE 400X600
ALL SLAB 225mm THK. U.N.O.
USABLE TERRACE PLAN AT +9850 LVL.

SLAB THK. SCHEDULE	
SLAB MARK	SLAB THICKNESS
(S1)	260mm
(S2)	280mm
(S3)	280mm
(S4)	200mm
(S5)	200mm
(S6)	250mm
(S7)	240mm
(S8)	225mm
(S9)	125mm
(S10)	125mm
(S11)	200mm
(S12)	225mm
(S13)	350mm


BEAM SIZE SCHEDULE	
BEAM MARK	BEAM SIZE
B1	400x600
B2	400x600
B3	400x600
B4	400x600
B5	400x600
B6	400x600
B7	400x600
B8	400x600
B9	400x600
B10	400x600
B11	400x600
B12	400x600
B13	400x600
B14	400x600
B15	400x600
B16	400x600

This approval is based on review of the submitted structural modeling, analysis and design of the structure under reference and it does not absolve the structural design engineer of his responsibility regarding correctness, adequacy, accuracy and safety of the design and drawings and nor does it relieve him from any of his contractual obligations.

Dr. Bhupinder Singh
Professor
Department of Civil Engineering
Indian Institute of Technology - Roorkee
Roorkee 247 667 Uttarakhand, India

Sept. 23, 2024

RELEASED FOR
CONSTRUCTION
20-09-2024
TECHNICAL PROJECTS
CONSULTANTS
NOIDA-INDIA

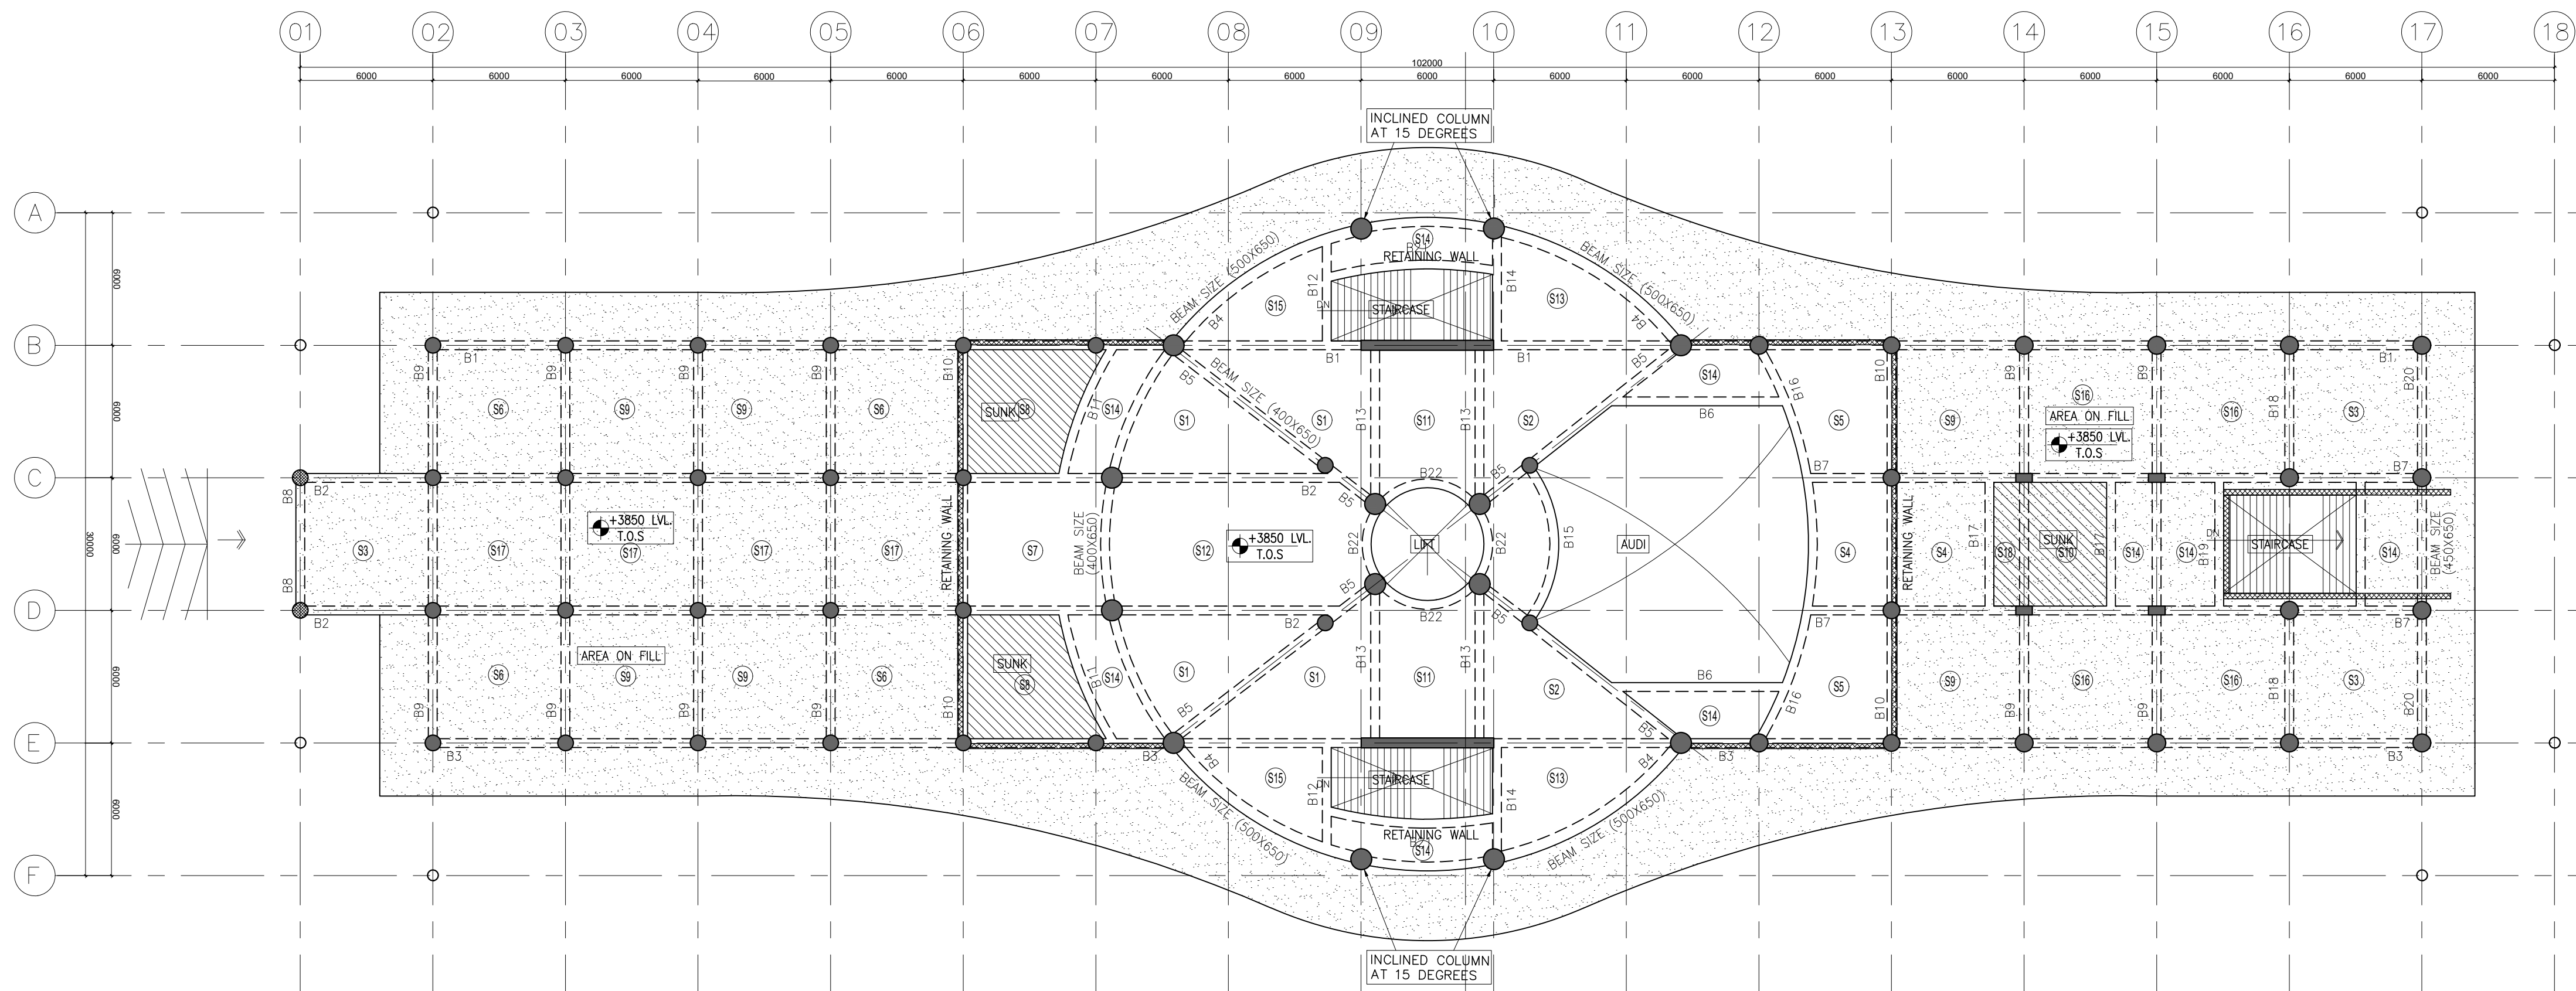

ALL BEAM SIZE 400X600 U.N.O.
ALL SLAB 225mm THK. U.N.O.
GROUND FLOOR PLAN AT +3850 LVL.

SLAB THK. SCHEDULE	
SLAB MARK	SLAB THICKNESS
(S1)	225mm
(S2)	250mm
(S3)	225mm
(S4)	150mm
(S5)	200mm
(S6)	200mm
(S7)	225mm
(S8)	240mm
(S9)	200mm
(S10)	200mm
(S11)	175mm
(S12)	260mm
(S13)	200mm
(S14)	150mm
(S15)	175mm
(S16)	210mm
(S17)	175mm
(S18)	125mm

BEAM SIZE SCHEDULE	
BEAM MARK	BEAM SIZE
B1	400x600
B2	400x600
B3	400x600
B4	400/500x650
B5	400x650
B6	400x600
B7	400x600
B8	400x600
B9	400x600
B10	400x600
B11	400x600
B12	400x600
B13	400x600
B14	400x600
B15	400x600
B16	400x600
B17	400x600
B18	400x600
B19	400x600
B20	400/450x650
B21	400x600

NOTES:

- DO NOT SCALE THE DRAWING, FOLLOW ONLY FIGURED DIMENSIONS.
- ALL DIMENSIONS GIVEN IN THIS DRAWING ARE IN MILLIMETERS UNLESS NOTED OTHERWISE.
- ALL DIMENSIONS TO BE VERIFIED ON SITE AND APPROVED BY THE SITE ENGINEER.
- ANY DISCREPANCY OR AMBIGUITY IN THE DRAWINGS SHOULD IMMEDIATELY BE BROUGHT TO NOTICE OF THE ARCHITECT.
- ALL DRAWINGS SHOULD BE READ IN CONJUNCTION WITH OTHER RELEVANT ARCHITECTURAL, STRUCTURAL, PLUMBING, MECHANICAL AND ELECTRICAL DRAWINGS.
- THE 'U' REFERS TO LEVEL ESTABLISHED AT SITE IN PRESENCE OF THE SITE SUPERVISOR AND THE ARCHITECT. ALL REMAINING LEVELS ARE RELATIVE TO THIS LEVEL.
- THIS DRAWING IS THE COPYRIGHT OF ARCHOHM CONSULTANTS AND MUST NOT BE RETAINED, COPIED OR USED WITHOUT THEIR AUTHORITY.

REVISIONS

No.	Date	Descriptions	Revision by

Client:

MEGHALAYAN AGE LIMITED (MAL)

Project:

TRIBAL HERITAGE CENTRE, MANDALGRE, MEGHALAYA

Architects:

ARCHOHM
ARCHITECTURAL CONSULTANTS
PVT. LTD.
G-285, Sector-8, Noida - 201301 (UP)
P: 91 120 48 40 300
F: 91 120 42 40 788
mail@archohm.com
www.archohm.com

Structural Consultants:

TPC TECHNICAL PROJECTS
CONSULTANTS PVT. LTD.
H-10, B-14, Sector 07, Noida, Uttar Pradesh-201301
P: 0120-2610000
www.tpcindia.com

Electrical Consultants:

ARCHOHM CONSULTANT
PVT. LTD.
G-285, Sector-8, Noida - 201301 (UP)
P: 91 120 48 40 300
F: 91 120 42 40 788
mail@archohm.com
www.archohm.com

P&E Consultants:

WAC Engineers
INDIA PVT. LTD.
MEP Consultants & Project Managers
G-76, Sector-6, Noida - 201301 (UP)
P: 0120-4504865
E: mail@wacindia.com

Drawn By:

SJ

Checked By:

GK

Design By:

SG

Sheet Title:

EXHIBITION & RESEARCH CENTRE
GROUND FLOOR PLAN AT +3850 LVL.
USABLE TERRACE PLAN AT +9850 LVL.
FRAMING PLANS

Date:

20.09.2024

Drawing No.:

2024-024-S-04.0

Scale:

1:200


Project No.:

2024-024


Sheet No.:

A1

R/O

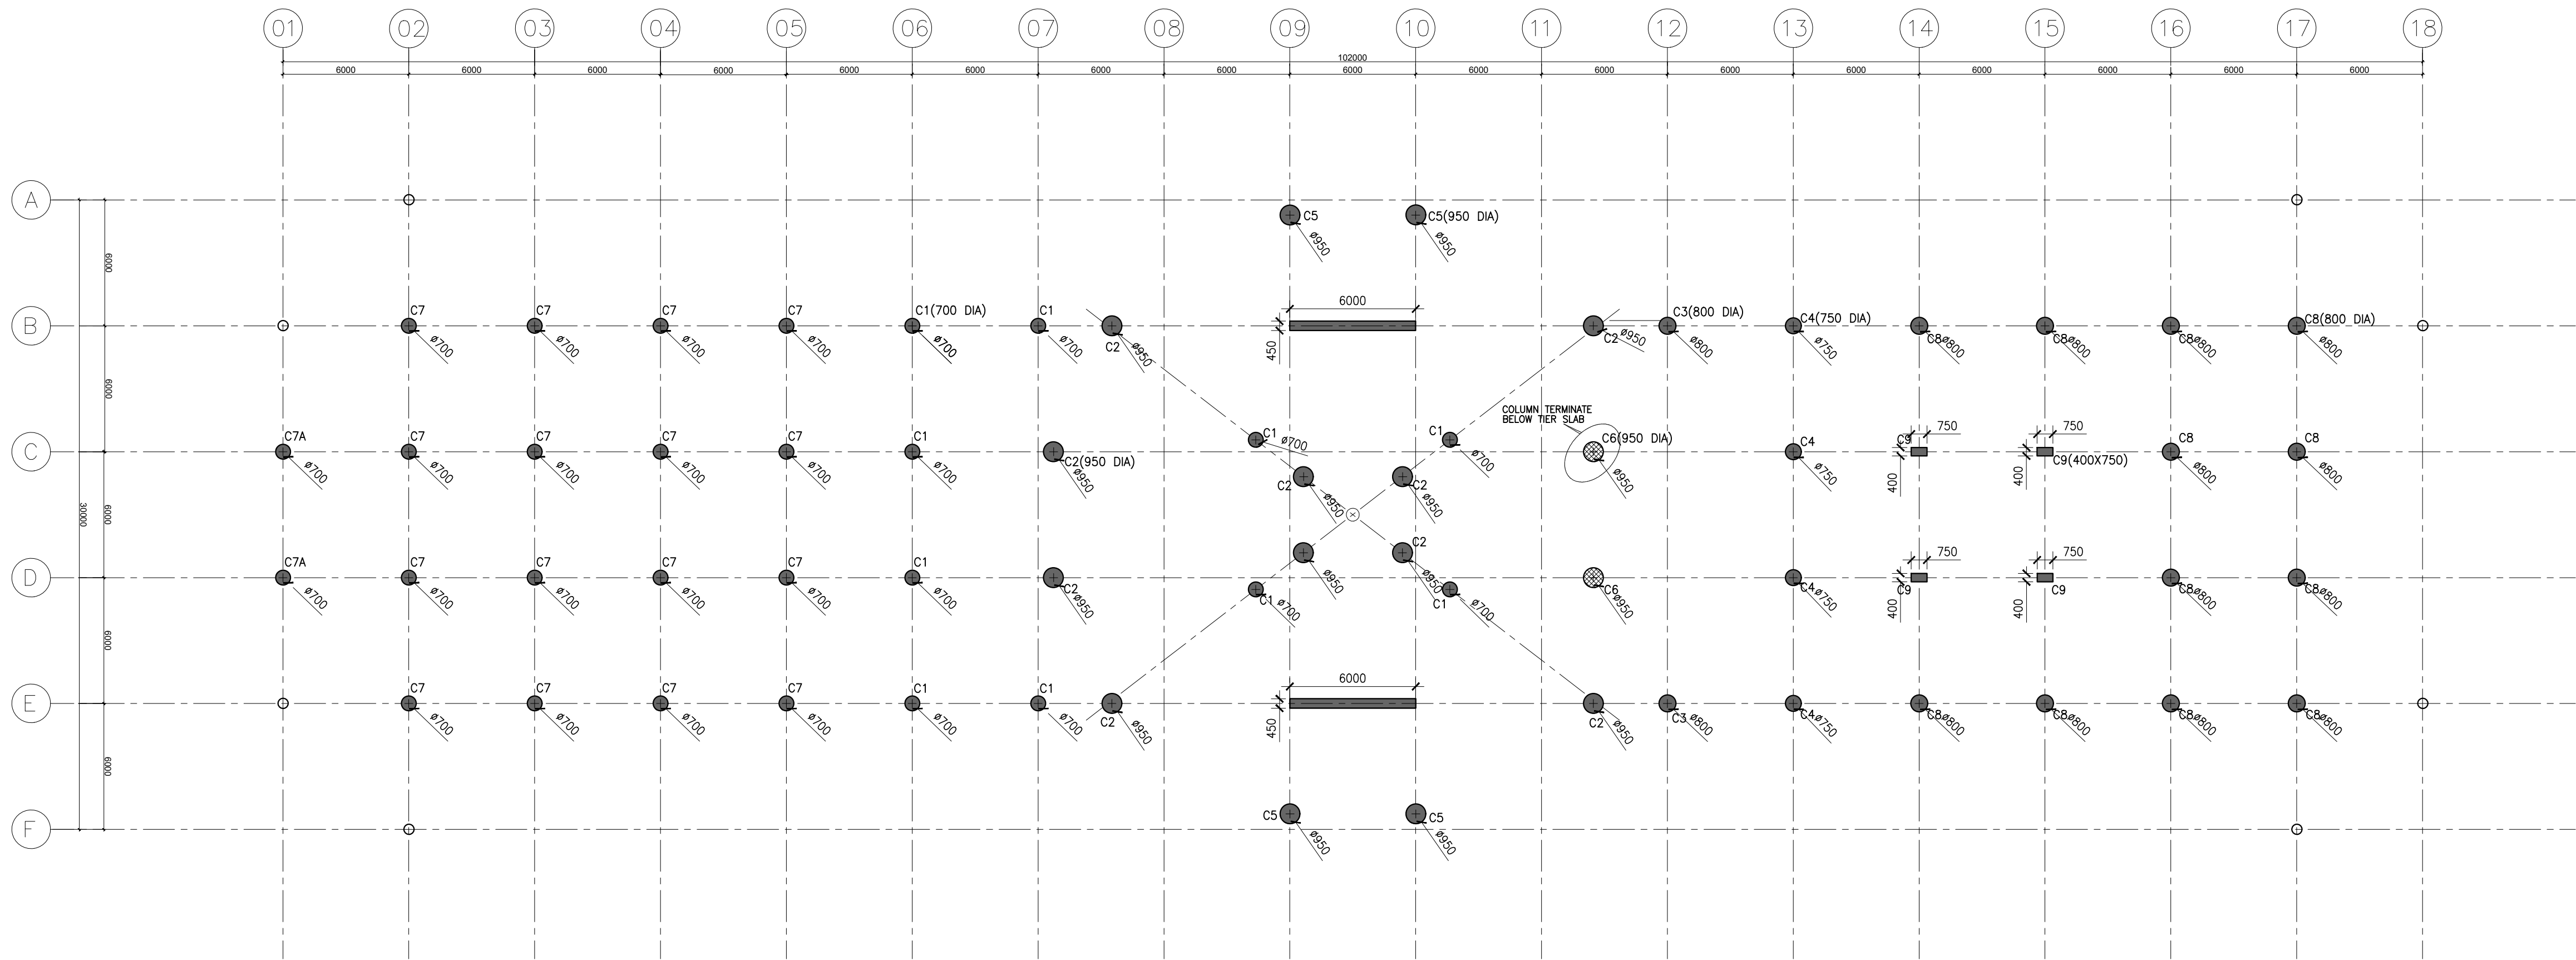

LOWER GROUND FLOOR PLAN AT ±0.00 LVL.

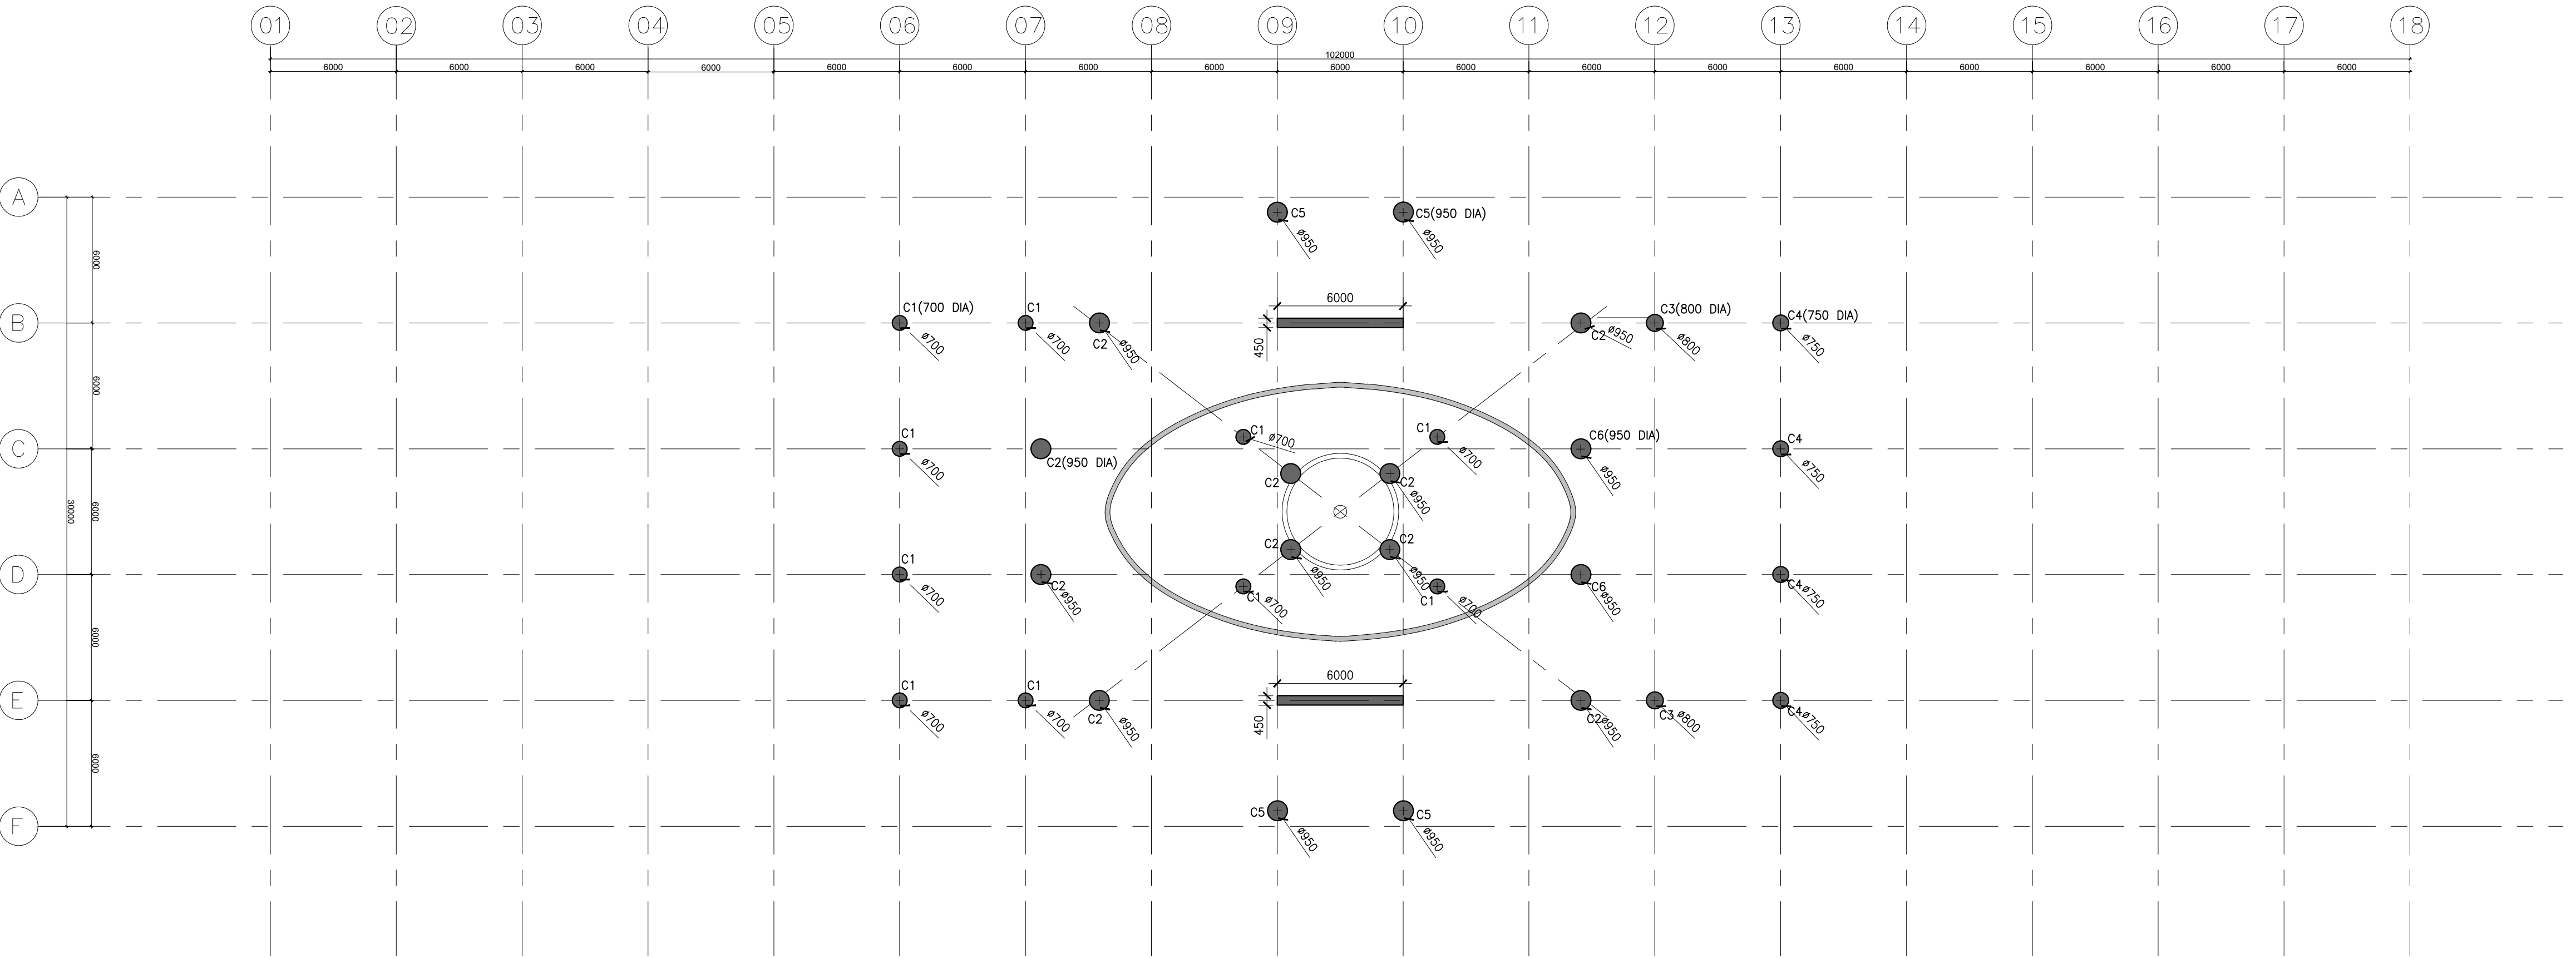

SERVICE FLOOR PLAN AT -2700 LVL.

This approval is based on review of the submitted structural modeling, analysis and design of the structure under reference and it does not absolve the structural design engineer of his responsibility regarding correctness, adequacy, accuracy and safety of the design and drawings and nor does it relieve him from any of his contractual obligations.

Bhupinder Singh
Dr. Bhupinder Singh
Professor
Department of Civil Engineering
Indian Institute of Technology (IIT) Roorkee
Roorkee, Uttarakhand, India

Sept. 23, 2024

RELEASED FOR
CONSTRUCTION
20-09-2024
TECHNICAL PROJECTS
CONSULTANTS
NOIDA, INDIA

NOTES:

- DO NOT SCALE THE DRAWING. FOLLOW ONLY FIGURED DIMENSIONS.
- ALL DIMENSIONS GIVEN IN THIS DRAWING ARE IN MILLIMETERS UNLESS NOTED OTHERWISE.
- ALL DIMENSIONS TO BE VERIFIED ON SITE AND APPROVED BY THE SITE ENGINEER.
- ANY DISCREPANCY OR AMBIGUITY IN THE DRAWINGS SHOULD IMMEDIATELY BE BROUGHT TO NOTICE OF THE ARCHITECT.
- ALL DRAWINGS SHOULD BE READ IN CONJUNCTION WITH OTHER RELEVANT ARCHITECTURAL, STRUCTURAL, PLUMBING, MECHANICAL AND ELECTRICAL DRAWINGS.
- THE '0' REFERS TO LEVEL ESTABLISHED AT SITE IN PRESENCE OF THE SITE SUPERVISOR AND THE ARCHITECT. ALL REMAINING LEVELS ARE RELATIVE TO THIS LEVEL.
- THIS DRAWING IS THE COPYRIGHT OF ARCHOHM CONSULTANTS AND MUST NOT BE RETAINED, COPIED OR USED WITHOUT THEIR AUTHORITY.

REVISIONS

No.	Date	Descriptions	Revision by

Client:

MEGHALAYAN AGE LIMITED (MAL)

Project:

TRIBAL HERITAGE CENTRE, MANDALGRE, MEGHALAYA

Architects:



Structural Consultants:

TPC TECHNICAL PROJECTS CONSULTANTS PVT. LTD.
B-10, B-11, Sector 17, Gurgaon, Haryana
Gurgaon, Haryana
Phone: 0122-4444444
Email: info@tpcconsultants.com

Electrical Consultants:

ARCHOHM CONSULTANTS PVT. LTD.
B-10, B-11, Sector 17, Gurgaon, Haryana
Gurgaon, Haryana
Phone: 0122-4444444
Email: info@archohm.com

P&E Consultants:

WAC Engineers INDIA PVT. LTD.
MEP Consultants & Project Managers
B-76, Sector 17, Gurgaon, Haryana
Gurgaon, Haryana
Phone: 0122-4444444
Email: info@wacengineers.com

Drawn By:

JK

Checked By:

BHARTH

Design By:

OSHEEN

Sheet Title:

EXHIBITION & RESEARCH CENTRE
SERVICE FLOOR PLAN AT -2700 LVL.
LOWER GROUND FLOOR PLAN AT ±0.00 LVL.
COLUMN LAYOUT PLANS

Date:

20.09.2024

Drawing No.:

2024-024-S-02.0

Scale:


1:200

Project No.:

2024-024

Sheet No.:

A1 R0

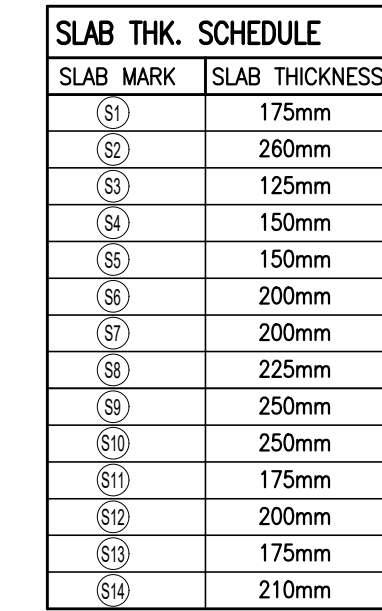


BEAM SIZE SCHEDULE	
BEAM MARK	BEAM SIZE
B1	400x600
B2	400x600
B3	400x600
B4	400x600
B5	400x600
B6	400x600
B7	400x600
B8	400x600
B9	400x600
B10	400x600
B11	400x600
B12	400x600
B13	400x600
B14	400x600

This approval is based on review of the submitted structural modeling, analysis and design of the structure under reference and it does not absolve the structural design engineer of his responsibility regarding correctness, adequacy, accuracy and safety of the design and drawings and nor does it relieve him from any of his contractual obligations.


Dr. Bhupinder Singh
Professor
Department of Civil Engineering
Indian Institute of Technology (Kharagpur) Bhubaneswar
Bhubaneswar 751 013, Odisha, INDIA

Sept. 23, 2024

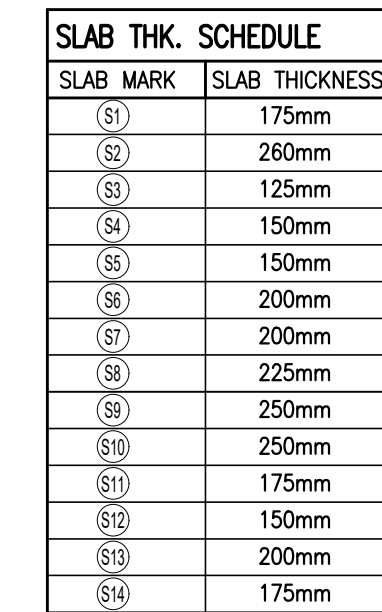

BEAM SIZE SCHEDULE	
BEAM MARK	BEAM SIZE
B1	400x600
B2	400x600
B3	400x600
B4	500x650
B5	400x600
B6	400x600
B7	400x600
B8	400x600
B9	400x600
B10	400x600
B11	400x600
B12	400x600
B13	400x600

ALL SLAB 225mm THK. U.N.O
ALL BEAM ARE UPTURN AT THIS LVL.
SERVICE FLOOR PLAN AT -2700 LVL.

1. DO NOT SCALE THE DRAWING. FOLLOW ONLY FIGURED DIMENSIONS.
2. ALL DIMENSIONS GIVEN IN THIS DRAWING ARE IN MILLIMETERS UNLESS NOTED OTHERWISE.
3. ALL DIMENSIONS TO BE VERIFIED ON SITE AND APPROVED BY THE SITE ENGINEER.
4. ANY DISCREPANCY OR AMBIGUITY IN THE DRAWINGS SHOULD IMMEDIATELY BE BROUGHT TO NOTICE OF THE ARCHITECT.
5. ALL DRAWINGS SHOULD BE READ IN CONJUNCTION WITH OTHER RELEVANT ARCHITECTURAL, STRUCTURAL, PLUMBING, MECHANICAL AND ELECTRICAL DRAWINGS.
6. ALL DIMENSIONS TO LEVEL ESTABLISHED AT SITE IN PRESENCE OF THE SITE SUPERVISOR AND THE ARCHITECT. ALL REMAINING LEVELS ARE RELATIVE TO THIS LEVEL.
7. THIS DRAWING IS THE COPYRIGHT OF ARCHOCH CONSULTS AND MUST NOT BE RETAINED, COPIED OR USED WITHOUT THEIR AUTHORITY.

[illegible]

Project: **TRIBAL HERITAGE CENTRE, MANDALGRE, MEGHALAYA**

ARCHHM
ARCHITECTURE
ENGINEERING
URBANISM
INTERIORS

TPC TECHNICAL PROJECTS CONSULTANTS(P)LTD.
H.O. B-74, sector 57, noide, ufar
pradesh-201301(india)
BOARD NO.-91-120-4306800

Electrical Consultants:
 **ARCHOHM CONSULTANTS
PVT. LTD.**
3C-28C, SECTOR-8, NOIDA - 201301 (UP)
T 91 120 46 40 300 F 91 120 42 46 788
mail@archohm.com www.archohm.com

WAC Engineers
INDIA PVT. LTD.
MEP Consultants &
Project Managers
B-78, Sector-6, Noida, UP-201305
Ph: 0120-4504693,
E-mail: wac@wacmep.com

Drawn By	JK
Checked By	BHA
Design By	OSH

Sheet Title:	
EXHIBITION & RESEARCH CENTRE SERVICE FLOOR PLAN AT -2700 LVL. LOWER GROUND FLOOR PLAN AT ± 0.00 LVL. FRAMING PLANS	


Date: 20.09.2024	Scale: 1:200	Project N: 2024-0
Drawing No.: 2024-024-S-03.0		A1

A1	R0
----	----

This approval is based on review of the submitted structural modeling, analysis and design of the structure under reference and it does not absolve the structural design engineer of his responsibility regarding correctness, adequacy, accuracy and safety of the design and drawings and nor does it relieve him from any of his contractual obligations.


Dr. Bhupinder Singh
Professor
Department of Civil Engineering
Indian Institute of Technology - Kharagpur
Borewell 284 (Kharagpur) - 751005

Sept. 17, 2024

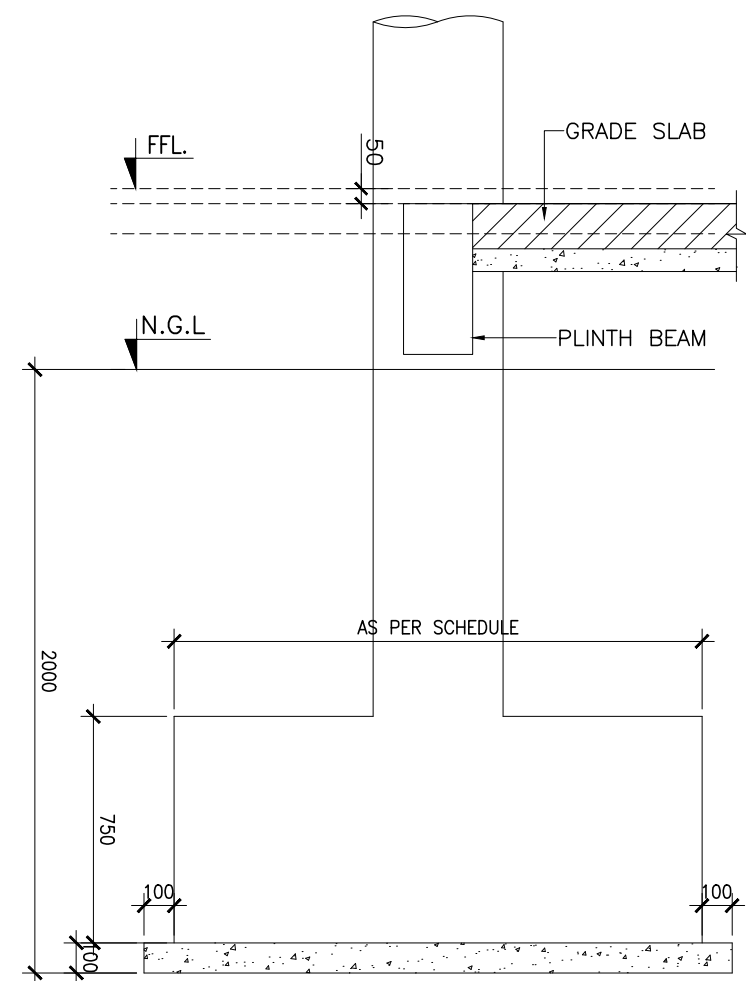

TYPICAL FOOTING SECTION

FOOTING NO.	SIZE		DEPTH
	Length(L) L	Breadth(B) B	
F1	1800	1800	750
F2	2200	2200	750
F3	2900	2900	750
F4	3000	3000	750
F5	3100	3100	750
F6	3200	3200	750
F7	3500	3500	750
F8	4000	4000	750
F9	3800	3800	750
F10	3500	3200	750
F11	4900	4900	750
F12	4400	4400	750
CF1	AS/PLAN	AS/PLAN	750
CF2	AS/PLAN	AS/PLAN	750
CF3	AS/PLAN	AS/PLAN	750

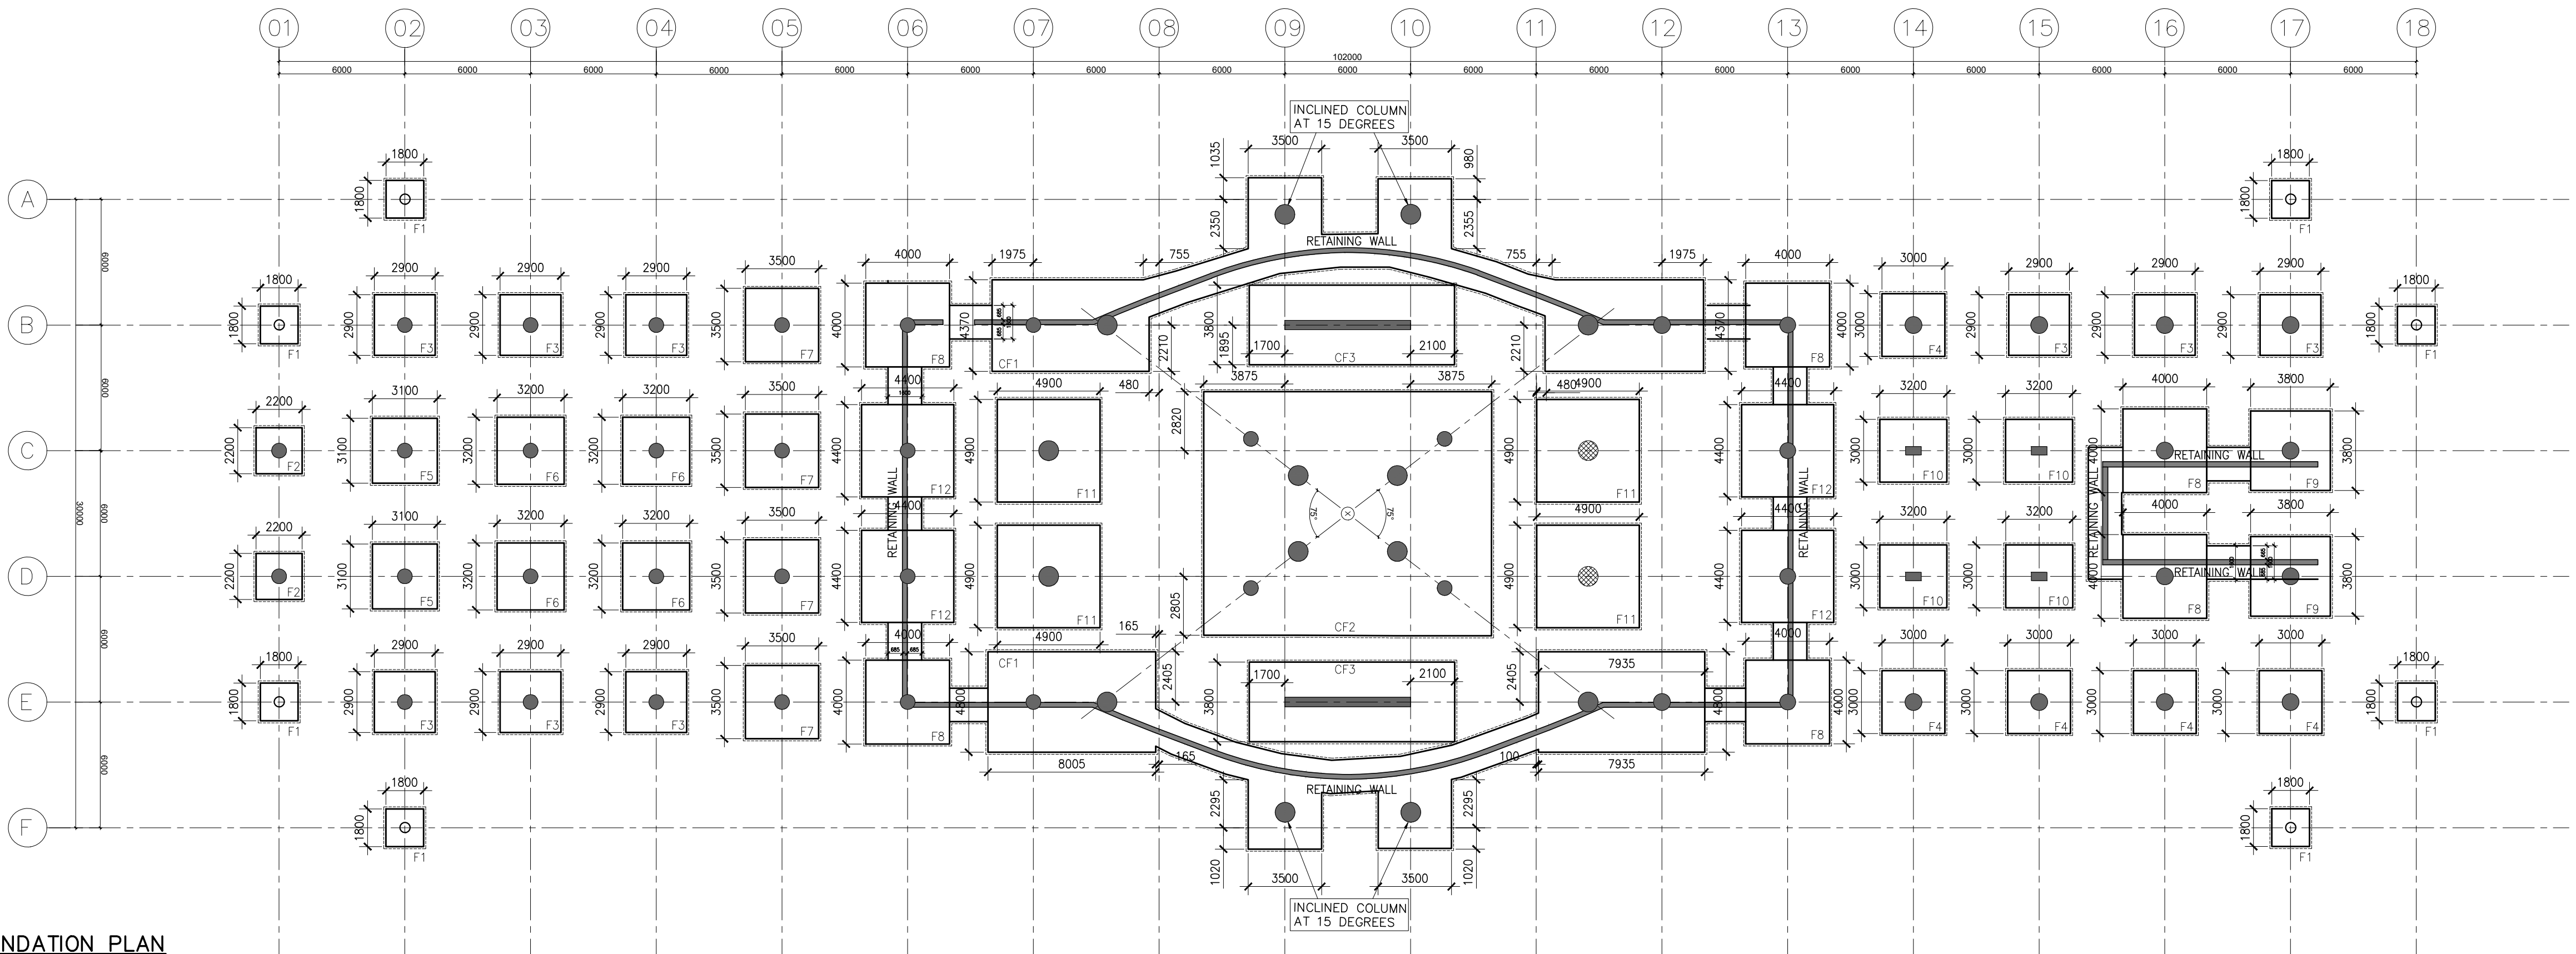

FOUNDATION PLAN
ALL FOOTINGS 750MM THK.

NOTES

- ALL DIMENSIONS AND LEVELS SHALL BE COMPARED WITH THE RELEVANT ARCHITECTURAL DRAWINGS AND DISCREPANCY IF ANY SHALL BE GOT RECONCILED BEFORE EXECUTION AT SITE.
 - FIGURED DIMENSIONS ONLY SHALL BE FOLLOWED.
 - ALL DIMENSIONS ARE IN mm UNLESS OTHERWISE SPECIFIED.
 - FOUNDATION BASE LEAN CONCRETE SHALL BE OF MIX 1:4:8(1 CEMENT:4 COARSE SAND: 8 GRADED STONE AGG.)
 - MIX OF CONCRETE SHALL BE:-
- | | |
|--------------------------------------|------|
| * COLUMN/SHEAR WALL AS PER SCHEDULE. | |
| * FOOTINGS | M-30 |
| * EXTENDED BASEMENT FOOTINGS | M-30 |
| * RETAINING WALL | M-30 |
| * TIE SLAB | M-30 |
6. CLEAR COVER TO MAIN REINF. FOR R.C.C MEMBERS SHALL BE AS UNDER:-
- | | |
|--------------|------|
| FOUNDATION'S | |
| BOTTOM | 50mm |
| TOP/SIDES | 40mm |
7. REINFORCEMENT SHALL BE IN FORM OF HIGH STRENGTH COLD ROLLED DEFORMED STEEL BARS OF GRADE Fe500ALL CONFORMING TO IS:1786-2008.
8. LAP LENGTH OF STEEL REINFORCING BARS SHALL BE:-

MIX OF CONCRETE	REINF.fe-500 BARS
M-20	57D
M-25	49D
M-30	45D
M-35	40D
M-40 & ABOVE	36D

- 'D' IS THE DIA OF REINF. BARS
- * RETAINING WALL IS DESIGNED SUPPORTED AT ROOF LEVEL.NO BACK FILL IS TO BE EXECUTED TILL RESPECTIVE ROOF IS CAST AND CURED.
 - * IN CASE OF EXTRA EXCAVATION FOUNDATION TO BE LAID ON WELL COMPACTED SOIL HAVING PROCTOR DENSITY OF MORE THAN 95% OR FILL ADDITIONAL EXCAVATED AREA WITH PCC 1:6:12.
 - * ALL ISOLATED FOOTINGS SYMMETRICAL TO ϕ OF COLUMNS.
 - * ALL COMBINED FOOTINGS SYMMETRICAL TO LINE JOINING ϕ OF COLUMNS.
 - * FOUNDATION TO BE PLACED ON FIRM NATURAL SOIL IF REQUIRED FOUNDING LEVEL TO BE LOWERED.
 - * INCASE OF OVERLAPPING OF EXTRA BARS SINGLE LENGTH BAR CAN BE PROVIDED.
 - * CO-ORDINATE LEVELS WITH ARCH DRG. BEFORE
 - * PROVIDE SLEEVES,INSERTS ETC, AS/SERVICE DRG.
 - *ANTITERMITE TREATMENT OT FOUNDATIONS AND PLINTH FILLING SHALL CONFORM TO IS :6313

NOTES

- DO NOT SCALE THE DRAWING, FOLLOW ONLY FIGURED DIMENSIONS.
- ALL DIMENSIONS GIVEN IN THIS DRAWING ARE IN MILLIMETERS UNLESS NOTED OTHERWISE.
- ALL DIMENSIONS TO BE VERIFIED ON SITE AND APPROVED BY THE SITE ENGINEER.
- ANY DISCREPANCY OR AMBIGUITY IN THE DRAWINGS SHOULD IMMEDIATELY BE BROUGHT TO NOTICE OF THE ARCHITECT
- ALL DRAWINGS SHOULD BE READ IN CONJUNCTION WITH OTHER RELEVANT ARCHITECTURAL, STRUCTURAL, PLUMBING, MECHANICAL AND ELECTRICAL DRAWINGS.
- THE 'D' REFERS TO LEVEL ESTABLISHED AT SITE IN PRESENCE OF THE SITE SUPERVISOR AND THE ARCHITECT. ALL REMAINING LEVELS ARE RELATIVE TO THIS LEVEL.
- THIS DRAWING IS THE COPYRIGHT OF ARCHOHM CONSULTANTS AND MUST NOT BE RETAINED, COPIED OR USED WITHOUT THEIR AUTHORITY.

REVISIONS

No.	Date	Descriptions	Revision by

Client:

MEGHALAYAN AGE LIMITED (MAL)

Project:

TRIBAL HERITAGE CENTRE, MANDALGRE, MEGHALAYA

Architects:



Structural Consultants:

TPC TECHNICAL PROJECTS CONSULTANTS PVT. LTD.
G-285, Sector-8, Noida - 201301 (UP)
P: 91 120 48 40 300
F: 91 120 42 40 788
mail@tpcarch.com www.tpcarch.com

Electrical Consultants:

ARCHOHM CONSULTANTS PVT. LTD.
G-285, Sector-8, Noida - 201301 (UP)
P: 91 120 48 40 300
F: 91 120 42 40 788
mail@archohm.com www.archohm.com

P&E Consultants:

WAC Engineers INDIA PVT. LTD.
MEP Consultants & Project Managers
G-76, Sector-8, Noida - 201301 (UP)
P: 91 120 48 40 300
F: 91 120 42 40 788
mail@wacengineers.com

Drawn By:

JK

Checked By:

BHARTH

Design By:

OSHEEN

Sheet Title:

EXHIBITION & RESEARCH CENTRE FOUNDATION PLAN & DETAILS

Date:

16-09-2024

Scale:

1:200

Project No.:

2024-024

Drawing No.:

2024-024-S-01.0


A1

R0


This approval is based on review of the submitted structural modeling, analysis and design of the structure under reference and it does not absolve the structural design engineer of his responsibility regarding correctness, adequacy, accuracy and safety of the design and drawings and nor does it relieve him from any of his contractual obligations.

Dr. Bhupinder Singh
Professor
Department of Civil Engineering
Indian Institute of Technology - Kharagpur
Bachchan 25/01/2024 (Approved)

Sept. 17, 2024

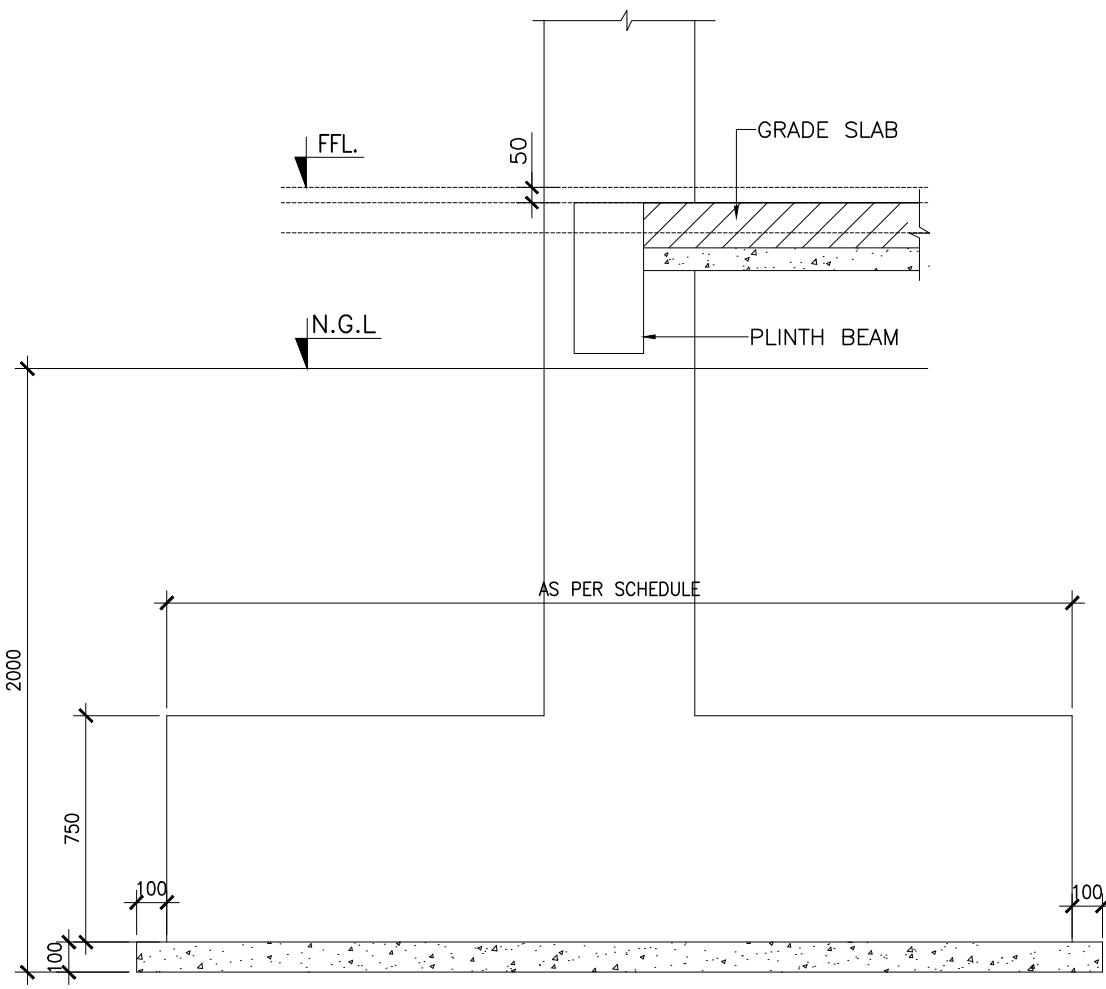

ISOLATED/COMBINED FOOTING SCHEDULE			
FOOTING NO.	SIZE		DEPTH
	Length(L)	Breadth(B)	
F1	3000	4600	650
F2	3000	4500	650
F3	2800	4200	650
F4	AS/PLAN	AS/PLAN	650
F5	AS/PLAN	AS/PLAN	650
F6	AS/PLAN	AS/PLAN	650
F7	AS/PLAN	AS/PLAN	650
F8	AS/PLAN	AS/PLAN	650
F9	AS/PLAN	AS/PLAN	650
MF1	2100	2100	650

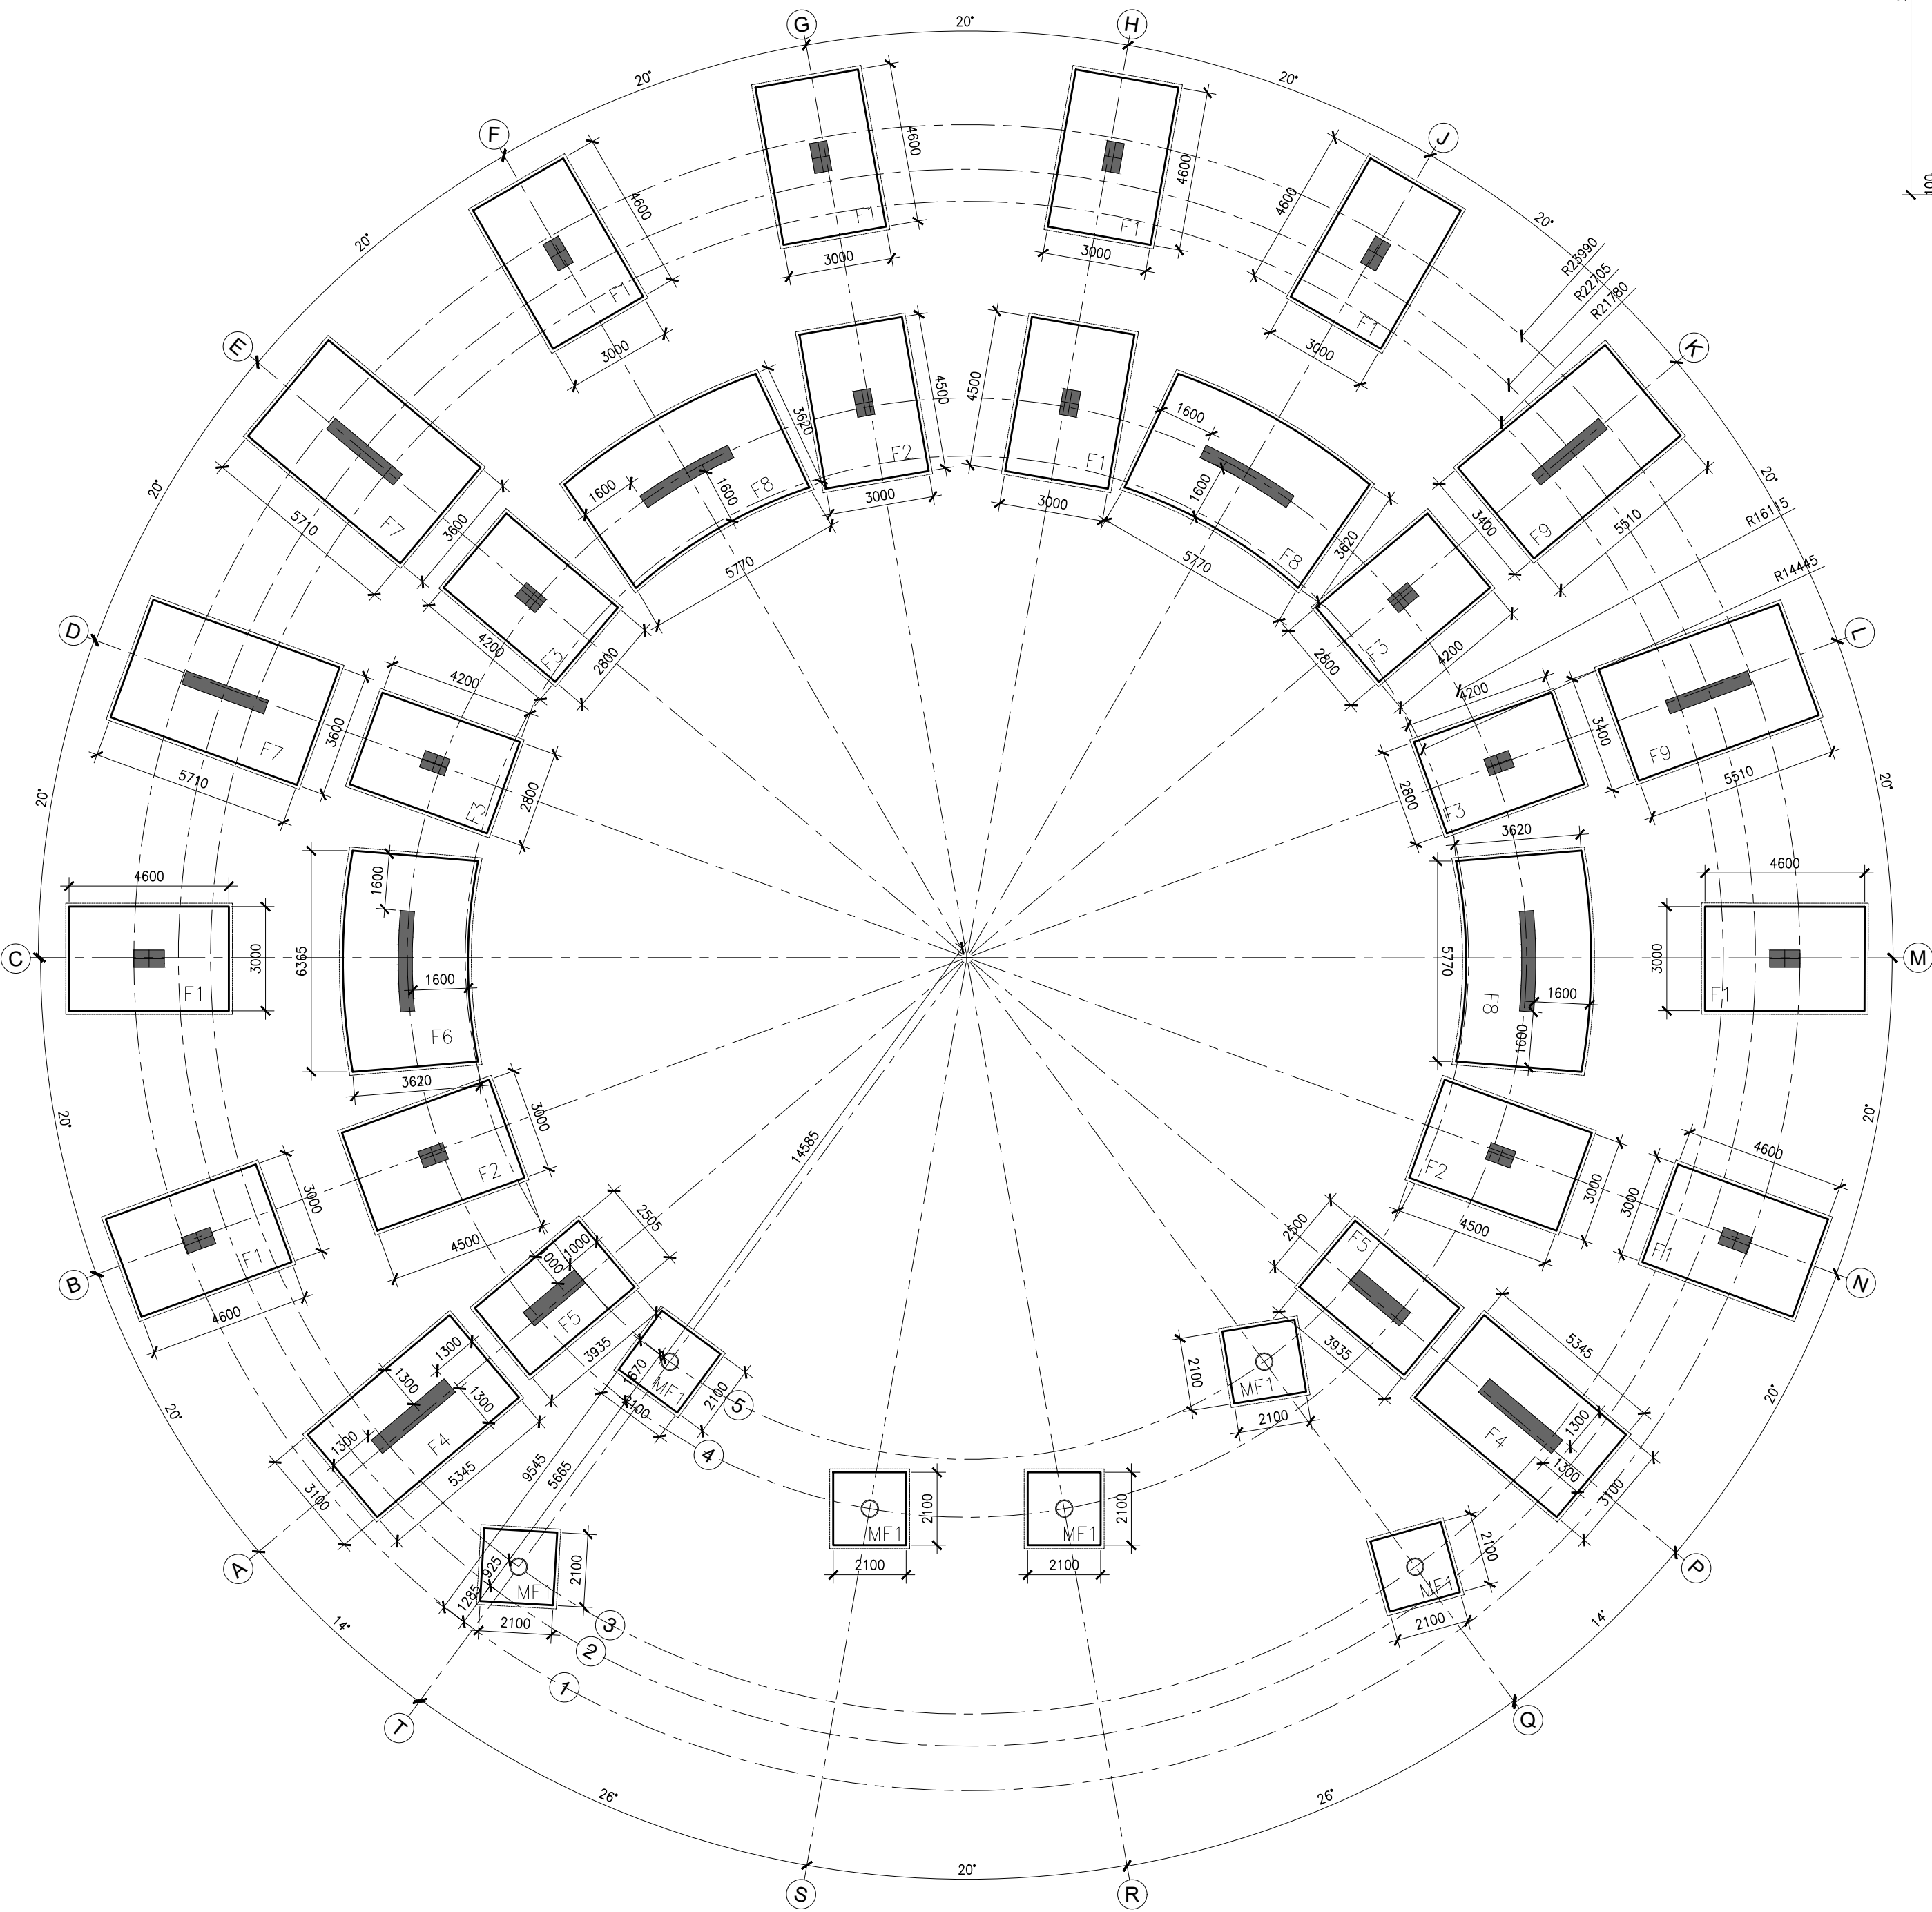

FOUNDATION PLAN
ALL FOOTINGS 650MM THK.

NOTES

- ALL DIMENSIONS AND LEVELS SHALL BE COMPARED WITH THE RELEVANT ARCHITECTURAL DRAWINGS AND DISCREPANCY IF ANY SHALL BE GOT RECONCILED BEFORE EXECUTION AT SITE.
 - FIGURED DIMENSIONS ONLY SHALL BE FOLLOWED.
 - ALL DIMENSIONS ARE IN mm UNLESS OTHERWISE SPECIFIED.
 - FOUNDATION BASE LEAN CONCRETE SHALL BE OF MIX 1:4:8(1 CEMENT:4 COARSE SAND: 8 GRADED STONE AGG.)
 - MIX OF CONCRETE SHALL BE:-
- | | |
|--------------------------------------|------|
| * COLUMN/SHEAR WALL AS PER SCHEDULE. | |
| * FOOTINGS | M-30 |
| * EXTENDED BASEMENT FOOTINGS | M-30 |
| * RETAINING WALL | M-30 |
| * TIE SLAB | M-30 |
- CLEAR COVER TO MAIN REINF. FOR R.C.C MEMBERS SHALL BE AS UNDER:-
FOUNDATION'S
BOTTOM 50mm
TOP/SIDES 40mm
 - REINFORCEMENT SHALL BE IN FORM OF HIGH STRENGTH COLD ROLLED DEFORMED STEEL BARS OF GRADE Fe500ALL CONFORMING TO IS:1786-2008.
 - LAP LENGTH OF STEEL REINFORCING BARS SHALL BE:-

MIX OF CONCRETE	REINF.fe-500 BARS
M-20	57D
M-25	49D
M-30	45D
M-35	40D
M-40 & ABOVE	36D

- 'D' IS THE DIA OF REINF. BARS
- * RETAINING WALL IS DESIGNED SUPPORTED AT ROOF LEVEL,NO BACK FILL IS TO BE EXECUTED TILL RESPECTIVE ROOF IS CAST AND CURED.
- * IN CASE OF EXTRA EXCAVATION FOUNDATION TO BE LAID ON WELL COMPACTED SOIL HAVING PROCTOR DENSITY OF MORE THAN 95% OR FILL ADDITIONAL EXCAVATED AREA WITH PCC 1:6:12.
- * ALL ISOLATED FOOTINGS SYMMETRICAL TO Q OF COLUMNS.
- * ALL COMBINED FOOTINGS SYMMETRICAL TO LINE JOINING Q OF COLUMNS.
- * FOUNDATION TO BE PLACED ON FIRM NATURAL SOIL IF REQUIRED FOUNDING LEVEL TO BE LOWERED.
- * INCASE OF OVERLAPPING OF EXTRA BARS SINGLE LENGTH BAR CAN BE PROVIDED.
- * CO-ORDINATE LEVELS WITH ARCH DRG. BEFORE
- * PROVIDE SLEEVES,INSERTS ETC. AS/SERVICE DRG.
- *ANTITERMITE TREATMENT OF FOUNDATIONS AND PLINTH FILLING SHALL CONFORM TO IS :6313

REV.NO	DATE	DESCRIPTION
--------	------	-------------


REVISIONS

CLIENT

PROJECT

TRIBAL HERITAGE CENTRE,
MANDALGRE, MEGHALAYA

ARCHITECTS :

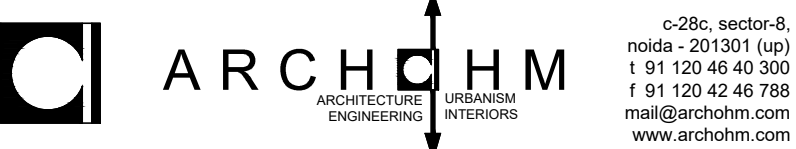

STRUCTURAL CONSULTANTS


TPC TECHNICAL PROJECTS CONSULTANTS(P)LTD.
H.O- B-74, SECTOR 57, NOIDA
UTTAR PRADESH-201301 (INDIA)
BOARD NO:-91-120-4306800

DESIGN & ENGINEERING • COST & QUALITY MANAGEMENT • RETROFITTING
GURGAON • HYDERABAD • NEWDELHI • NOIDA


DRAWING TITLE :

EXHIBITION & RESEARCH CENTER
FOUNDATION PLAN

PROJECT CODE	...	REVISION
DATE	16.09.2024	
DRAWN BY :	ARUN	R0
CHECKED	PG	DRAWING NO.
SCALE	1:75	

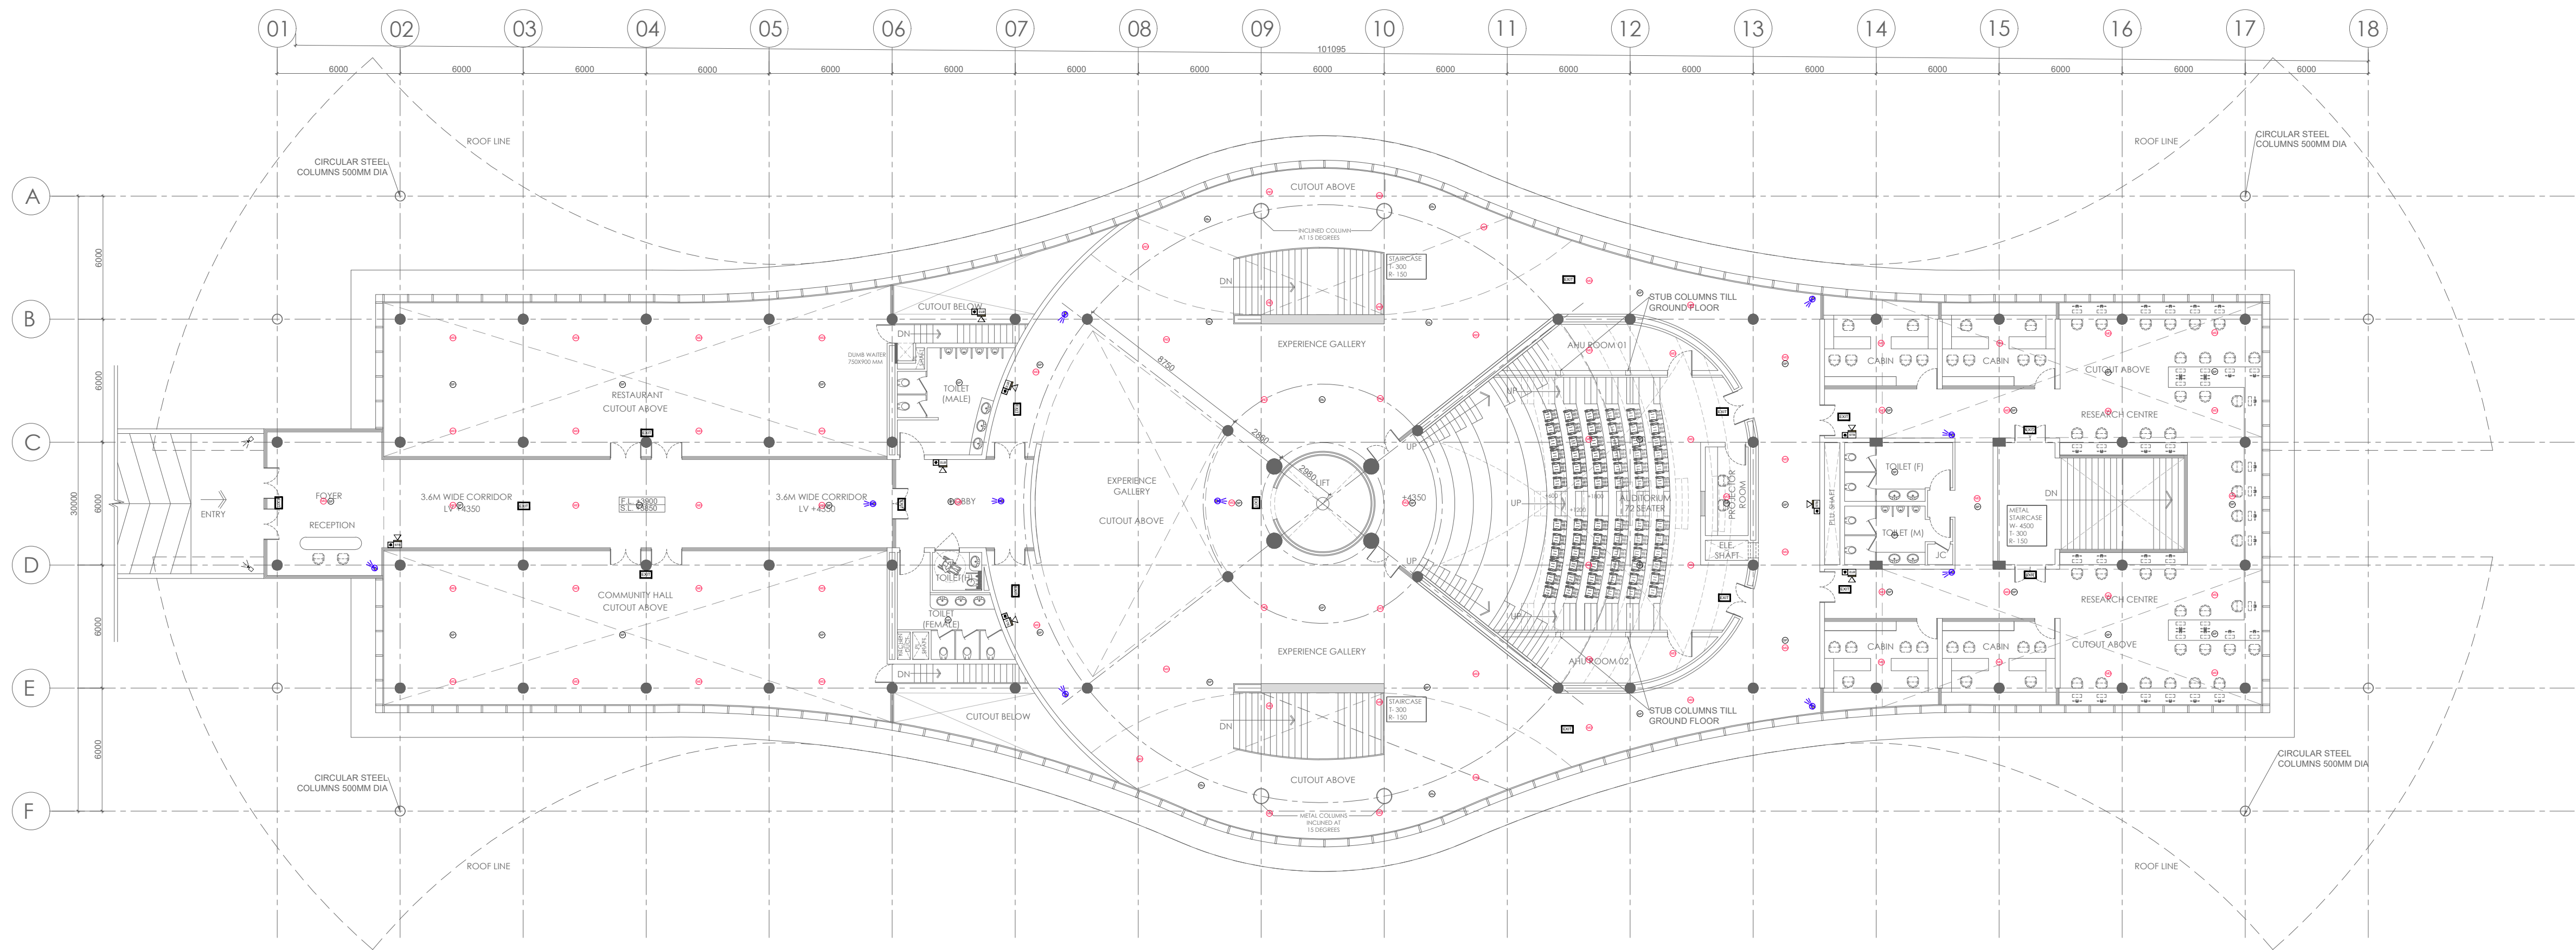

GROUND FLOOR PLAN

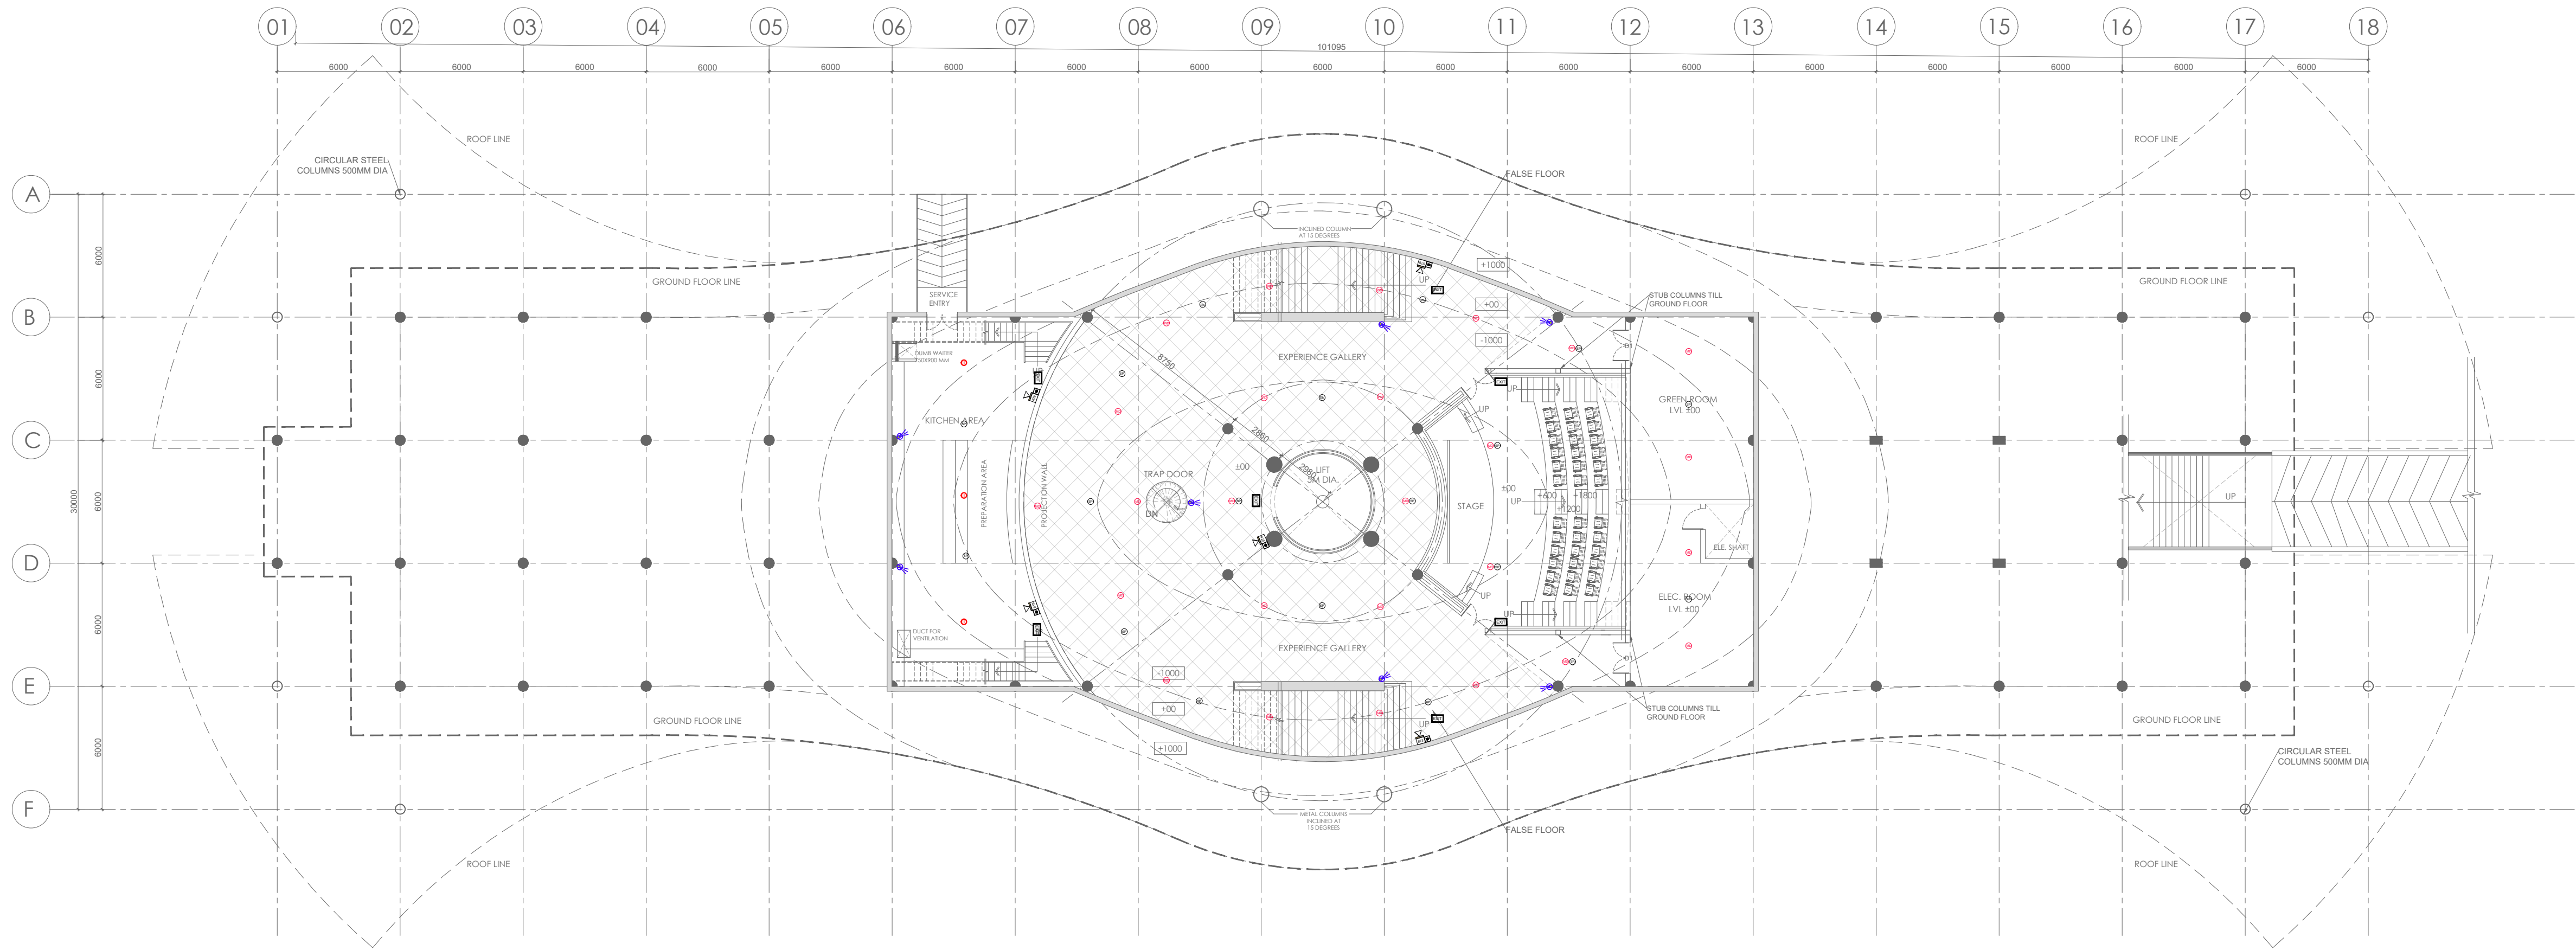

LOWER GROUND FLOOR PLAN

FIRE & PA LEGEND	
SYMBOL	DESCRIPTION
	SMOKE DETECTOR
	HEAT DETECTOR
	BEAM DETECTOR
	SPEAKER
	MANUAL CALL POINT
	HOOTER
	EXIT SIGNAGE
	DOME CAMERA
	BULLET CAMERA
MOUNTING HEIGHT ABOVE FFL	
	SURFACE MOUNTED
	SURFACE MOUNTED
	WALL / SURFACE MOUNTED
	SURFACE MOUNTED
	1200mm
	2400mm

- NOTES:
- DO NOT SCALE THE DRAWING. FOLLOW ONLY FIGURED DIMENSIONS
 - ALL DIMENSIONS GIVEN IN THIS DRAWING ARE IN MILLIMETERS UNLESS NOTED OTHERWISE.
 - ALL DIMENSIONS TO BE VERIFIED ON SITE AND APPROVED BY THE SITE ENGINEER
 - ANY DISCREPANCY OR AMBIGUITY IN THE DRAWINGS SHOULD IMMEDIATELY BE BROUGHT TO NOTICE OF THE ARCHITECT
 - ALL DRAWINGS SHOULD BE READ IN CONJUNCTION WITH OTHER RELEVANT ARCHITECTURAL, STRUCTURAL, PLUMBING, MECHANICAL AND ELECTRICAL DRAWINGS.
 - THE ± 0 REFERS TO LEVEL ESTABLISHED AT SITE IN PRESENCE OF THE SITE SUPERVISOR AND THE ARCHITECT. ALL REMAINING LEVELS ARE RELATIVE TO THIS LEVEL.
 - THIS DRAWING IS THE COPYRIGHT OF ARCHOHM CONSULTANTS AND MUST NOT BE RETAINED, COPIED OR USED WITHOUT THEIR AUTHORITY.

REVISIONS			
No.	Date	Descriptions	Revision by

Client:
MEGHALAYAN AGE LIMITED (MAL)

Project:
TRIBAL HERITAGE CENTRE, MANDALGRE, MEGHALAYA

Architects:



©2016, section 8,
regd. no. 201/2016/1601
1 91 120 46 40 300
1 91 120 42 48 788
mail@archohm.com
www.archohm.com

Structural Consultants:

TPC TECHNICAL PROJECTS

CONSULTANTS PVT. LTD.

10/2, B-4, Sector 07, Noida, U.P.
7/11, 12th floor, 11/12, 13th floor,
Noida, U.P. 201301
BOMBO NO. 01/120/400000

Electrical Consultants:

ARCHOHM CONSULTANT

PVT. LTD.

10/2, B-4, Sector 07, Noida, U.P.
7/11, 12th floor, 11/12, 13th floor,
Noida, U.P. 201301
BOMBO NO. 01/120/400000

M/E Consultants:

WAC

WAC Engineers

INDIA PVT. LTD.

MEP Consultants &
Project Managers

10/2, B-4, Sector 07, Noida, U.P.
7/11, 12th floor, 11/12, 13th floor,
Noida, U.P. 201301
BOMBO NO. 01/120/400000

10/2, B-4, Sector 07, Noida, U.P.
7/11, 12th floor, 11/12, 13th floor,
Noida, U.P. 201301
BOMBO NO. 01/120/400000

10/2, B-4, Sector 07, Noida, U.P.
7/11, 12th floor, 11/12, 13th floor,
Noida, U.P. 201301
BOMBO NO. 01/120/400000

Drawn By

CK

Checked By

AKD

Design By

AKD

Sheet Title:
**EXHIBITION & RESEARCH CENTRE
LOWER GROUND & GROUND FLOOR PLAN
FIRE, PA & CCTV LAYOUT**

Date:

25-08-2024

Drawing No.:

E-232409-B1-05-02

TENDER DRAWING

Scale:


1:200

Project No.:

A-232409

A1

R0

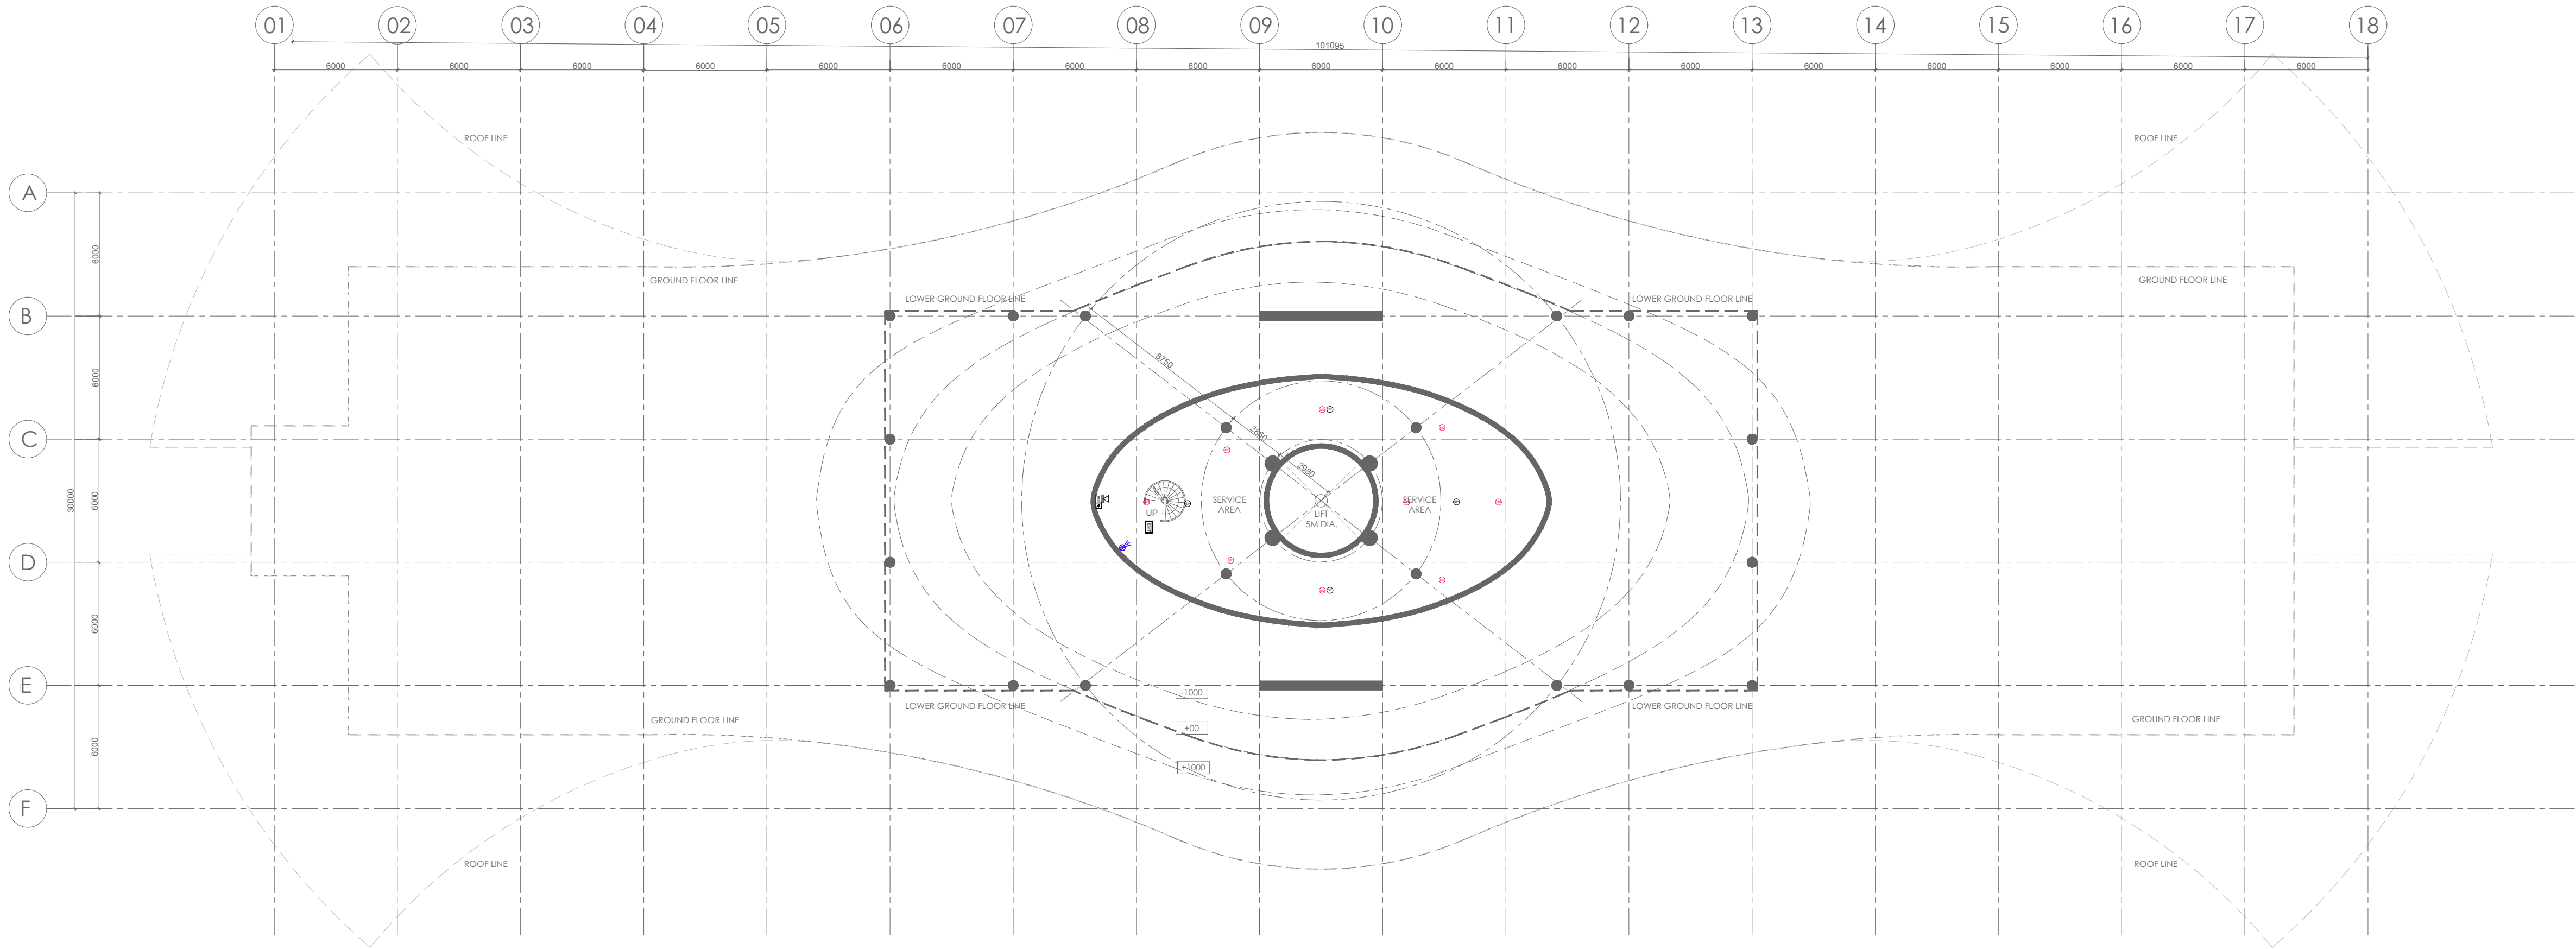

SERVICE FLOOR PLAN

FIRE & PA LEGEND		
SYMBOL	DESCRIPTION	MOUNTING HEIGHT ABOVE FFL
	SMOKE DETECTOR	SURFACE MOUNTED
	HEAT DETECTOR	SURFACE MOUNTED
	BEAM DETECTOR	WALL / SURFACE MOUNTED
	SPEAKER	SURFACE MOUNTED
	MANUAL CALL POINT	1200mm
	HOOTER	2400mm
	EXIT SIGNAGE	
	DOME CAMERA	
	BULLET CAMERA	

- NOTES:
- DO NOT SCALE THE DRAWING. FOLLOW ONLY FIGURED DIMENSIONS
 - ALL DIMENSIONS GIVEN IN THIS DRAWING ARE IN MILLIMETERS UNLESS NOTED OTHERWISE.
 - ALL DIMENSIONS TO BE VERIFIED ON SITE AND APPROVED BY THE SITE ENGINEER.
 - ANY DISCREPANCY OR AMBIGUITY IN THE DRAWINGS SHOULD IMMEDIATELY BE BROUGHT TO NOTICE OF THE ARCHITECT.
 - ALL DRAWINGS SHOULD BE READ IN CONJUNCTION WITH OTHER RELEVANT ARCHITECTURAL, STRUCTURAL, PLUMBING, MECHANICAL AND ELECTRICAL DRAWINGS.
 - THE ± 0 REFERS TO LEVEL ESTABLISHED AT SITE IN PRESENCE OF THE SITE SUPERVISOR AND THE ARCHITECT. ALL REMAINING LEVELS ARE RELATIVE TO THIS LEVEL.
 - THIS DRAWING IS THE COPYRIGHT OF ARCHOHM CONSULTANTS PVT. LTD. AND MUST NOT BE RETAINED, COPIED OR USED WITHOUT THEIR AUTHORITY.

REVISIONS			
No.	Date	Descriptions	Revision by

Client:
MEGHALAYAN AGE LIMITED (MAL)

Project:
TRIBAL HERITAGE CENTRE, MANDALGRE, MEGHALAYA

Architects:



Structural Consultants:
TPC TECHNICAL PROJECTS CONSULTANTS (P) LTD.
H/O: B-14, Sector 07, Noida, Uttar Pradesh
Phone: 91-11-26100000
Mobile: 91-91-120-42-48-7888
Email: mail@tpcprojects.com
www.tpcprojects.com

Electrical Consultants:
ARCHOHM CONSULTANT PVT. LTD.
H/O: B-14, Sector 07, Noida, Uttar Pradesh
Phone: 91-11-26100000
Mobile: 91-91-120-42-48-7888
Email: mail@archohm.com
www.archohm.com

M/E Consultants:
WAC Engineers INDIA PVT. LTD.
MEP Consultants & Project Managers
H/O: B-14, Sector 07, Noida, Uttar Pradesh
Phone: 91-11-26100000
Mobile: 91-91-120-42-48-7888
Email: mail@wacindia.com
www.wacindia.com

Drawn By
Checked By
Design By

CK

AKD

AKD

Sheet Title:
**EXHIBITION & RESEARCH CENTRE
SERVICE FLOOR PLAN
FIRE, PA & CCTV LAYOUT**

Date:
25-08-2024


Scale:
1:200

Drawing No.:
E-232409-B1-05-01


TENDER DRAWING

Project No.:
A-232409

A1 R0

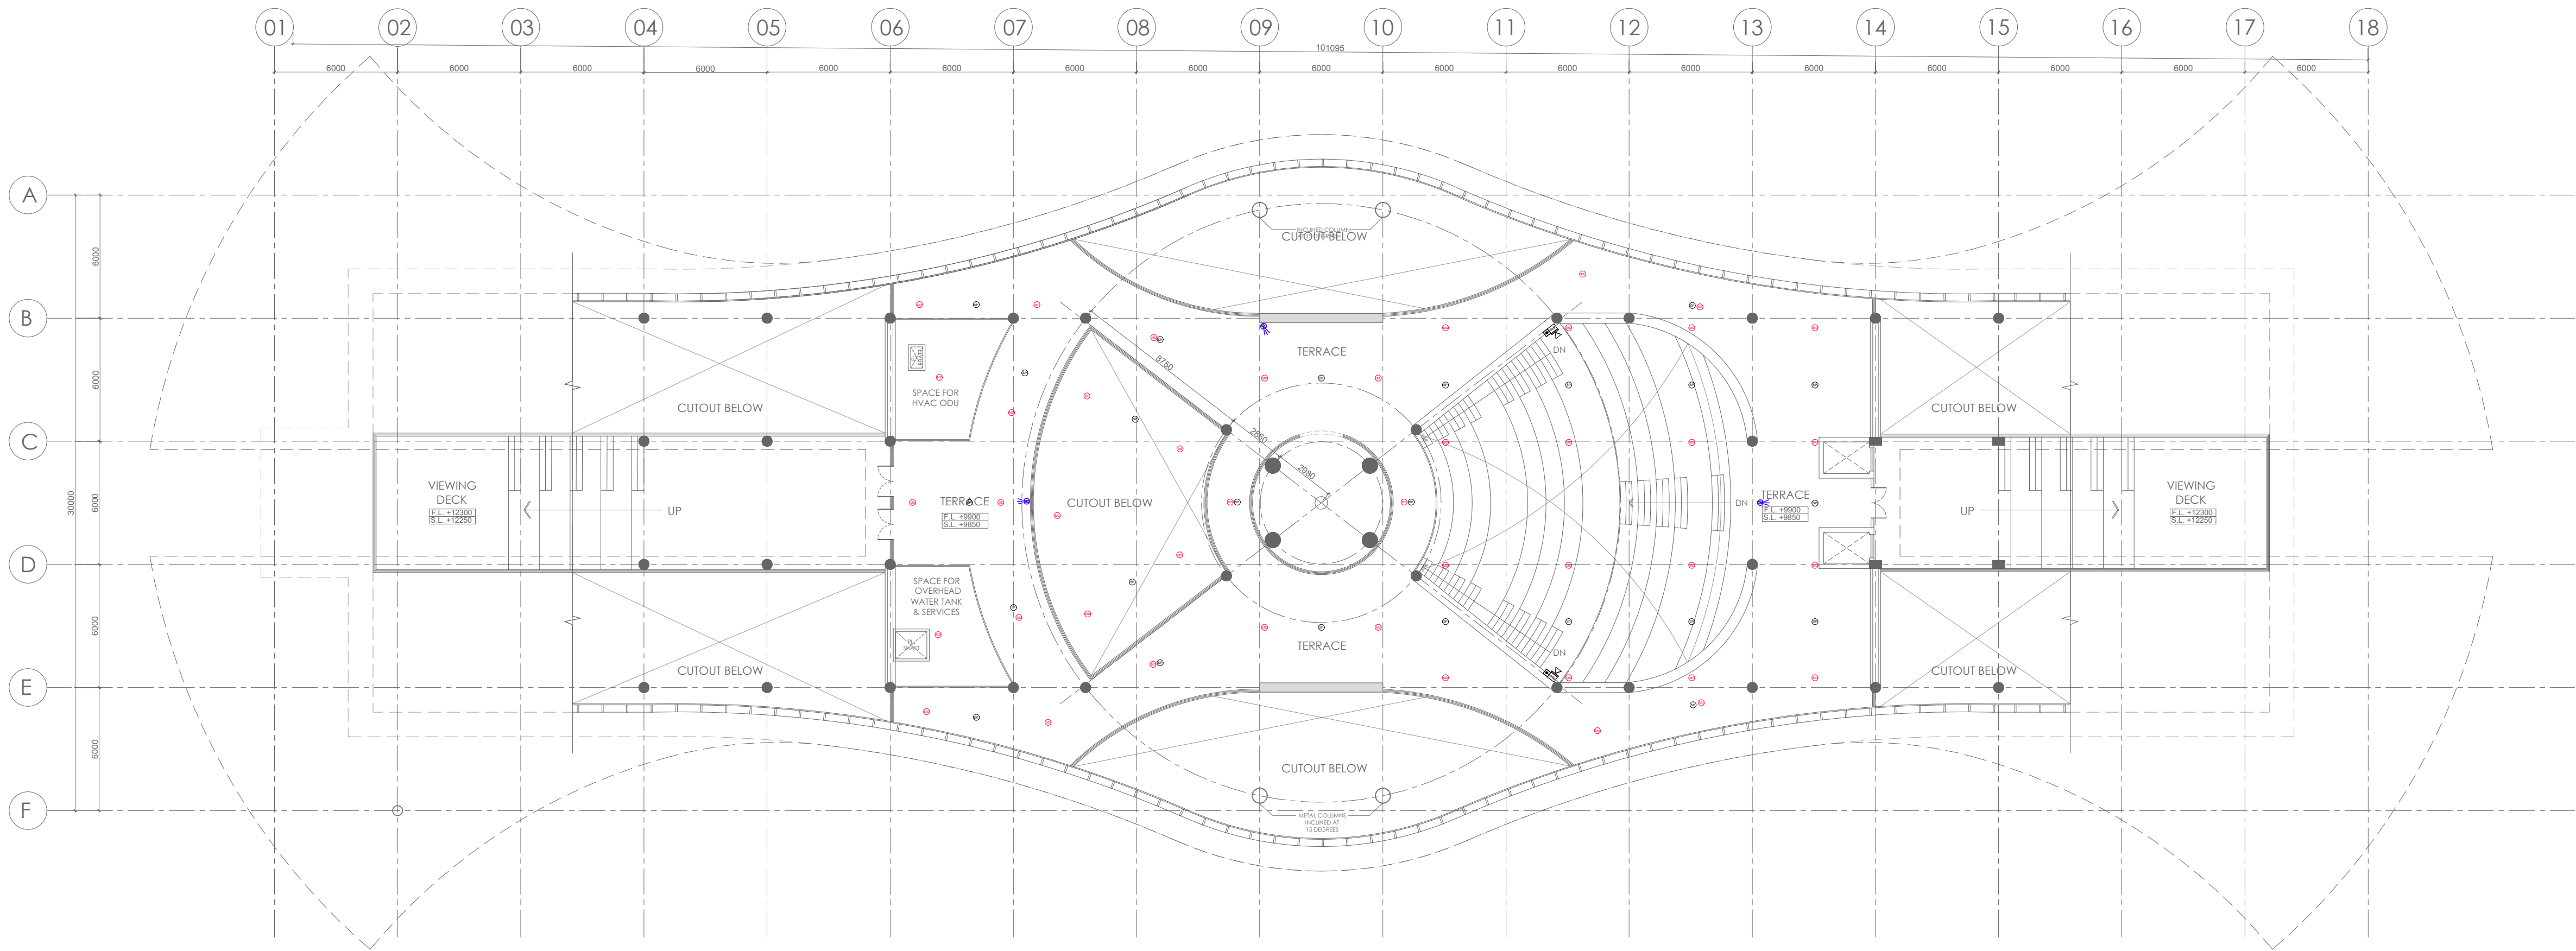

USABLE TERRACE PLAN

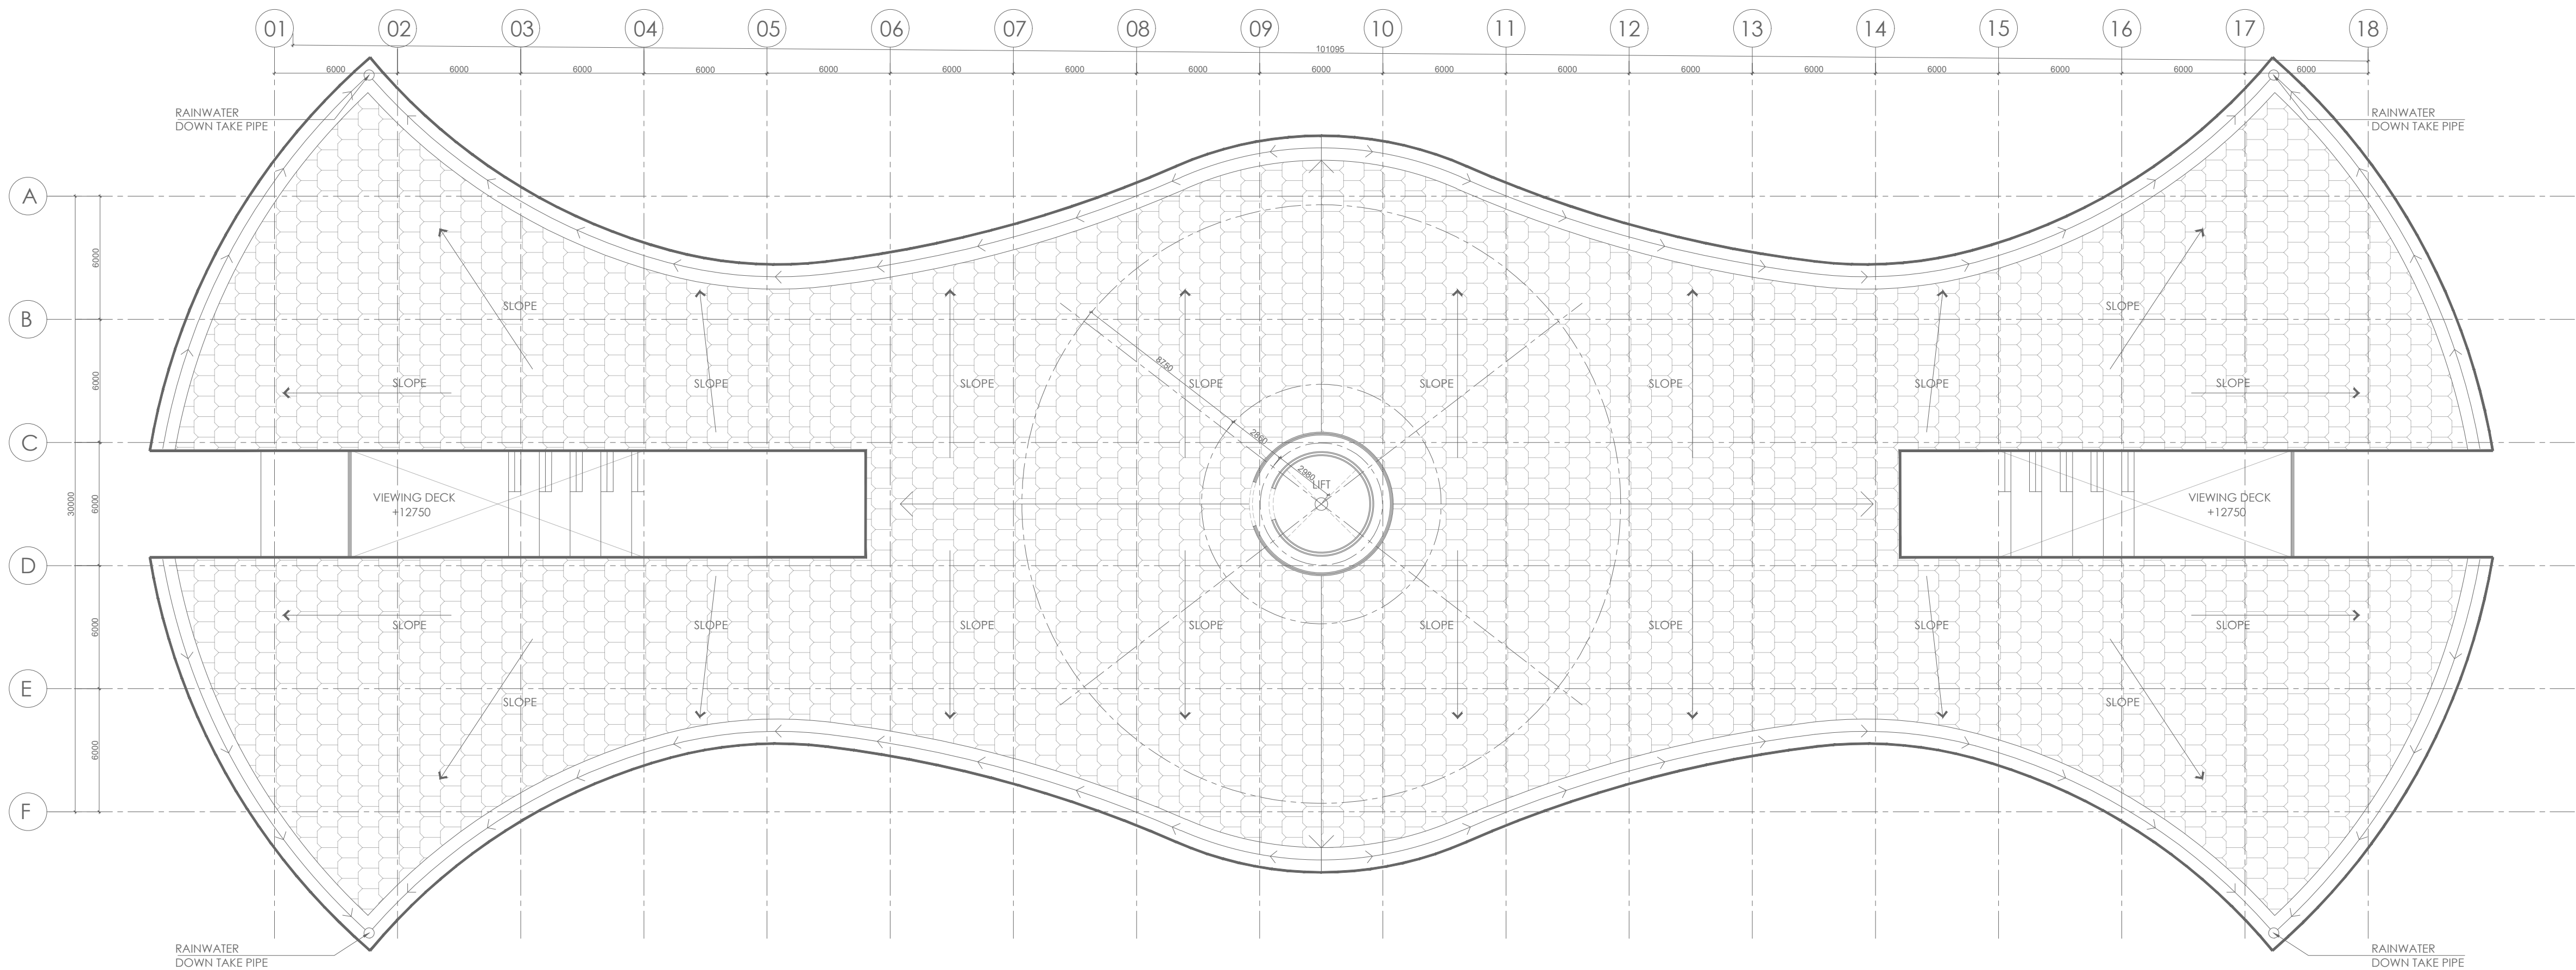

ROOF PLAN

FIRE & PA LEGEND		
SYMBOL	DESCRIPTION	MOUNTING HEIGHT ABOVE FFL
	SMOKE DETECTOR	SURFACE MOUNTED
	HEAT DETECTOR	SURFACE MOUNTED
	BEAM DETECTOR	WALL / SURFACE MOUNTED
	SPEAKER	SURFACE MOUNTED
	MANUAL CALL POINT	1200mm
	HOOTER	2400mm
	EXIT SIGNAGE	
	DOME CAMERA	
	BULLET CAMERA	

NOTES:

- DO NOT SCALE THE DRAWING. FOLLOW ONLY FIGURED DIMENSIONS.
- ALL DIMENSIONS GIVEN IN THIS DRAWING ARE IN MILLIMETERS UNLESS NOTED OTHERWISE.
- ALL DIMENSIONS TO BE VERIFIED ON SITE AND APPROVED BY THE SITE ENGINEER.
- ANY DISCREPANCY OR AMBIGUITY IN THE DRAWINGS SHOULD IMMEDIATELY BE BROUGHT TO NOTICE OF THE ARCHITECT.
- ALL DRAWINGS SHOULD BE READ IN CONJUNCTION WITH OTHER RELEVANT ARCHITECTURAL, STRUCTURAL, PLUMBING, MECHANICAL AND ELECTRICAL DRAWINGS.
- THE ± 0 REFERS TO LEVEL ESTABLISHED AT SITE IN PRESENCE OF THE SITE SUPERVISOR AND THE ARCHITECT. ALL REMAINING LEVELS ARE RELATIVE TO THIS LEVEL.
- THIS DRAWING IS THE COPYRIGHT OF ARCHOHM CONSULTANTS AND MUST NOT BE RETAINED, COPIED OR USED WITHOUT THEIR AUTHORITY.

REVISIONS

No.	Date	Descriptions	Revision by

Client:

MEGHALAYAN AGE LIMITED (MAL)

Project:

TRIBAL HERITAGE CENTRE, MANDALGRE, MEGHALAYA

Architects:



Structural Consultants:

TPC TECHNICAL PROJECTS CONSULTANTS PVT. LTD.
H/O: 2nd Floor, 2nd Floor, 2nd Floor
1/11, 12th Main Road, 1st Floor, 1st Floor
BANGALORE-560001
CONTACT NO: 91-120-400000

Electrical Consultants:

ARCHOHM CONSULTANT PVT. LTD.
H/O: 2nd Floor, 2nd Floor, 2nd Floor
1/11, 12th Main Road, 1st Floor, 1st Floor
BANGALORE-560001
CONTACT NO: 91-120-400000

M/E Consultants:

WAC Engineers INDIA PVT. LTD.
MEP Consultants & Project Managers
P.O. Box 100, 100, 100, 100
P.O. Box 100, 100, 100, 100

Drawn By

CK

Checked By

AKD

Design By

AKD

Sheet Title:

EXHIBITION & RESEARCH CENTRE
USABLE TERRACE & ROOF FLOOR PLAN
FIRE, PA & CCTV LAYOUT

Date:

25-08-2024

Scale:

1:200

Drawing No.:

E-232409-B1-05-03


Project No.:

A-232409


Project No.:

A1 R0

TENDER DRAWING

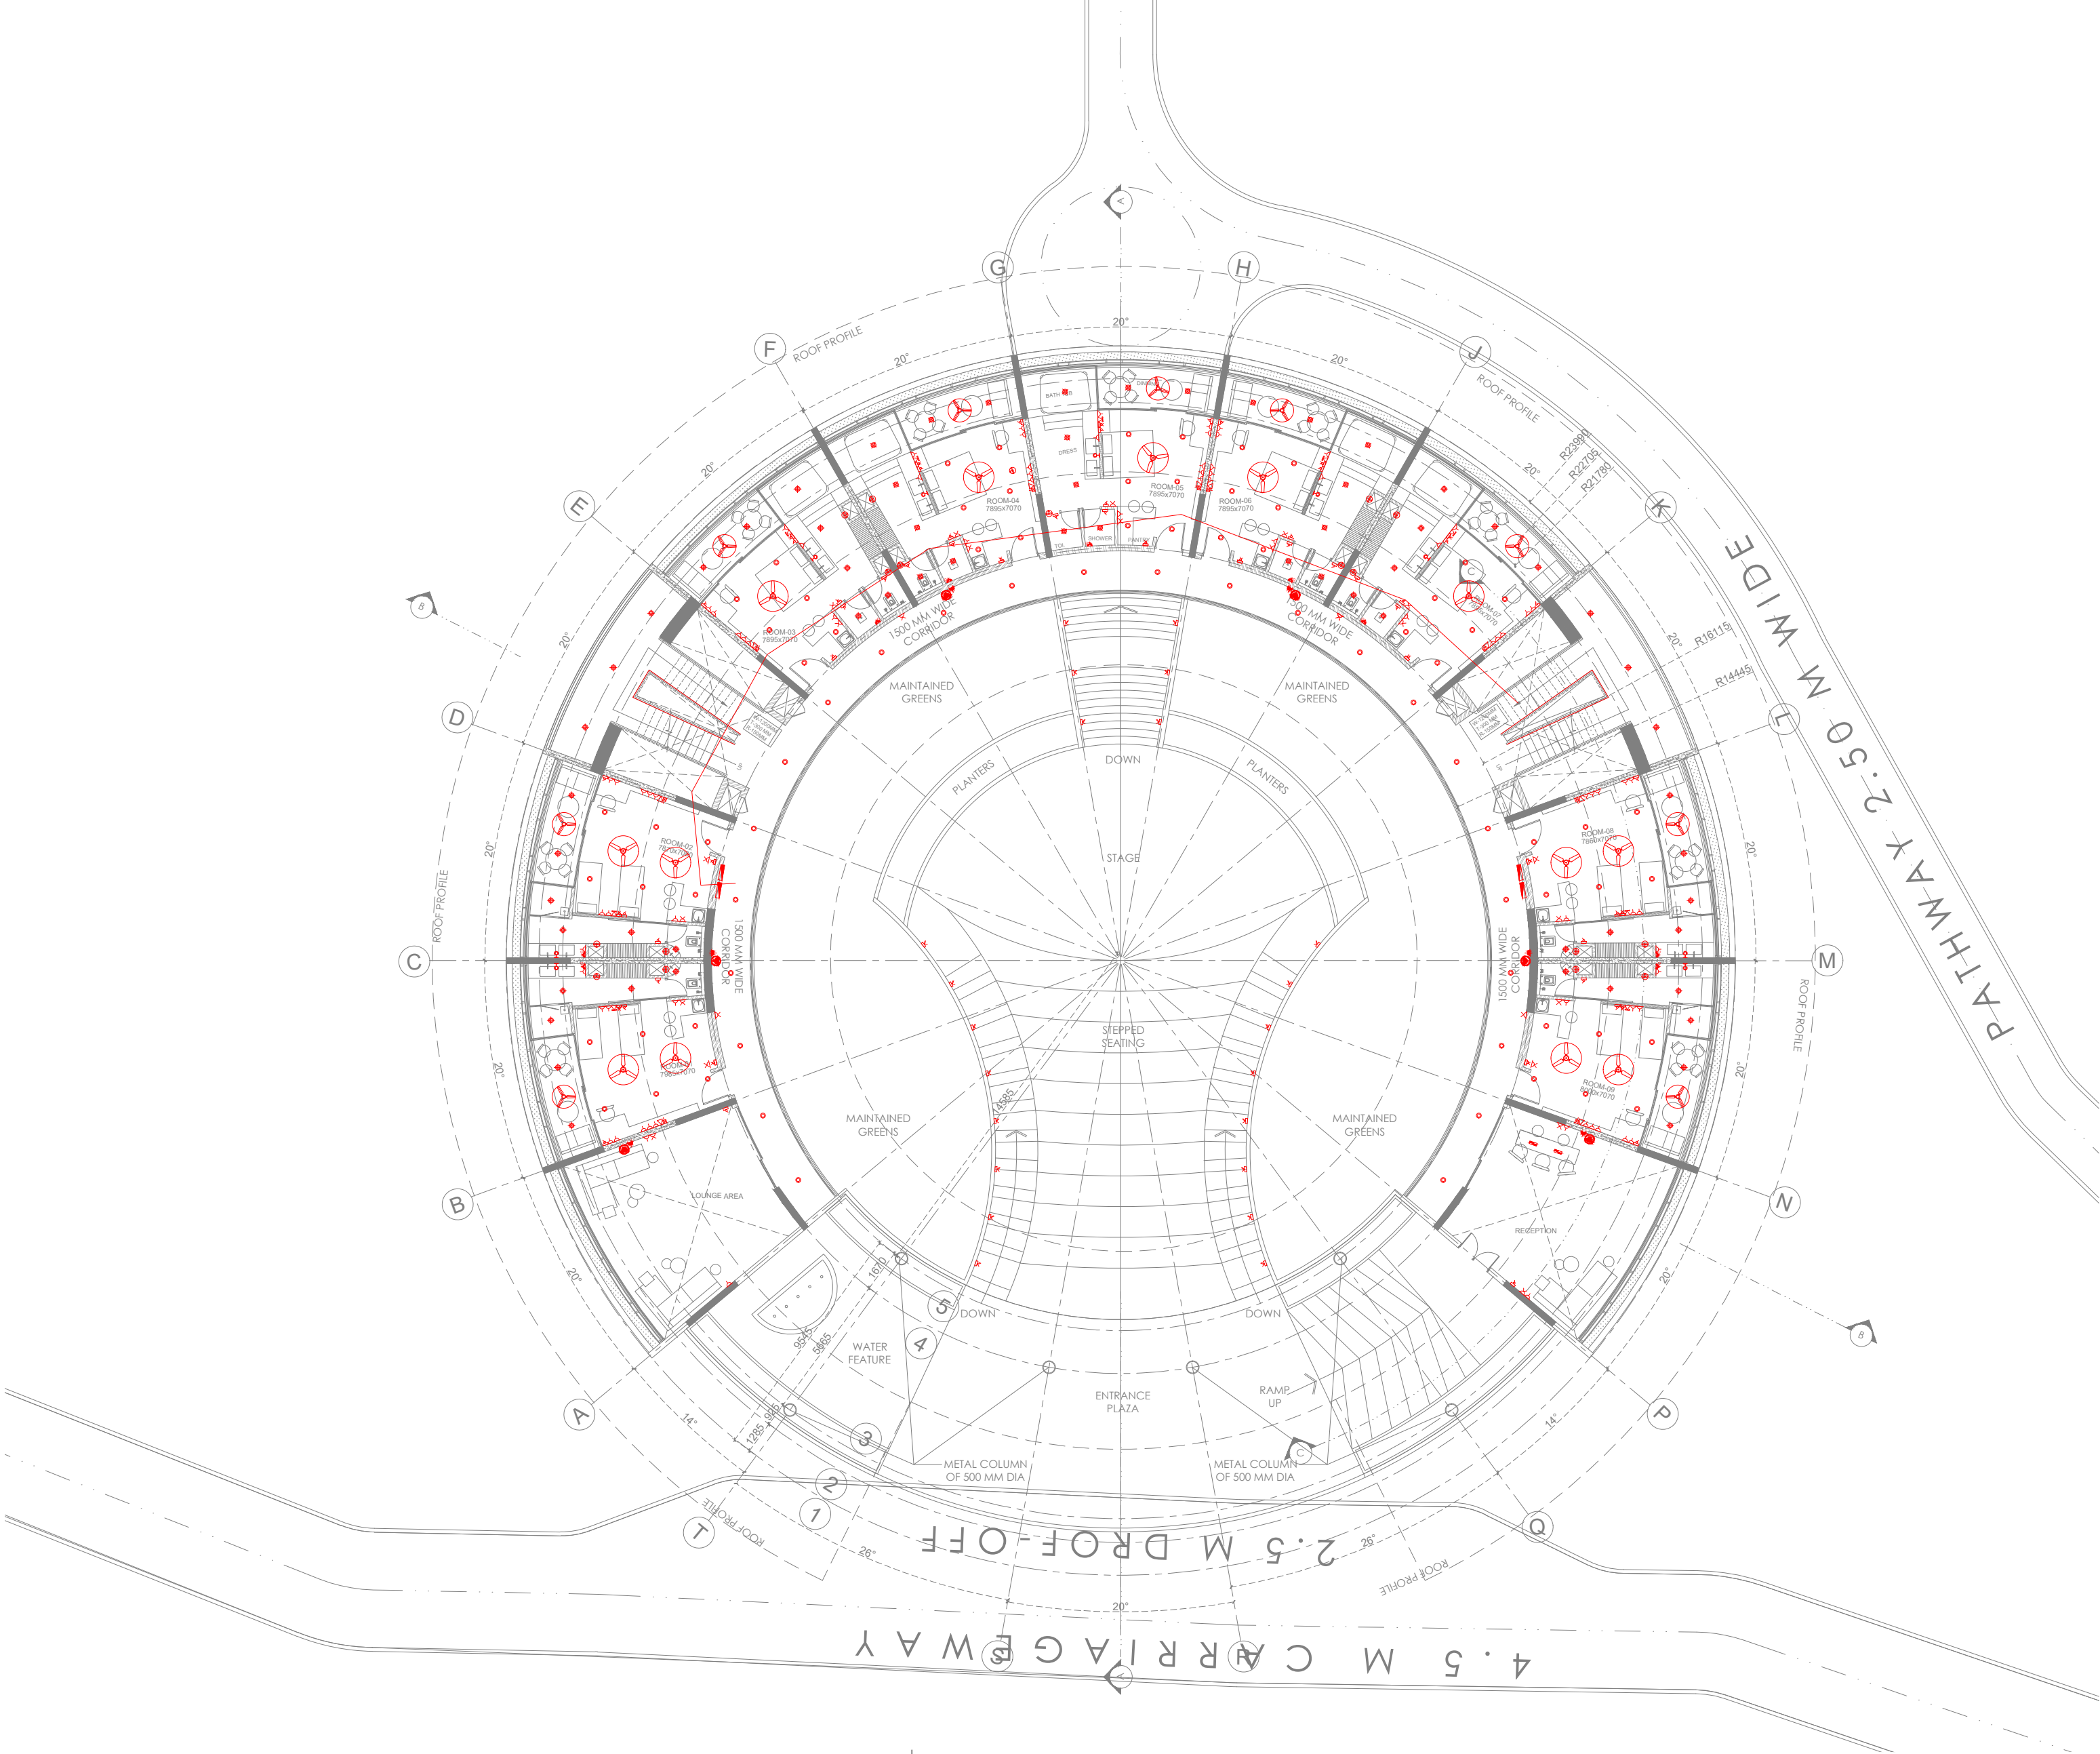

GROUND FLOOR PLAN
SCALE 1:200

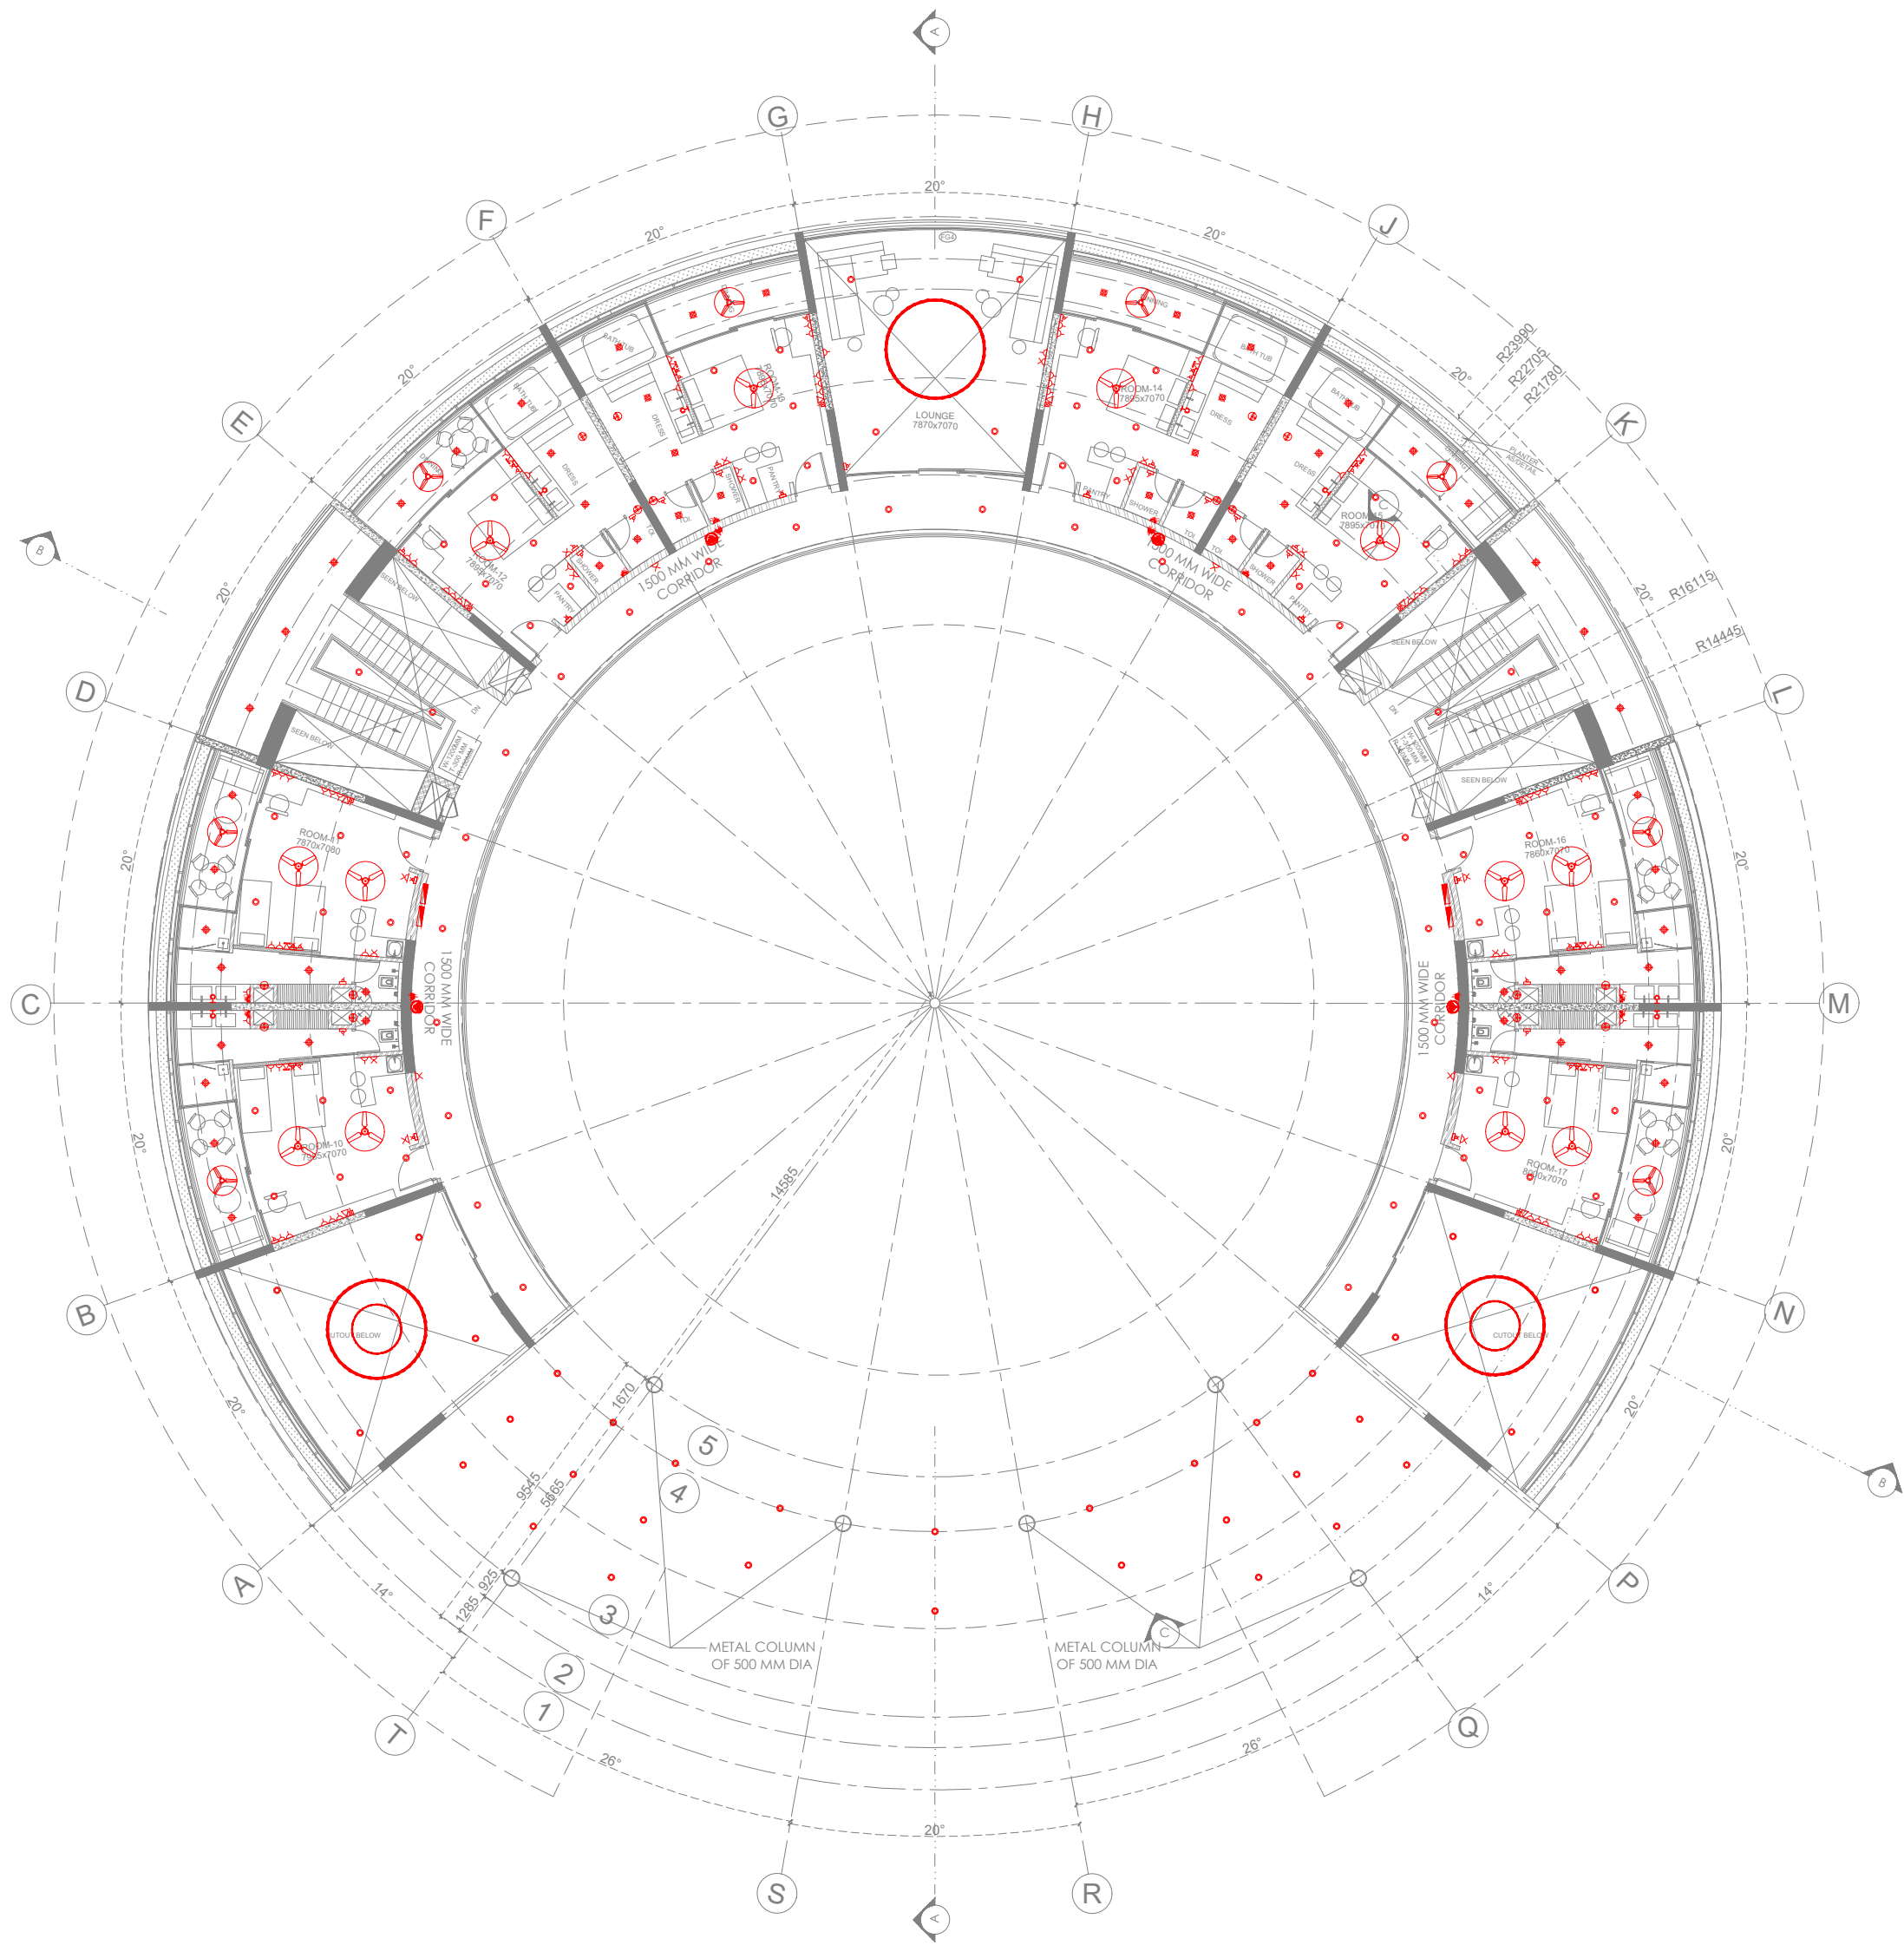

FIRST FLOOR PLAN
SCALE 1:200

LEGEND		
SYMBOL	DESCRIPTION	MOUNTING HEIGHT ABOVE FFL (FROM BOTTOM OF SWITCH BOARD)
SWITCH 1 WAY	1000mm AFFL (150mm FROM DOOR FRAME)	
SWITCH 2 WAY	1000mm AFFL (150mm FROM DOOR FRAME)	
10 WATT LED LIGHT	SURFACE MOUNTED	
18 WATT LED LIGHT	SURFACE MOUNTED	
32 WATT LED LIGHT	SURFACE MOUNTED	
54 WATT LED LIGHT	SURFACE MOUNTED	
TRACK LIGHT - 1 METER	SURFACE / WALL MOUNTED	
TRACK LIGHT - 2 METER	SURFACE / WALL MOUNTED	
44 WATT LED LINEAR LIGHT	SUSPENDED / SURFACE	
LIGHT POINT	WALL @ 2150mm	
40 WATT LED TUBE LIGHT-4FT	SURFACE / WALL MOUNTED	
10 WATT LED STRIP LIGHT		
28 WATT LED CIRCULAR LIGHT		
10 WATT LED BULK HEAD LIGHT	WALL MOUNTED @2100mm	
DECORATIVE LIGHT	SUSPENDED MOUNTED	
3 WATT LED STEP LIGHT	WALL MOUNTED @ 300mm AFFL/TREAD	
3 WATT LED SPIKE LIGHT	GROUND EMBEDDED	
CEILING FAN - 900mm	SUSPENDED MOUNTED	
CEILING FAN - 1200mm	SUSPENDED MOUNTED	
EXHAUST FAN - 200mm	WALL MOUNTED	
100 WATT LED FLOOD LIGHT	SURFACE / WALL MOUNTED	
ELECTRICAL DB	MOUNTED ON WALL (TOP OF DB 1800MM FROM FFL)	

TENDER DRAWING

NOTES:

- DO NOT SCALE THE DRAWING. FOLLOW ONLY FIGURED DIMENSIONS
- ALL DIMENSIONS GIVEN IN THIS DRAWING ARE IN MILLIMETERS UNLESS NOTED OTHERWISE.
- ALL DIMENSIONS TO BE VERIFIED ON SITE AND APPROVED BY THE SITE ENGINEER
- ANY DISCREPANCY OR AMBIGUITY IN THE DRAWINGS SHOULD IMMEDIATELY BE BROUGHT TO NOTICE OF THE ARCHITECT.
- ALL DRAWINGS SHOULD BE READ IN CONJUNCTION WITH OTHER RELEVANT ARCHITECTURAL, STRUCTURAL, PLUMBING, MECHANICAL AND ELECTRICAL DRAWINGS.
- THE ± 0 REFERS TO LEVEL ESTABLISHED AT SITE IN PRESENCE OF THE SITE SUPERVISOR AND THE ARCHITECT. ALL REMAINING LEVELS ARE RELATIVE TO THIS LEVEL.
- THIS DRAWING IS THE COPYRIGHT OF ARCHOHM CONSULTS AND MUST NOT BE RETAINED, COPIED OR USED WITHOUT THEIR AUTHORITY.

REVISIONS

No.	Date	Descriptions	Revision by

Client:

MEGHALAYAN AGE LIMITED (MAL)

Project:

TRIBAL HERITAGE CENTRE, MANDALGRE, MEGHALAYA

Architects:



Structural Consultants:

TPC TECHNICAL PROJECTS CONSULTANTS (P) LTD.
H/O: B-14, Sector 02, Noida, Uttar Pradesh
Phone: 0120-2610000
Mobile: 98102-40000
Email: tpc@tpc.co.in
Website: www.tpc.co.in

Electrical Consultants:

ARCHOHM CONSULTANT PVT. LTD.
H/O: B-14, Sector 02, Noida, Uttar Pradesh
Phone: 0120-2610000
Mobile: 98102-40000
Email: archohm@archohm.com
Website: www.archohm.com

M/E Consultants:

WAC Engineers INDIA PVT. LTD.
H/O: B-14, Sector 02, Noida, Uttar Pradesh
Phone: 0120-2610000
Mobile: 98102-40000
Email: wac@wac.co.in
Website: www.wac.co.in

Drawn By:

CK

Checked By:

AKD

Design By:

AKD

Sheet Title:

EXHIBITION & RESEARCH CENTRE LOWER GF & GROUND FLOOR PLAN LIGHTING LAYOUT

Date:

25-07-2024

Scale:

1:200

Project No.:


A-232409

Drawing No.:


E-232409-00-03-01

A1

R0

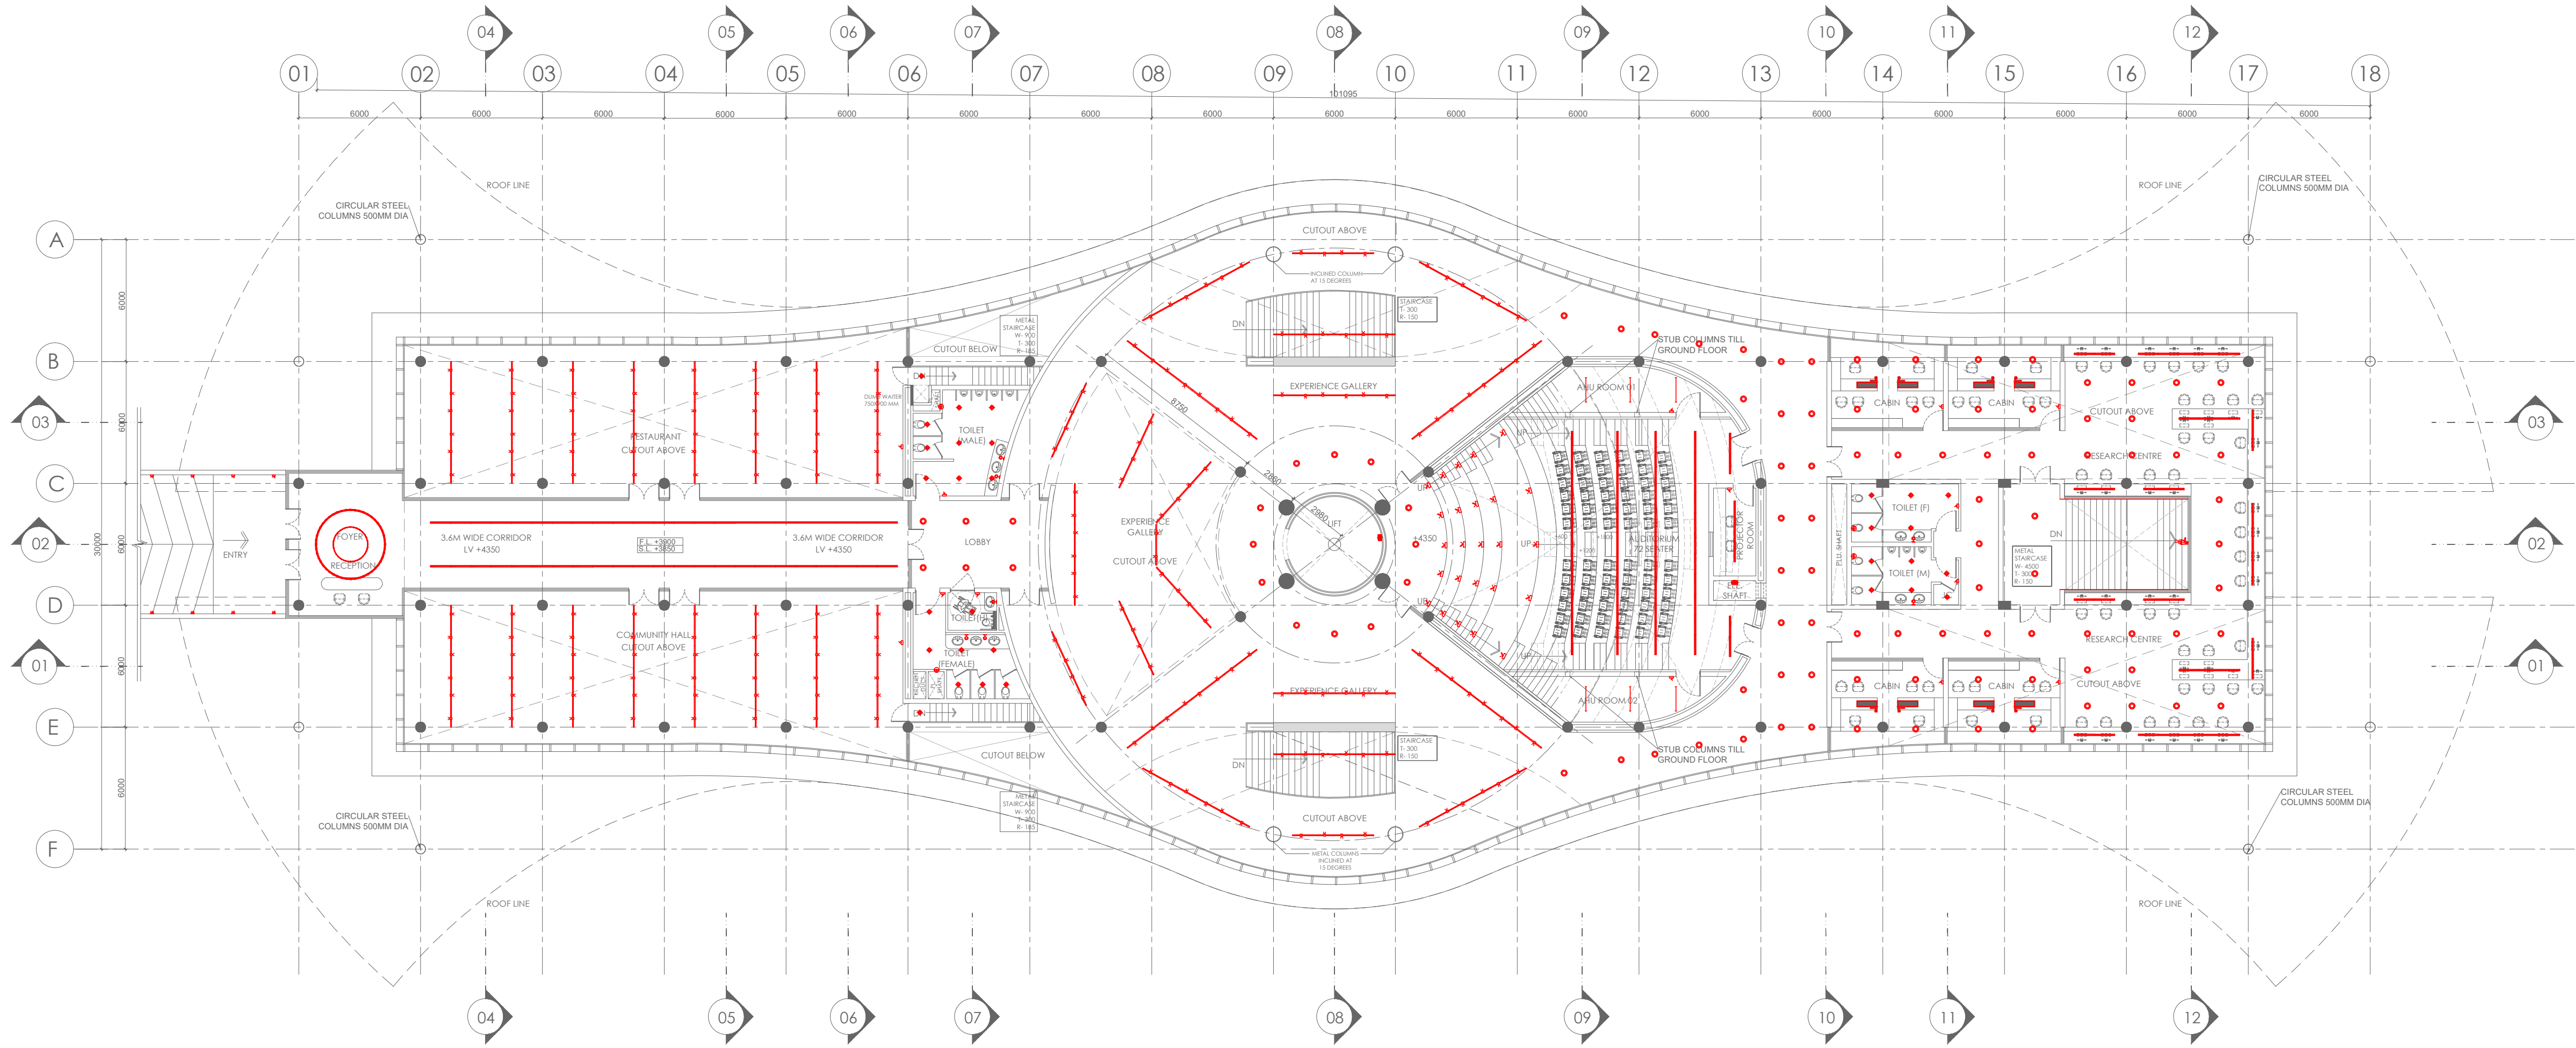

GROUND FLOOR PLAN

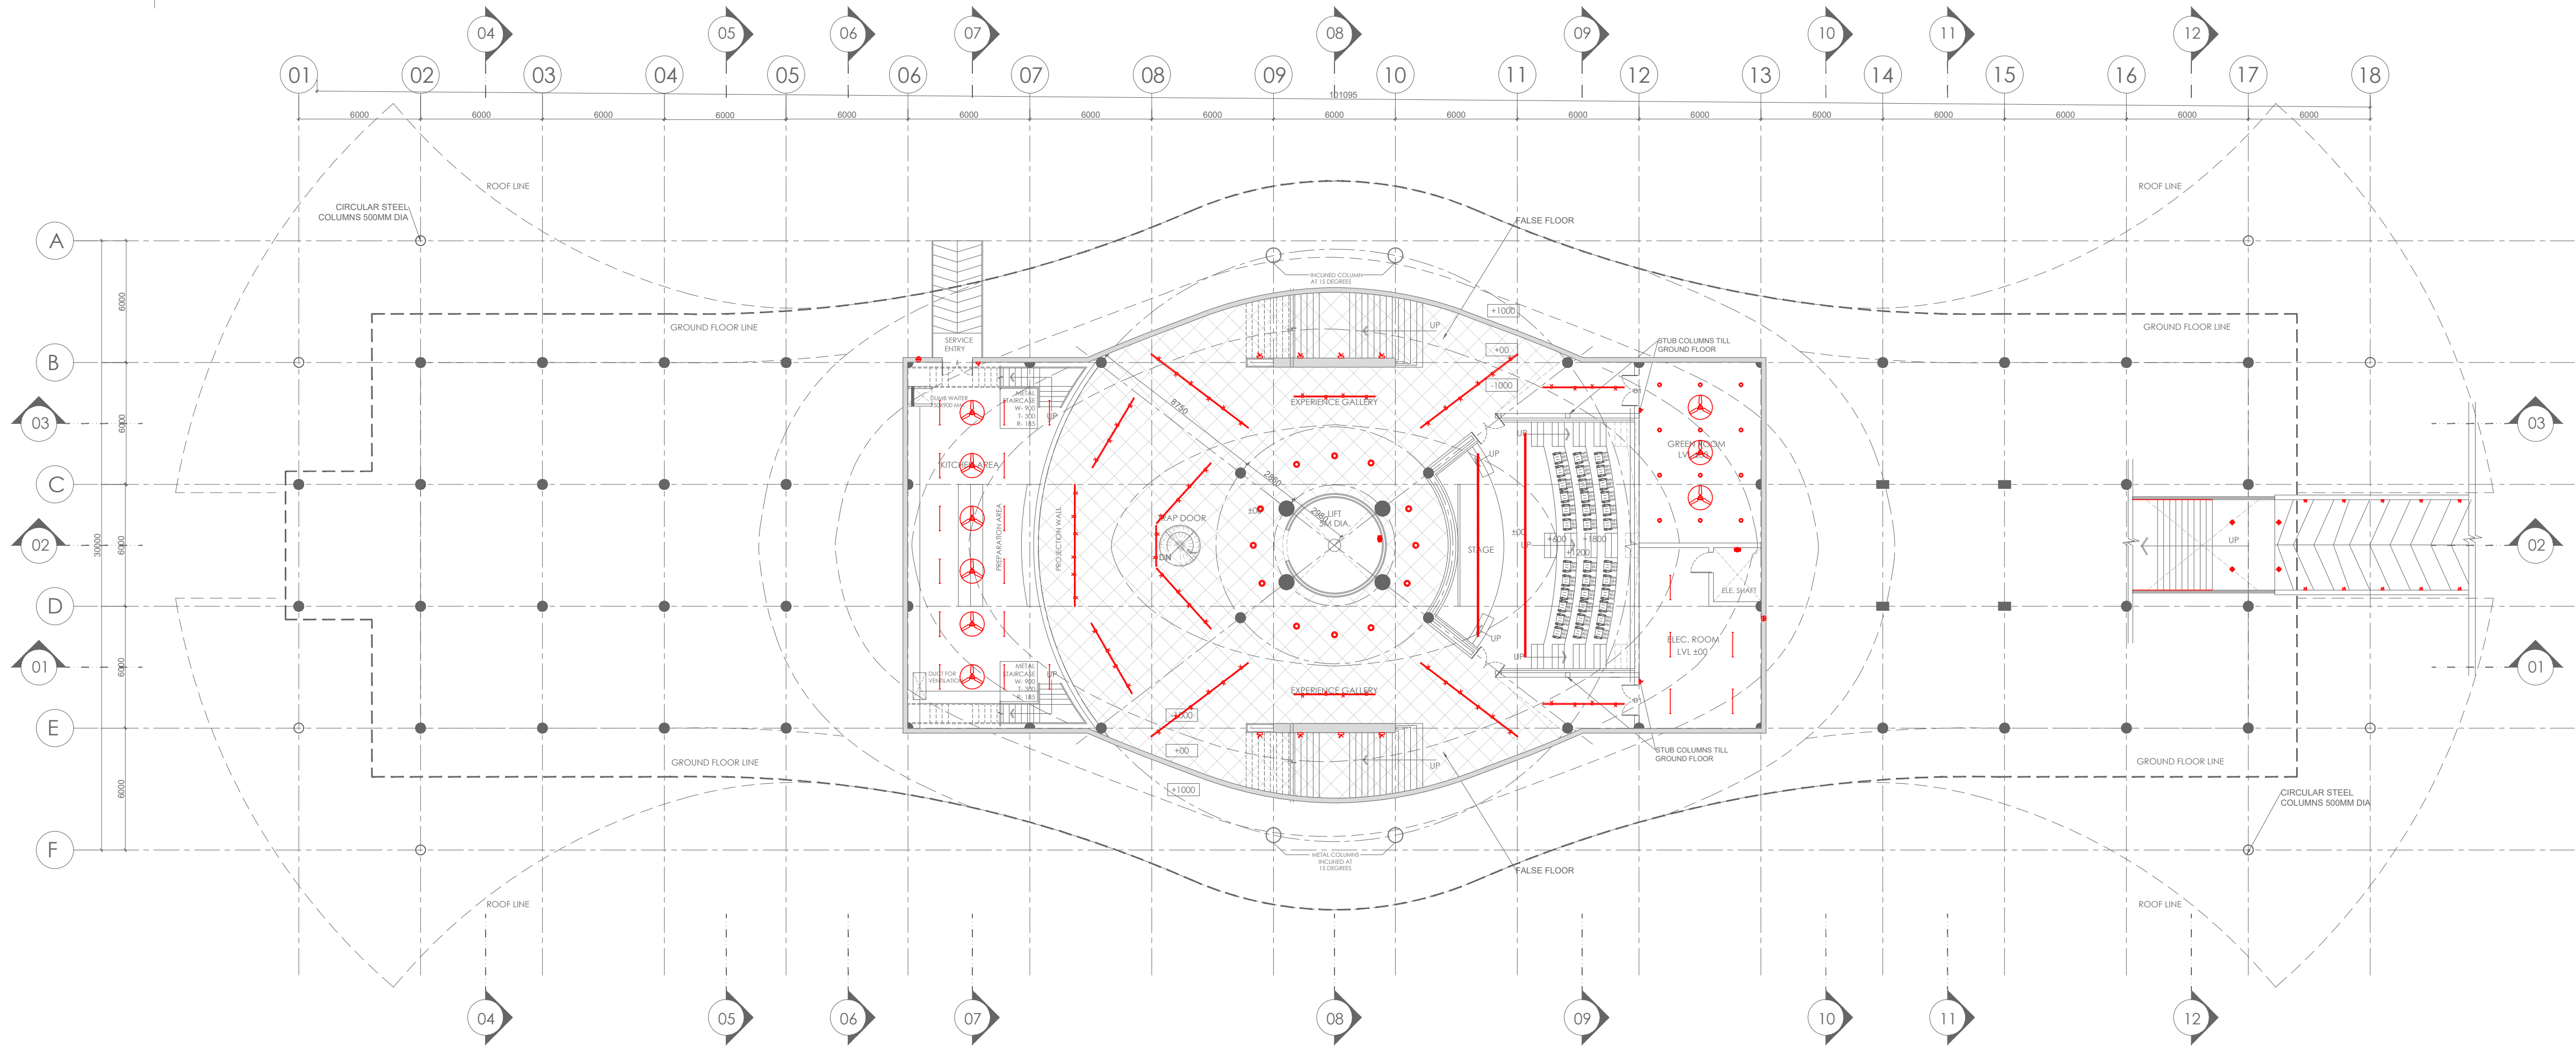

LOWER GROUND FLOOR PLAN

LEGEND		
SYMBOL	DESCRIPTION	MOUNTING HEIGHT ABOVE FFL (FROM BOTTOM OF SWITCH BOARD)
SWITCH 1 WAY		1000mm AFFL (150mm FROM DOOR FRAME)
SWITCH 2 WAY		1000mm AFFL (150mm FROM DOOR FRAME)
10 WATT LED LIGHT		SURFACE MOUNTED
18 WATT LED LIGHT		SURFACE MOUNTED
32 WATT LED LIGHT		SURFACE MOUNTED
TRACK LIGHT - 1 METER		SURFACE / WALL MOUNTED
TRACK LIGHT - 2 METER		SURFACE / WALL MOUNTED
44 WATT LED LINEAR LIGHT		SUSPENDED / SURFACE
LIGHT POINT		WALL @ 2150mm
40 WATT LED TUBE LIGHT-4FT		SURFACE / WALL MOUNTED
10 WATT LED STRIP LIGHT		
28 WATT LED CIRCULAR LIGHT		
10 WATT LED BULK HEAD LIGHT		WALL MOUNTED @2100mm
5 WATT LED STEP LIGHT		WALL MOUNTED @ 300mm AFFL/TREAD
5 WATT LED SPIKE LIGHT		GROUND EMBEDDED
CEILING FAN - 1200mm		SUSPENDED MOUNTED
EXHAUST FAN - 200mm		WALL MOUNTED
26 WATT LED LIGHT		FLOOR MOUNTED
100 WATT LED FLOOD LIGHT		SURFACE / WALL MOUNTED
ELECTRICAL DB		MOUNTED ON WALL (TOP OF DB 1800MM FROM FFL)

TENDER DRAWING

- NOTES:
- DO NOT SCALE THE DRAWING. FOLLOW ONLY FIGURED DIMENSIONS
 - ALL DIMENSIONS GIVEN IN THIS DRAWING ARE IN MILLIMETERS UNLESS NOTED OTHERWISE.
 - ALL DIMENSIONS TO BE VERIFIED ON SITE AND APPROVED BY THE SITE ENGINEER
 - ANY DISCREPANCY OR AMBIGUITY IN THE DRAWINGS SHOULD IMMEDIATELY BE BROUGHT TO NOTICE OF THE ARCHITECT
 - ALL DRAWINGS SHOULD BE READ IN CONJUNCTION WITH OTHER RELEVANT ARCHITECTURAL, STRUCTURAL, PLUMBING, MECHANICAL AND ELECTRICAL DRAWINGS.
 - THE # 0 REFERS TO LEVEL ESTABLISHED AT SITE IN PRESENCE OF THE SITE SUPERVISOR AND THE ARCHITECT. ALL REMAINING LEVELS ARE RELATIVE TO THIS LEVEL.
 - THIS DRAWING IS THE COPYRIGHT OF ARCHOHM CONSULTANTS
 - AND MUST NOT BE RETAINED, COPIED OR USED WITHOUT THEIR AUTHORITY.

REVISIONS			
No.	Date	Descriptions	Revision by

Client:
MEGHALAYAN AGE LIMITED (MAL)

Project:
TRIBAL HERITAGE CENTRE, MANDALGRE, MEGHALAYA

Architects:



Structural Consultants:

TPC TECHNICAL PROJECTS CONSULTANTS PVT. LTD.
C-286, SECTION 8, MIDC, PUNE - 411 005 (INDIA)
T: 91 20 42 48 7888
F: 91 20 42 48 7889
www.archohm.com

Electrical Consultants:

ARCHOHM CONSULTANTS PVT. LTD.
C-286, SECTION 8, MIDC, PUNE - 411 005 (INDIA)
T: 91 20 42 48 7888
F: 91 20 42 48 7889
www.archohm.com

M/E Consultants:

WVAC Engineers INDIA PVT. LTD.
MEP Consultants & Project Managers
P: +91-8448444444
E: mep@wvacindia.com

Drawn By

CK

Checked By

AKD

Design By

AKD

Sheet Title:
**EXHIBITION & RESEARCH CENTRE
LOWER GROUND & GROUND FLOOR PLAN
LIGHTING LAYOUT**

Date:

25-08-2024

Scale:

1:200

Project No.:


A-232409

Drawing No.:

E-232409-B1-03-02

A1

R0

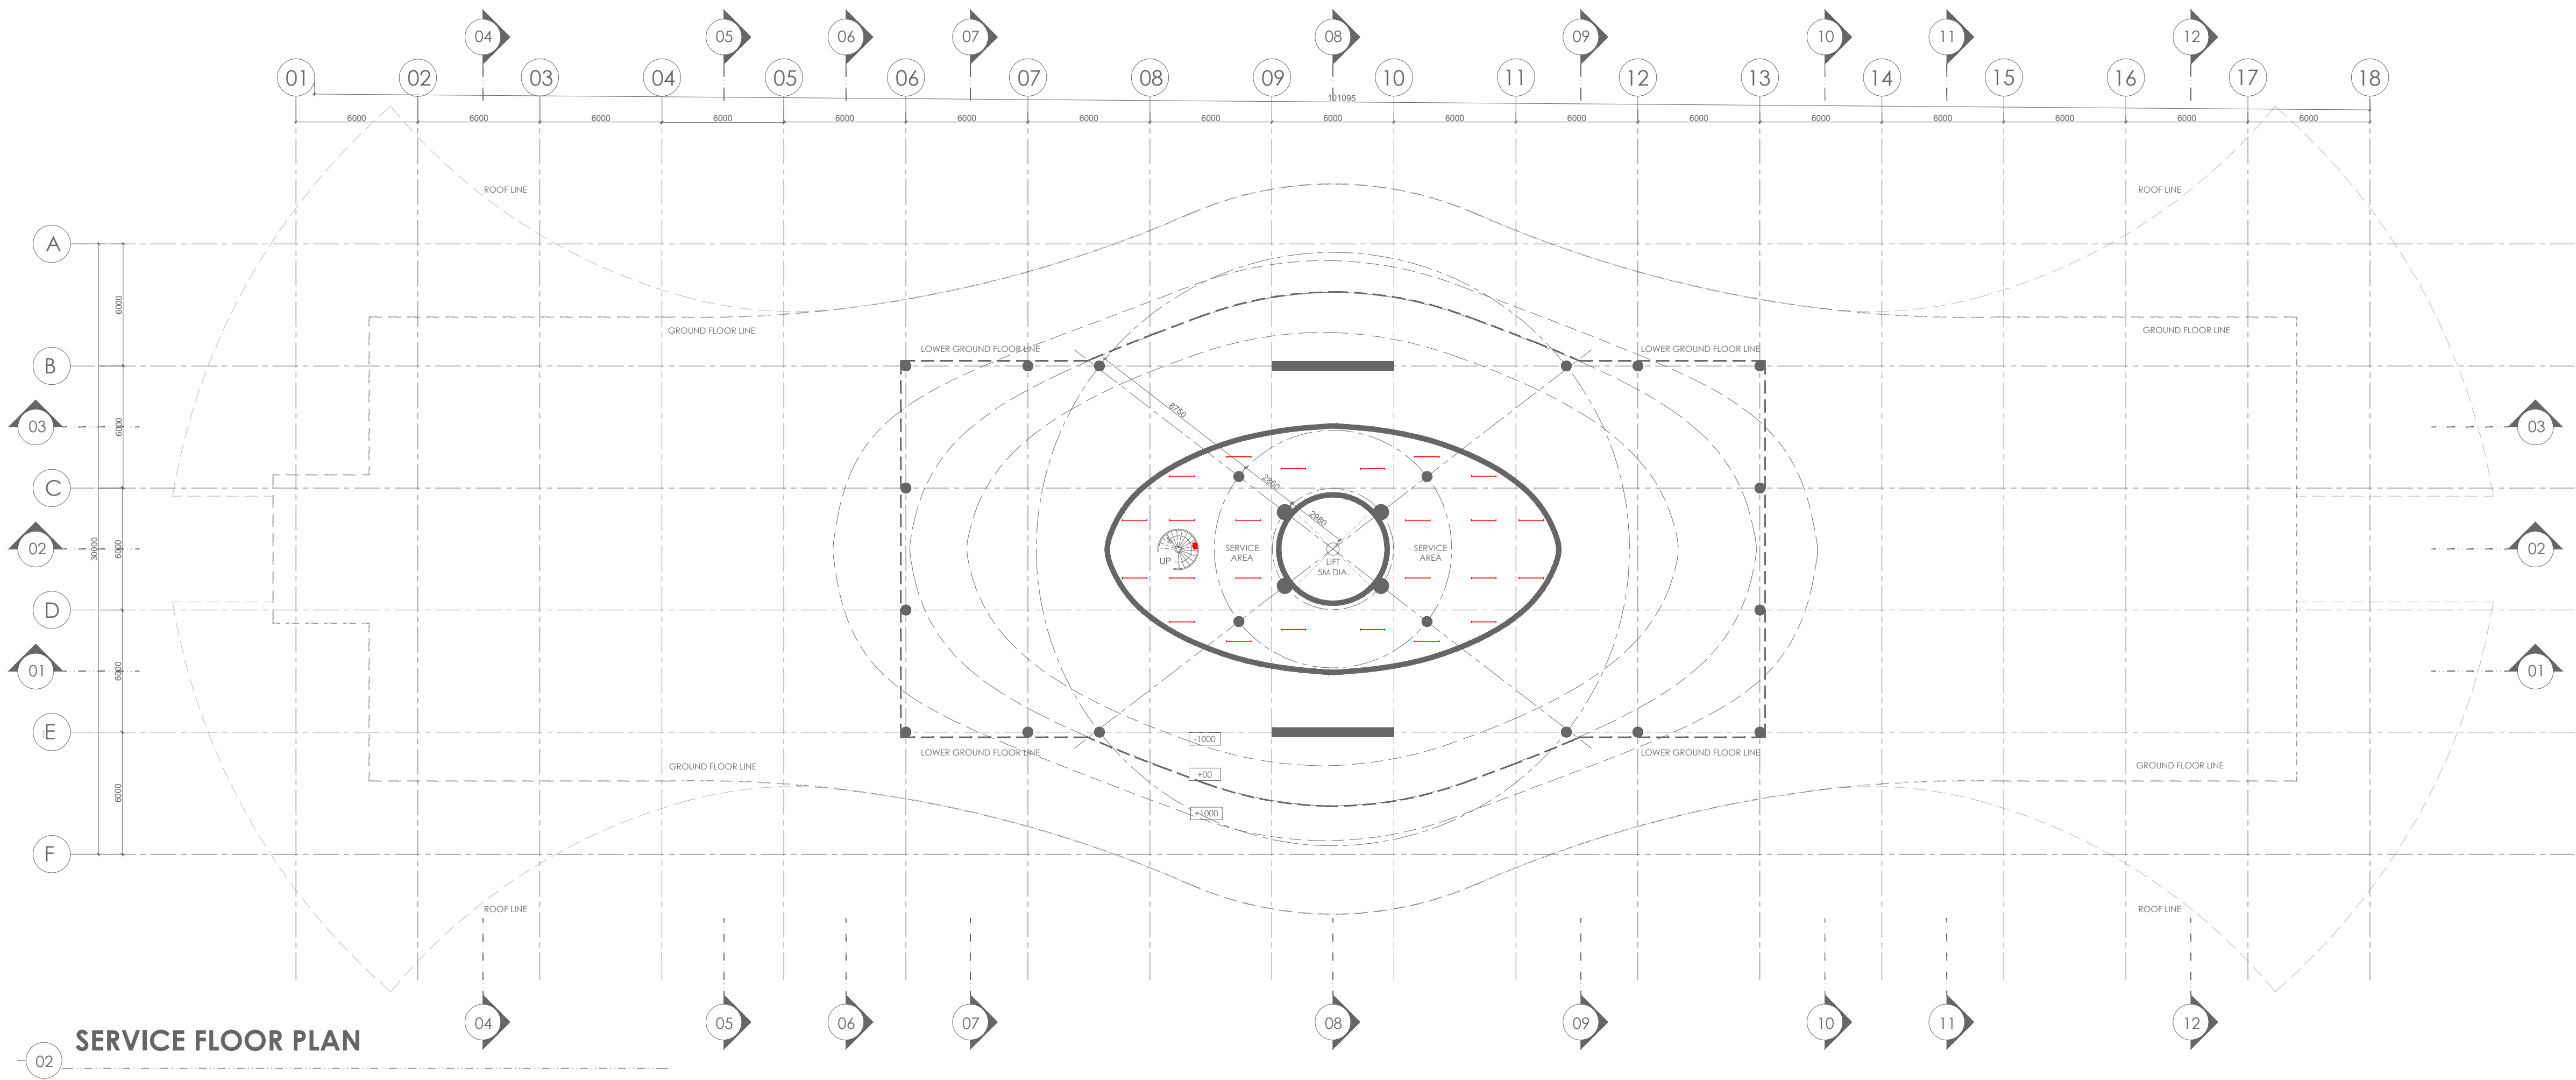

LEGEND		
SYMBOL	DESCRIPTION	MOUNTING HEIGHT ABOVE FFL (FROM BOTTOM OF SWITCH BOARD)
SWITCH 1 WAY		1000mm AFFL (150mm FROM DOOR FRAME)
SWITCH 2 WAY		1000mm AFFL (150mm FROM DOOR FRAME)
10 WATT LED LIGHT		SURFACE MOUNTED
18 WATT LED LIGHT		SURFACE MOUNTED
32 WATT LED LIGHT		SURFACE MOUNTED
TRACK LIGHT - 1 METER		SURFACE / WALL MOUNTED
TRACK LIGHT - 2 METER		SURFACE / WALL MOUNTED
44 WATT LED LINEAR LIGHT		SUSPENDED / SURFACE
LIGHT POINT		WALL @ 2150mm
40 WATT LED TUBE LIGHT-4FT		SURFACE / WALL MOUNTED
10 WATT LED STRIP LIGHT		
28 WATT LED CIRCULAR LIGHT		
10 WATT LED BULK HEAD LIGHT		WALL MOUNTED @2100mm
5 WATT LED STEP LIGHT		WALL MOUNTED @ 300mm AFFL/TREAD
5 WATT LED SPIKE LIGHT		GROUND EMBEDDED
CEILING FAN - 1200mm		SUSPENDED MOUNTED
EXHAUST FAN - 200mm		WALL MOUNTED
26 WATT LED LIGHT		FLOOR MOUNTED
100 WATT LED FLOOD LIGHT		SURFACE / WALL MOUNTED
ELECTRICAL DB		MOUNTED ON WALL (TOP OF DB 1800MM FROM FFL)

TENDER DRAWING

NOTES:

- DO NOT SCALE THE DRAWING. FOLLOW ONLY FIGURED DIMENSIONS
- ALL DIMENSIONS GIVEN IN THIS DRAWING ARE IN MILLIMETERS UNLESS NOTED OTHERWISE.
- ALL DIMENSIONS TO BE VERIFIED ON SITE AND APPROVED BY THE SITE ENGINEER
- ANY DISCREPANCY OR AMBIGUITY IN THE DRAWINGS SHOULD IMMEDIATELY BE BROUGHT TO NOTICE OF THE ARCHITECT
- ALL DRAWINGS SHOULD BE READ IN CONJUNCTION WITH OTHER RELEVANT ARCHITECTURAL, STRUCTURAL, PLUMBING, MECHANICAL AND ELECTRICAL DRAWINGS.
- THE ± 0 REFERS TO LEVEL ESTABLISHED AT SITE IN PRESENCE OF THE SITE SUPERVISOR AND THE ARCHITECT. ALL REMAINING LEVELS ARE RELATIVE TO THIS LEVEL.
- THIS DRAWING IS THE COPYRIGHT OF ARCHOHM CONSULTANTS AND MUST NOT BE RETAINED, COPIED OR USED WITHOUT THEIR AUTHORITY.

REVISIONS

No.	Date	Descriptions	Revision by

Client:

MEGHALAYAN AGE LIMITED (MAL)

Project:

TRIBAL HERITAGE CENTRE, MANDALGRE, MEGHALAYA

Architects:



©2016, section 41
register - 201/2016/1601
1 91 120 46 40 300
1 91 120 42 48 788
mail@archohm.com
www.archohm.com

Structural Consultants:

TPC TECHNICAL PROJECTS
CONSULTANTS(P) LTD.
H/O: B-14, Sector 02, Noida, Uttar Pradesh
201301
BOMBAY NO. 91/120/408800

Electrical Consultants:

ARCHOHM CONSULTANT
PVT. LTD.
B-14, Sector 02, Noida, Uttar Pradesh
201301
BOMBAY NO. 91/120/408800

M/E Consultants:

WAC Engineers
INDIA PVT. LTD.
MEP Consultants &
Project Managers
P-103, 4th Floor,
B-14, Sector 02, Noida, Uttar Pradesh
201301

Drawn By

CK

Checked By

AKD

Design By

AKD

Sheet Title:

EXHIBITION & RESEARCH CENTRE
SERVICE FLOOR PLAN
LIGHTING LAYOUT

Date:

25-08-2024

Scale:

1:200

Drawing No.:


E-232409-B1-03-01

Project No.:


A-232409

Sheet No.:

A1 R0

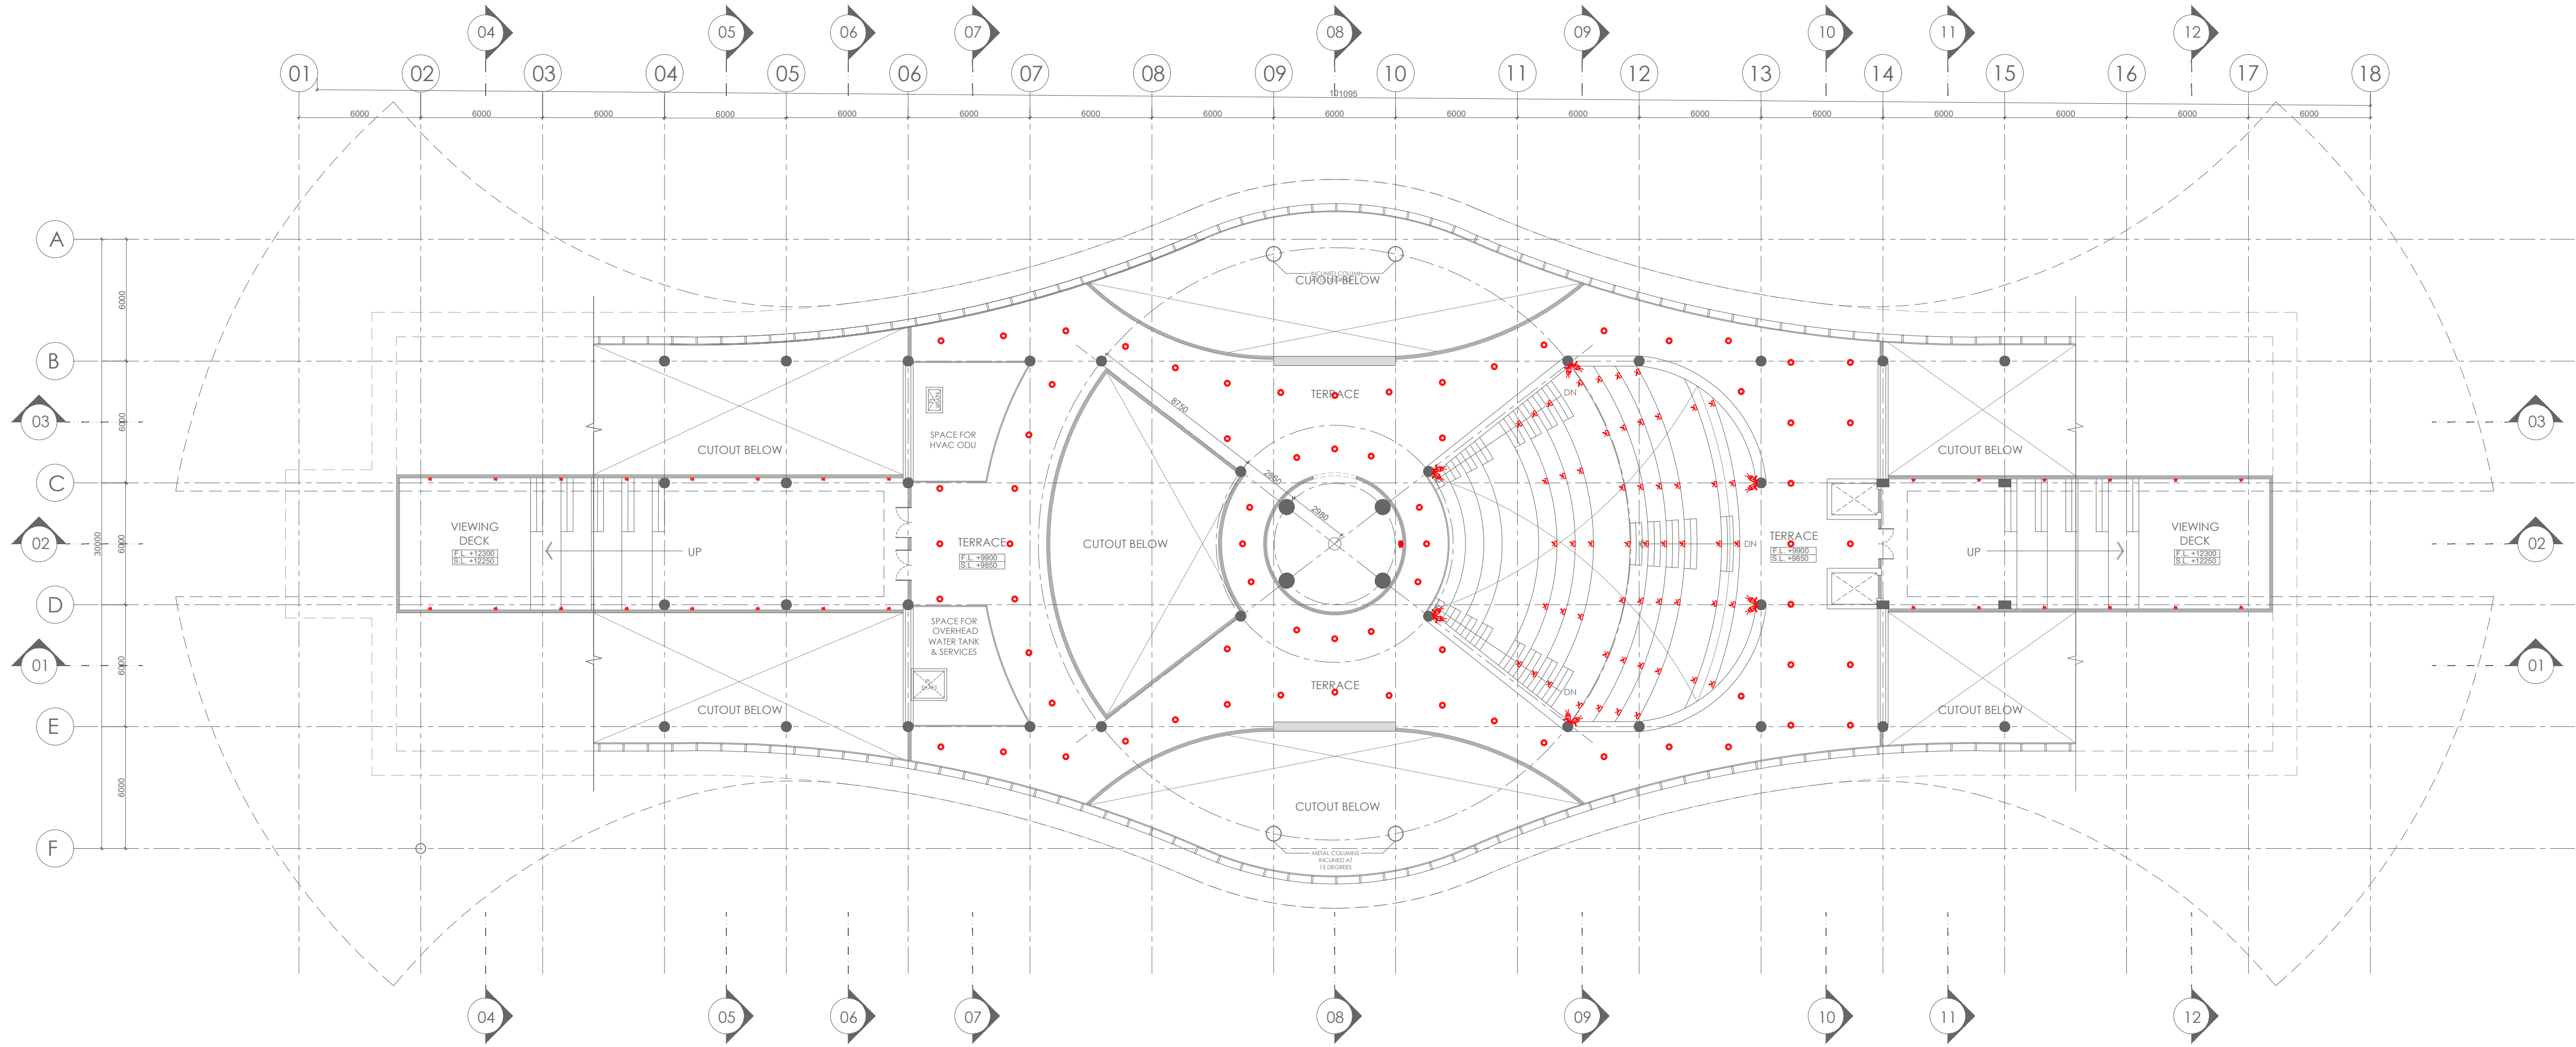

USABLE TERRACE PLAN

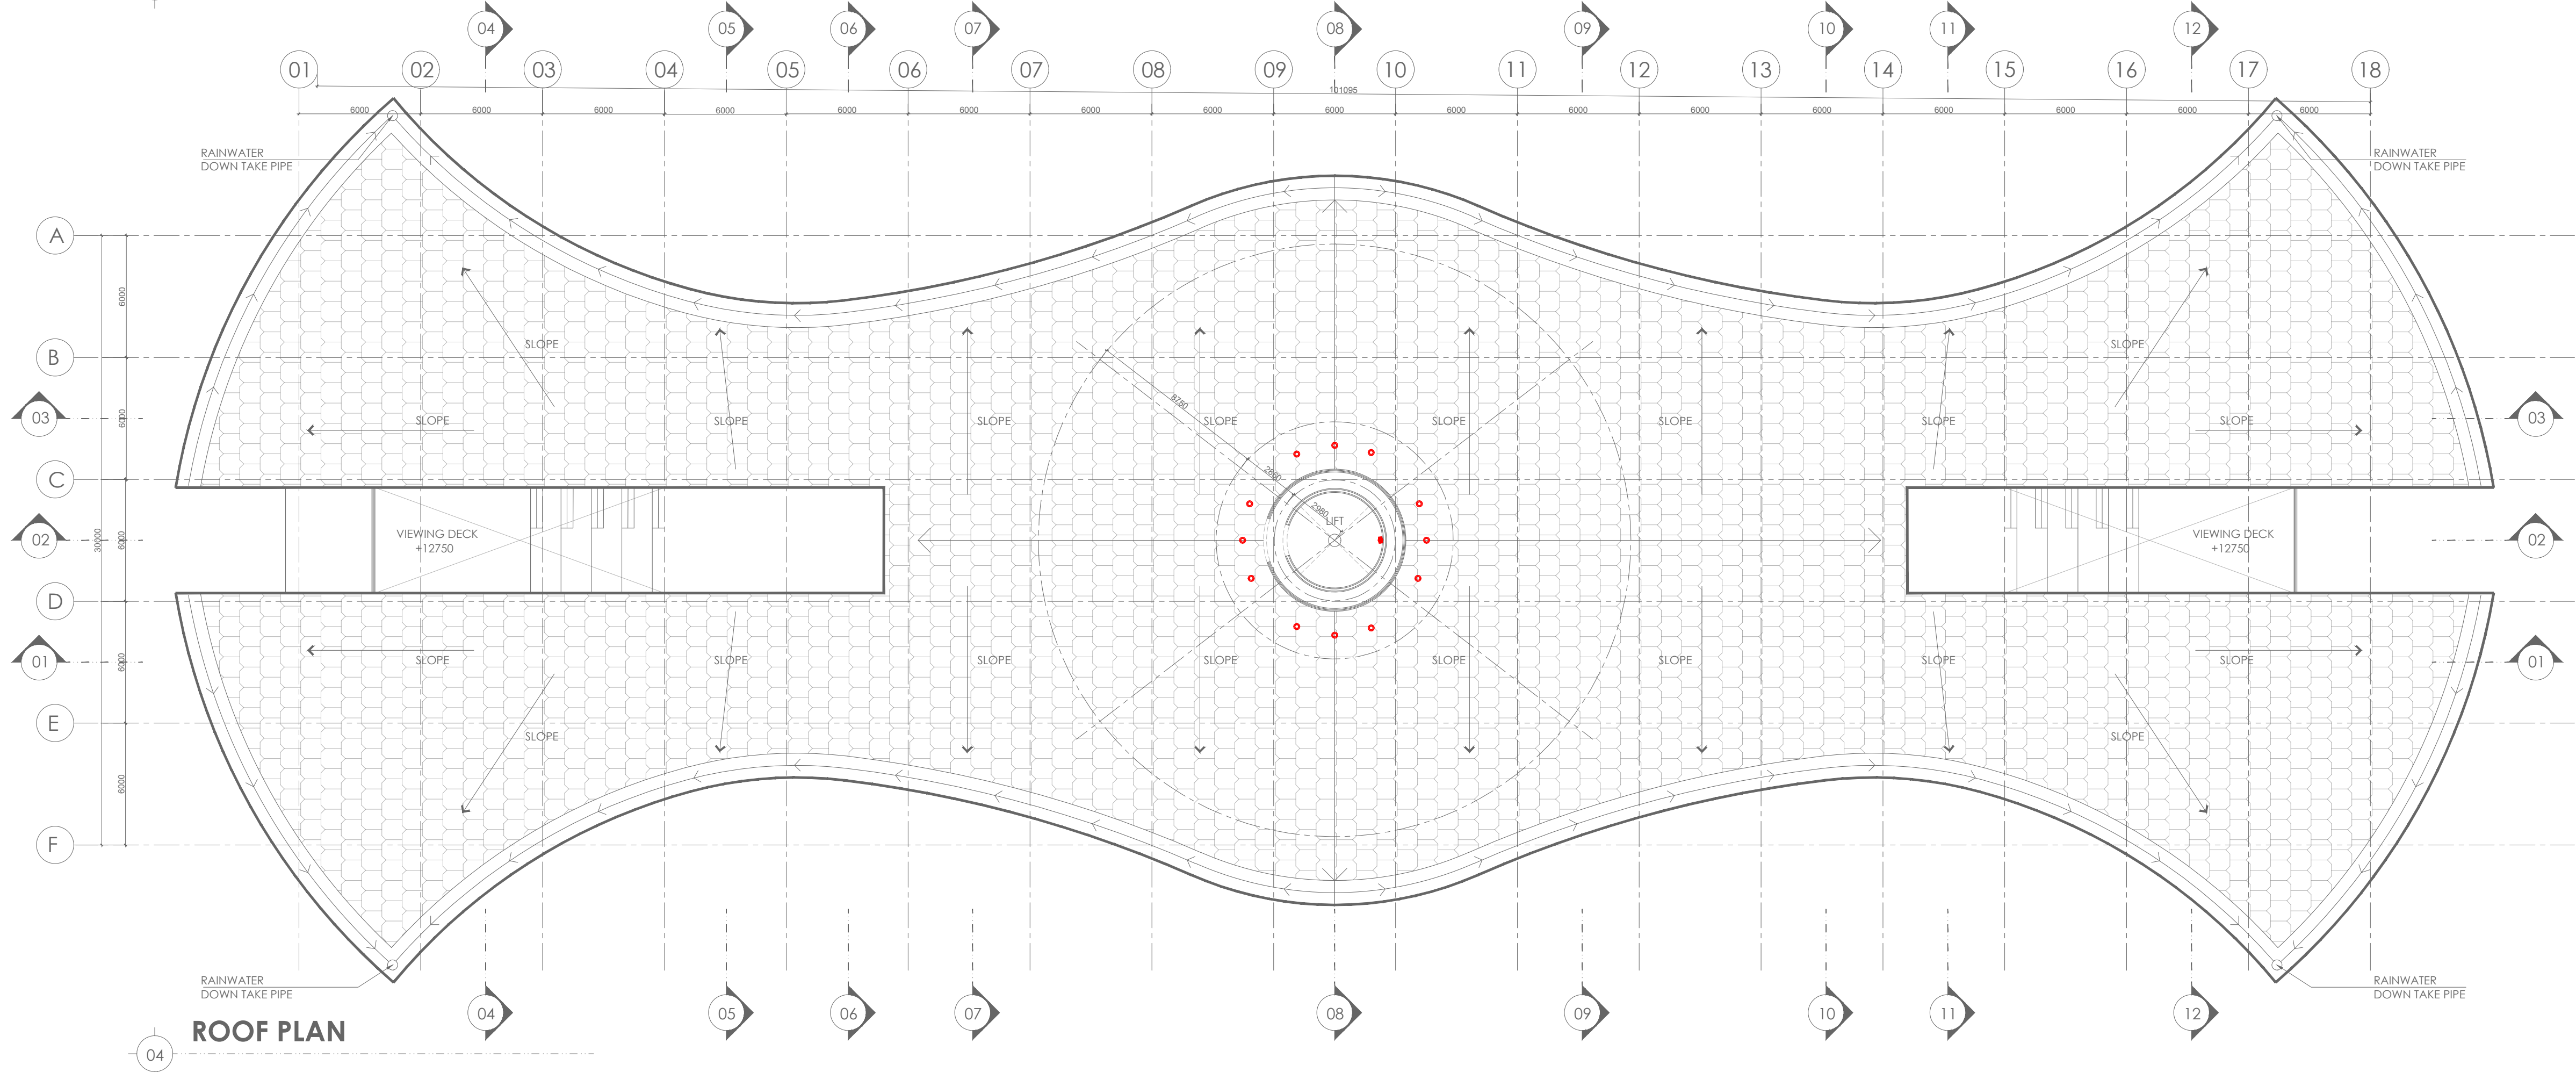

ROOF PLAN

LEGEND		
SYMBOL	DESCRIPTION	MOUNTING HEIGHT ABOVE FFL (FROM BOTTOM OF SWITCH BOARD)
SWITCH 1 WAY		1000mm AFFL (150mm FROM DOOR FRAME)
SWITCH 2 WAY		1000mm AFFL (150mm FROM DOOR FRAME)
10 WATT LED LIGHT		SURFACE MOUNTED
18 WATT LED LIGHT		SURFACE MOUNTED
32 WATT LED LIGHT		SURFACE MOUNTED
TRACK LIGHT - 1 METER		SURFACE / WALL MOUNTED
TRACK LIGHT - 2 METER		SURFACE / WALL MOUNTED
44 WATT LED LINEAR LIGHT		SUSPENDED / SURFACE
LIGHT POINT		WALL @ 2150mm
40 WATT LED TUBE LIGHT-4FT		SURFACE / WALL MOUNTED
10 WATT LED STRIP LIGHT		
28 WATT LED CIRCULAR LIGHT		
10 WATT LED BULK HEAD LIGHT		WALL MOUNTED @2100mm
5 WATT LED STEP LIGHT		WALL MOUNTED @ 300mm AFFL/TREAD
5 WATT LED SPIKE LIGHT		GROUND EMBEDDED
CEILING FAN - 1200mm		SUSPENDED MOUNTED
EXHAUST FAN - 200mm		WALL MOUNTED
26 WATT LED LIGHT		FLOOR MOUNTED
100 WATT LED FLOOD LIGHT		SURFACE / WALL MOUNTED
ELECTRICAL DB		MOUNTED ON WALL (TOP OF DB 1800MM FROM FFL)

TENDER DRAWING

NOTES:

- DO NOT SCALE THE DRAWING. FOLLOW ONLY FIGURED DIMENSIONS
- ALL DIMENSIONS GIVEN IN THIS DRAWING ARE IN MILLIMETERS UNLESS NOTED OTHERWISE.
- ALL DIMENSIONS TO BE VERIFIED ON SITE AND APPROVED BY THE SITE ENGINEER.
- ANY DISCREPANCY OR AMBIGUITY IN THE DRAWINGS SHOULD IMMEDIATELY BE BROUGHT TO NOTICE OF THE ARCHITECT.
- ALL DRAWINGS SHOULD BE READ IN CONJUNCTION WITH OTHER RELEVANT ARCHITECTURAL, STRUCTURAL, PLUMBING, MECHANICAL AND ELECTRICAL DRAWINGS.
- THE ± 0 REFERS TO LEVEL ESTABLISHED AT SITE IN PRESENCE OF THE SITE SUPERVISOR AND THE ARCHITECT. ALL REMAINING LEVELS ARE RELATIVE TO THIS LEVEL.
- THIS DRAWING IS THE COPYRIGHT OF ARCHOHM CONSULTANTS AND MUST NOT BE RETAINED, COPIED OR USED WITHOUT THEIR AUTHORITY.

REVISIONS

No.	Date	Descriptions	Revision by

Client:

MEGHALAYAN AGE LIMITED (MAL)

Project:

TRIBAL HERITAGE CENTRE, MANDALGRE, MEGHALAYA

Architects:



Structural Consultants:



Electrical Consultants:



M/E Consultants:



Drawn By

CK

Checked By

AKD

Design By

AKD

Sheet Title:

EXHIBITION & RESEARCH CENTRE
USABLE TERRACE & ROOF FLOOR PLAN
LIGHTING LAYOUT

Date:

25-08-2024

Drawing No.:

E-232409-B1-03-03

Scale:


1:200

Project No.:


A-232409

A1

R0

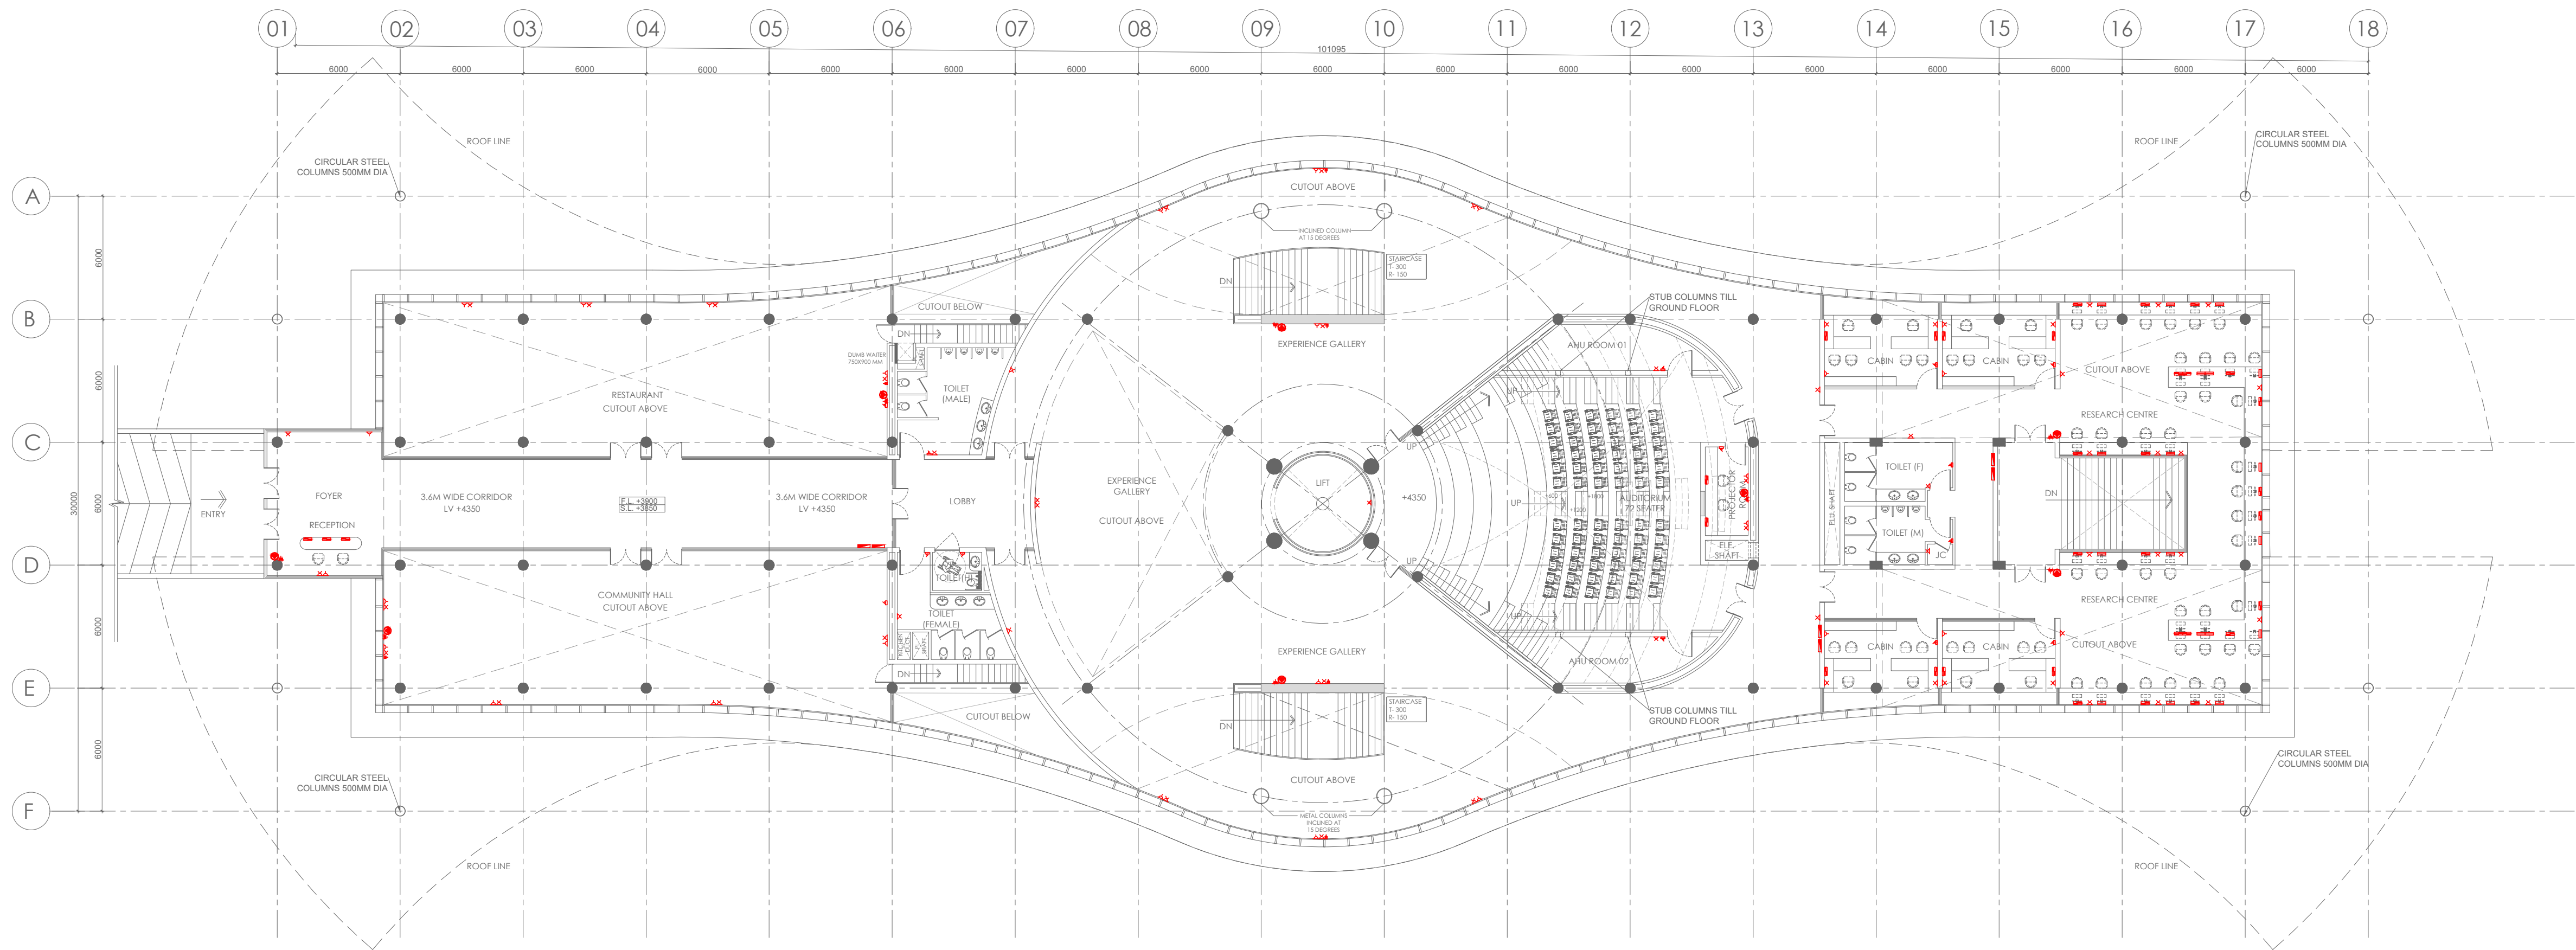

GROUND FLOOR PLAN

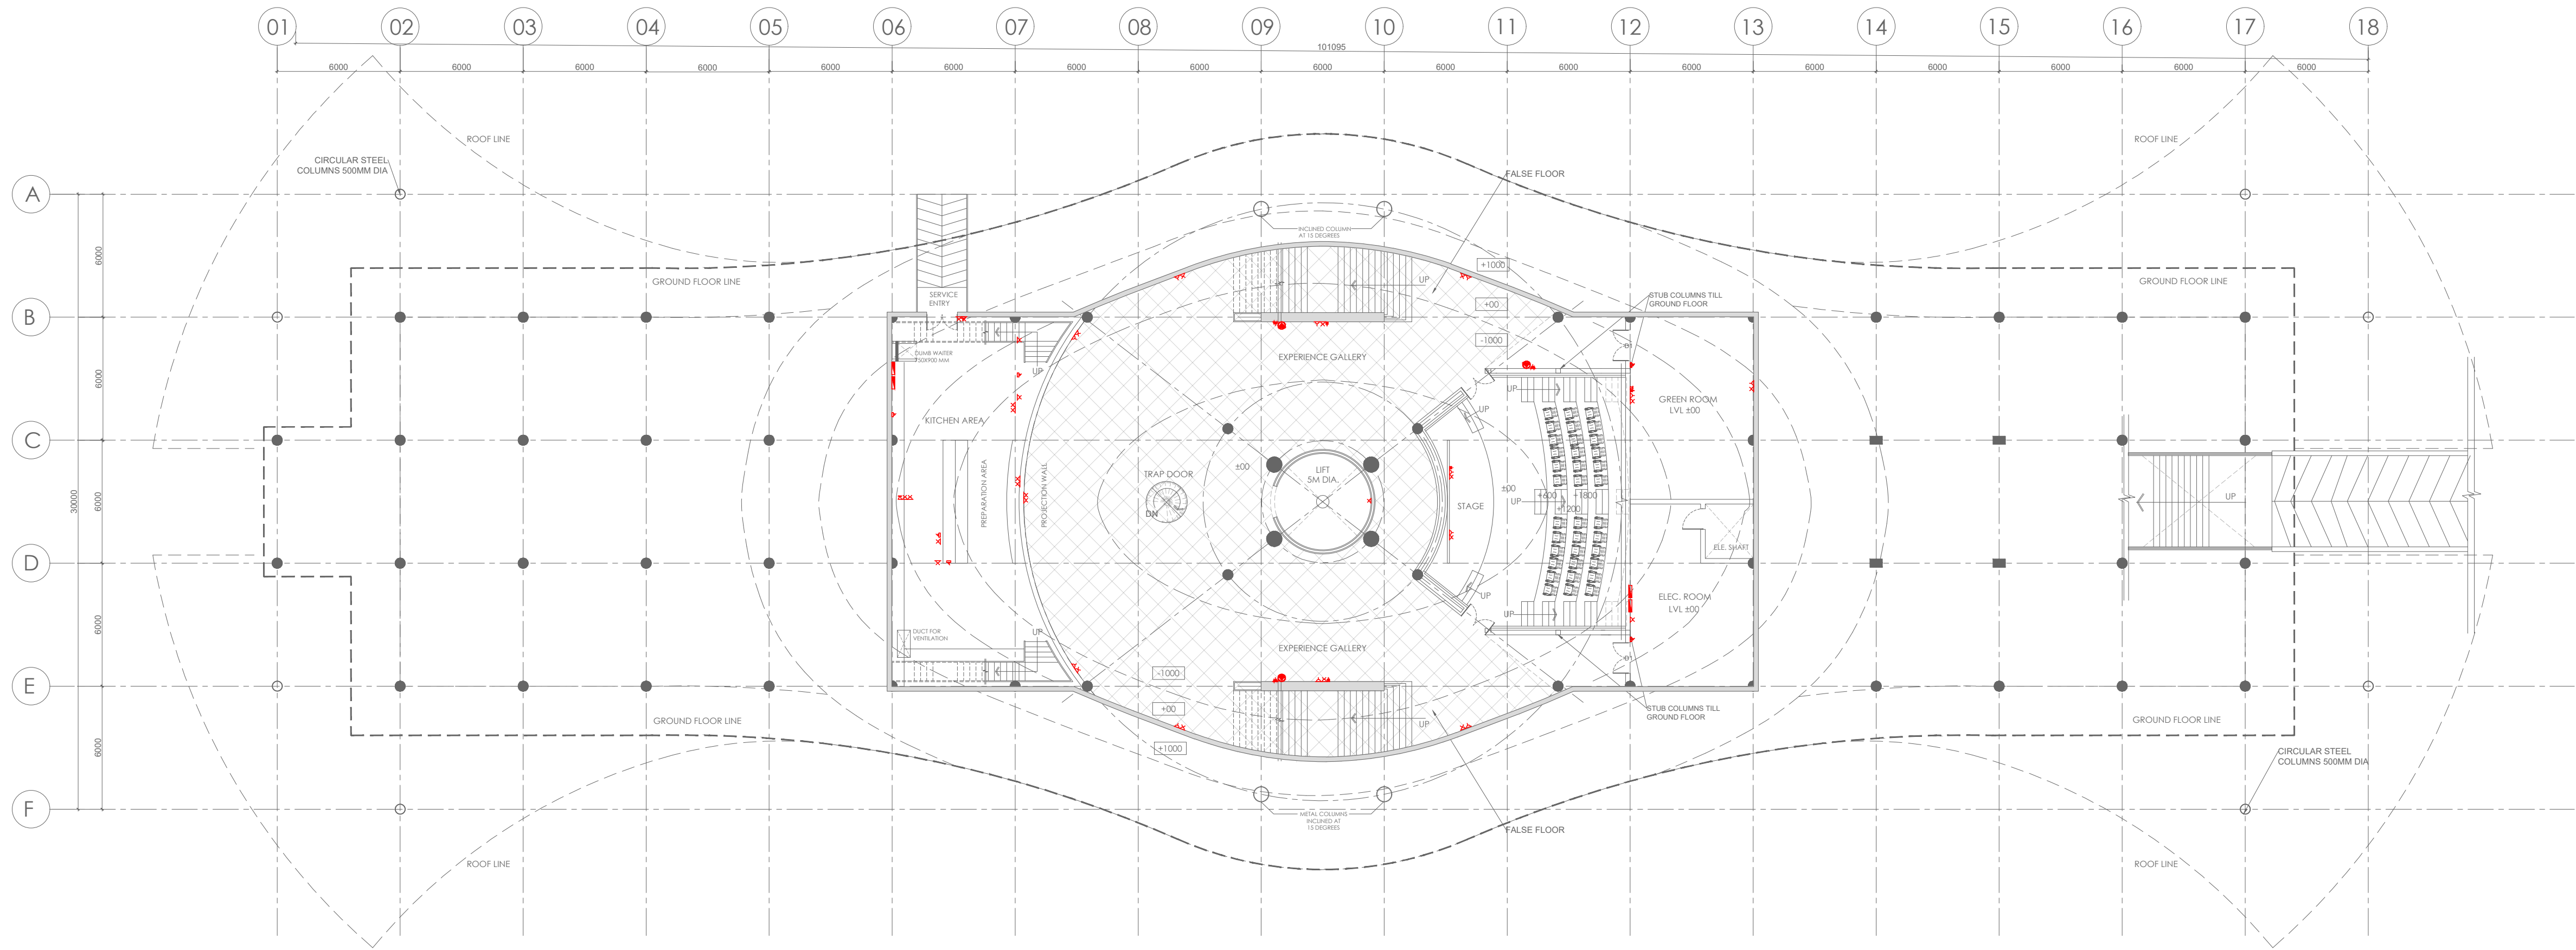

LOWER GROUND FLOOR PLAN

LEGEND	
SYMBOL	DESCRIPTION
	SWITCH 1 WAY
	SWITCH 2 WAY
	6A SWITCH SOCKET
	16A SWITCH SOCKET
	16A SWITCH SOCKET FOR GYSE
	16A SWITCH SOCKET FOR AC
	6A SWITCH SOCKET (UPS POWER)
	TV SOCKET
	TELEPHONE SOCKET
	LAN SOCKET
	WI-FI ROUTER (CAT6)
	ELECTRICAL DB
MOUNTING HEIGHT ABOVE FFL (FROM BOTTOM OF SW SOCKET)	
1250mm AFFL (150mm FROM DOOR FRAME)	
1250mm AFFL (150mm FROM DOOR FRAME)	
230MM OR AS MENTION	
230MM OR AS MENTION	
2000MM	
2150MM OR AS MENTION	
230MM OR AS MENTION	
1100MM OR AS MENTION	
230MM OR AS MENTION	
230MM OR AS MENTION	
TABLE TOP / WALL @ 980mm	
TABLE TOP / WALL @ 980mm	
WALL @ 300mm DOWN FROM CEILING	
MOUNTED ON WALL (TOP OF DB 1800MM FROM FFL)	

- NOTES:
- DO NOT SCALE THE DRAWING. FOLLOW ONLY FIGURED DIMENSIONS.
 - ALL DIMENSIONS GIVEN IN THIS DRAWING ARE IN MILLIMETERS UNLESS NOTED OTHERWISE.
 - ALL DIMENSIONS TO BE VERIFIED ON SITE AND APPROVED BY THE SITE ENGINEER.
 - ANY DISCREPANCY OR AMBIGUITY IN THE DRAWINGS SHOULD IMMEDIATELY BE BROUGHT TO NOTICE OF THE ARCHITECT.
 - ALL DRAWINGS SHOULD BE READ IN CONJUNCTION WITH OTHER RELEVANT ARCHITECTURAL, STRUCTURAL, PLUMBING, MECHANICAL AND ELECTRICAL DRAWINGS.
 - THE ± 0 REFERS TO LEVEL ESTABLISHED AT SITE IN PRESENCE OF THE SITE SUPERVISOR AND THE ARCHITECT. ALL REMAINING LEVELS ARE RELATIVE TO THIS LEVEL.
 - THIS DRAWING IS THE COPYRIGHT OF ARCHOHM CONSULTANTS PVT. LTD.
 - AND MUST NOT BE RETAINED, COPIED OR USED WITHOUT THEIR AUTHORITY.

REVISIONS			
No.	Date	Descriptions	Revision by

Client:
MEGHALAYAN AGE LIMITED (MAL)

Project:
TRIBAL HERITAGE CENTRE, MANDALGRE, MEGHALAYA

Architects:



©2024, section 8,
register - 2017/2018/1601
1 91 120 46 40 300
1 91 120 42 48 788
mail@archohm.com
www.archohm.com

Structural Consultants:

TPC TECHNICAL PROJECTS CONSULTANTS PVT. LTD.
H/O: B-14, Sector 02, Noida, Uttar Pradesh
201301
Phone: 0120-4244174
Mobile: 9810044444
BOMBO NO: 01-120-400000

Electrical Consultants:

ARCHOHM CONSULTANT PVT. LTD.
H/O: B-14, Sector 02, Noida, Uttar Pradesh
201301
Phone: 0120-4244174
Mobile: 9810044444
BOMBO NO: 01-120-400000

M/E Consultants:

WAC Engineers INDIA PVT. LTD.
MEP Consultants & Project Managers
P/O: 10/2, Sector 02, Noida, Uttar Pradesh
201301
Phone: 0120-4244174
Mobile: 9810044444
BOMBO NO: 01-120-400000

Drawn By

CK

Checked By

AKD

Design By

AKD

Sheet Title:
**EXHIBITION & RESEARCH CENTRE
LOWER GROUND & GROUND FLOOR PLAN
SW SOCKET LAYOUT**

Date:

25-08-2024

Drawing No.:

E-232409-B1-04-02

Scale:


1:200

Project No.:

A-232409

Project Title:

A1 R0

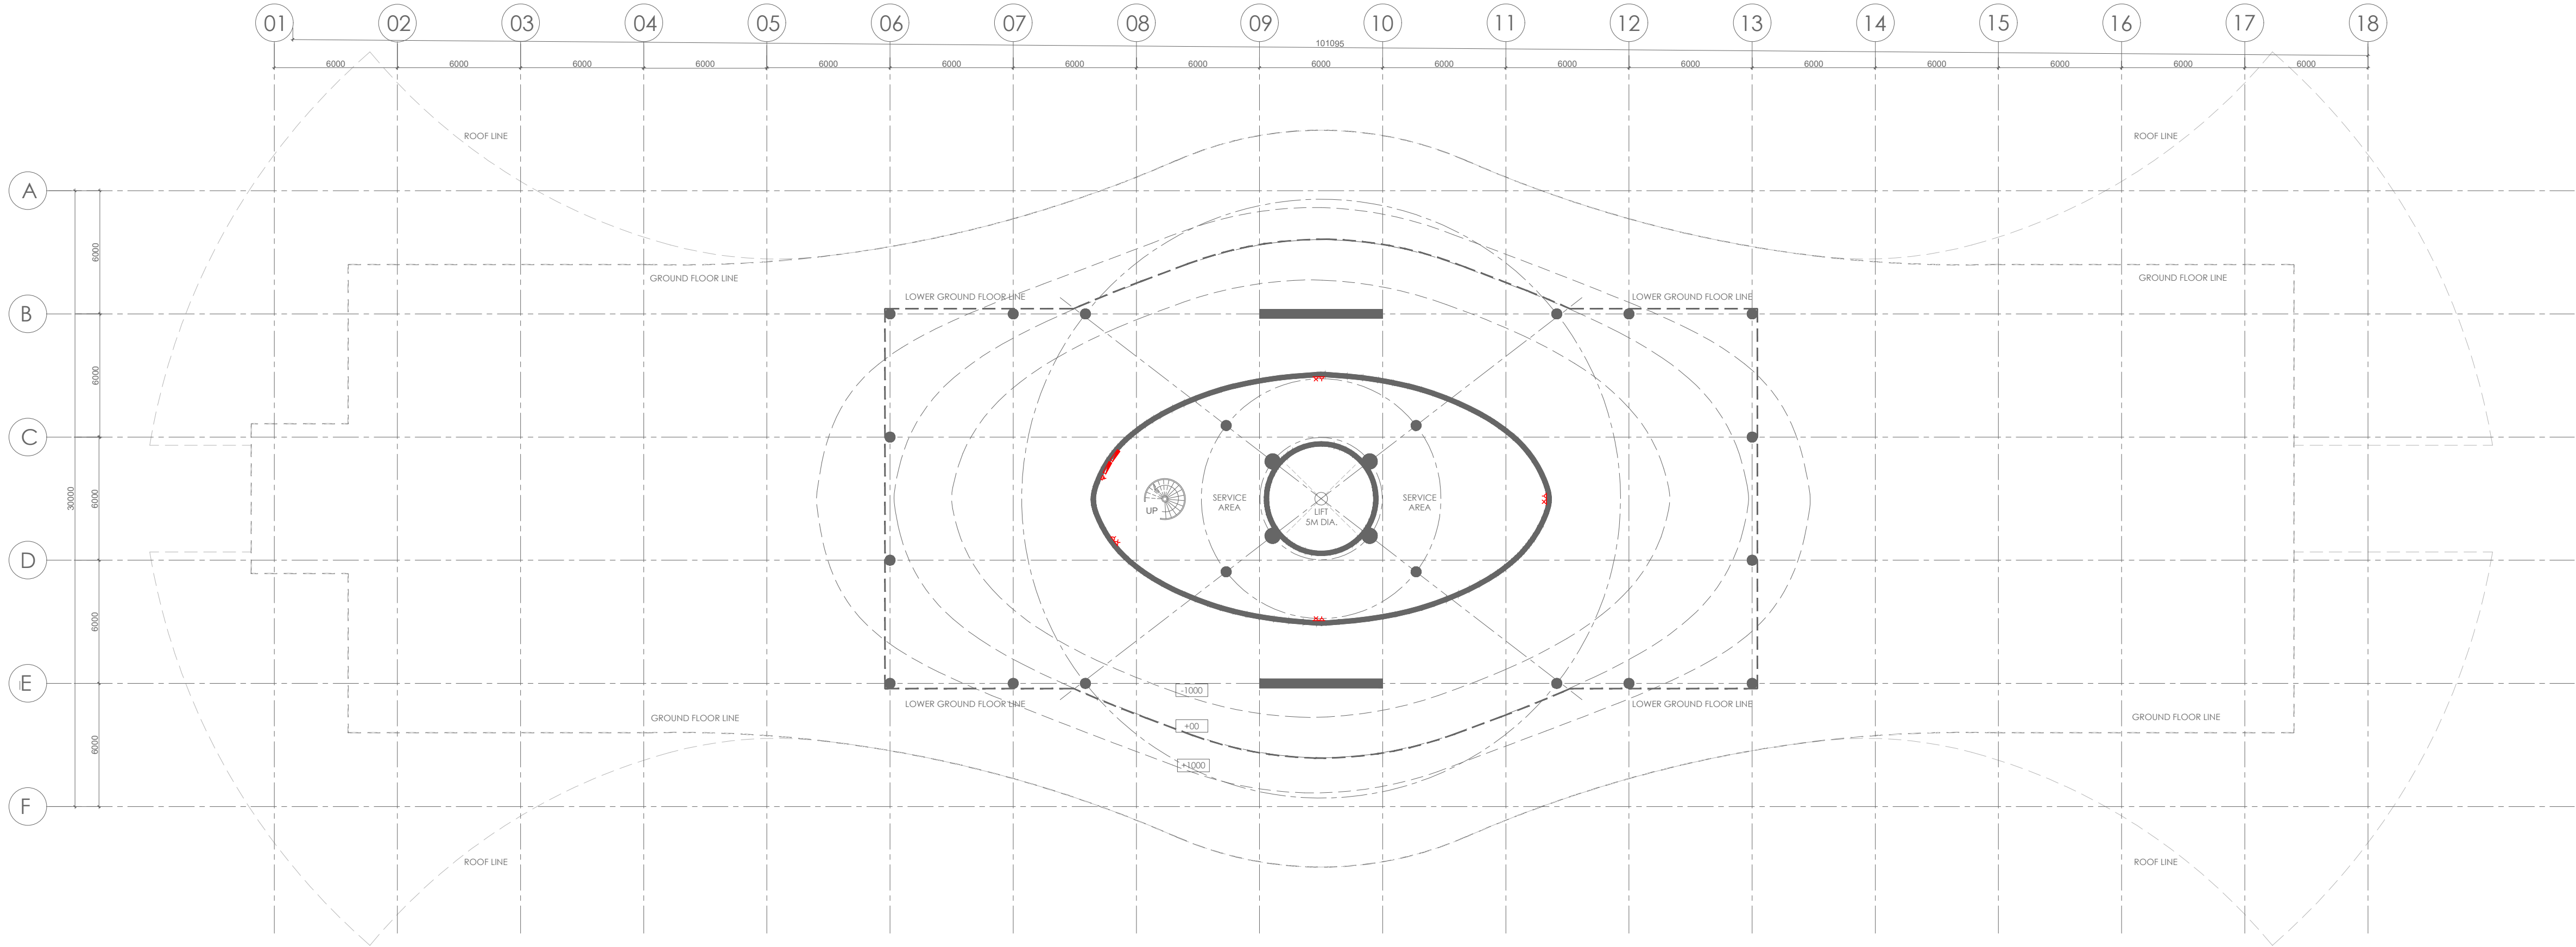

SERVICE FLOOR PLAN

02

LEGEND	
SYMBOL	DESCRIPTION
	SWITCH 1 WAY
	SWITCH 2 WAY
	6A SWITCH SOCKET
	16A SWITCH SOCKET
	16A SWITCH SOCKET FOR GYSE
	16A SWITCH SOCKET FOR AC
	6A SWITCH SOCKET (UPS POWER)
	TV SOCKET
	TELEPHONE SOCKET
	LAN SOCKET
	WI-FI ROUTER (CAT6)
	ELECTRICAL DB

- NOTES:
- DO NOT SCALE THE DRAWING. FOLLOW ONLY FIGURED DIMENSIONS.
 - ALL DIMENSIONS GIVEN IN THIS DRAWING ARE IN MILLIMETERS UNLESS NOTED OTHERWISE.
 - ALL DIMENSIONS TO BE VERIFIED ON SITE AND APPROVED BY THE SITE ENGINEER.
 - ANY DISCREPANCY OR AMBIGUITY IN THE DRAWINGS SHOULD IMMEDIATELY BE BROUGHT TO NOTICE OF THE ARCHITECT.
 - ALL DRAWINGS SHOULD BE READ IN CONJUNCTION WITH OTHER RELEVANT ARCHITECTURAL, STRUCTURAL, PLUMBING, MECHANICAL AND ELECTRICAL DRAWINGS.
 - THE ± 0 REFERS TO LEVEL ESTABLISHED AT SITE IN PRESENCE OF THE SITE SUPERVISOR AND THE ARCHITECT. ALL REMAINING LEVELS ARE RELATIVE TO THIS LEVEL.
 - THIS DRAWING IS THE COPYRIGHT OF ARCHOHM CONSULTANTS AND MUST NOT BE RETAINED, COPIED OR USED WITHOUT THEIR AUTHORITY.

REVISIONS			
No.	Date	Descriptions	Revision by

Client:
MEGHALAYAN AGE LIMITED (MAL)

Project:
TRIBAL HERITAGE CENTRE, MANDALGRE, MEGHALAYA

Architects:



Structural Consultants:
TPC TECHNICAL PROJECTS CONSULTANTS (P) LTD.
H/O: B-14, Sector 02, Noida, Uttar Pradesh
Phone: 91-11-26100000
Mobile: 91-9810000000
Email: tpc@tpc.co.in
Website: www.tpc.co.in

Electrical Consultants:
ARCHOHM CONSULTANT PVT. LTD.
H/O: B-14, Sector 02, Noida, Uttar Pradesh
Phone: 91-11-26100000
Mobile: 91-9810000000
Email: archohm@archohm.com
Website: www.archohm.com


M/E Consultants:
WAC Engineers INDIA PVT. LTD.
MEP Consultants & Project Managers
H/O: B-14, Sector 02, Noida, Uttar Pradesh
Phone: 91-11-26100000
Mobile: 91-9810000000
Email: wac@wac.co.in
Website: www.wac.co.in

Drawn By
Checked By
Design By


CK
AKD
AKD

Sheet Title:		Project No.:	
EXHIBITION & RESEARCH CENTRE SERVICE FLOOR PLAN SW SOCKET LAYOUT		A-232409	
Date:	25-08-2024	Scale:	1:200
Drawing No.:	E-232409-B1-04-01		
		A1	R0

TENDER DRAWING

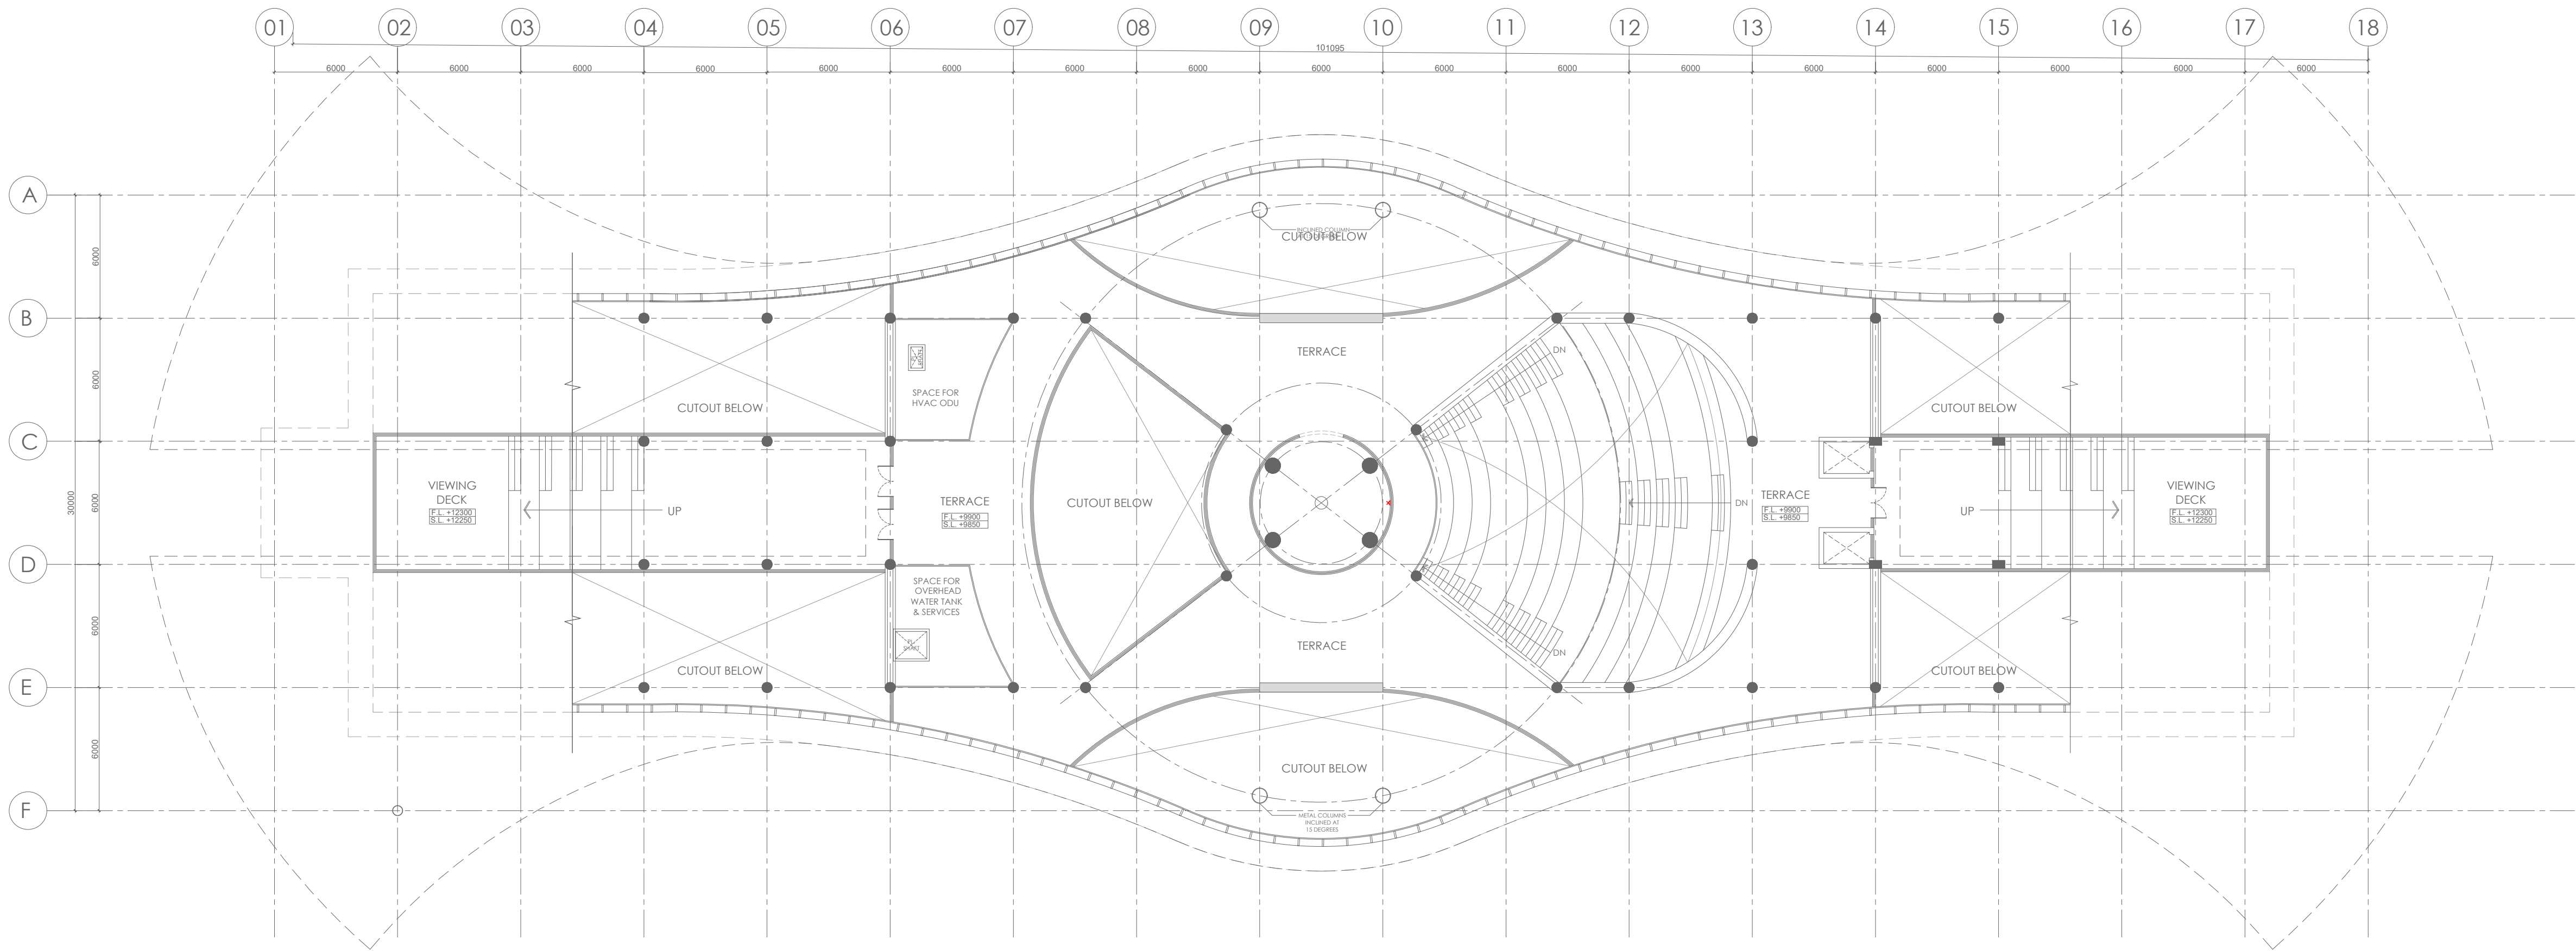

USABLE TERRACE PLAN

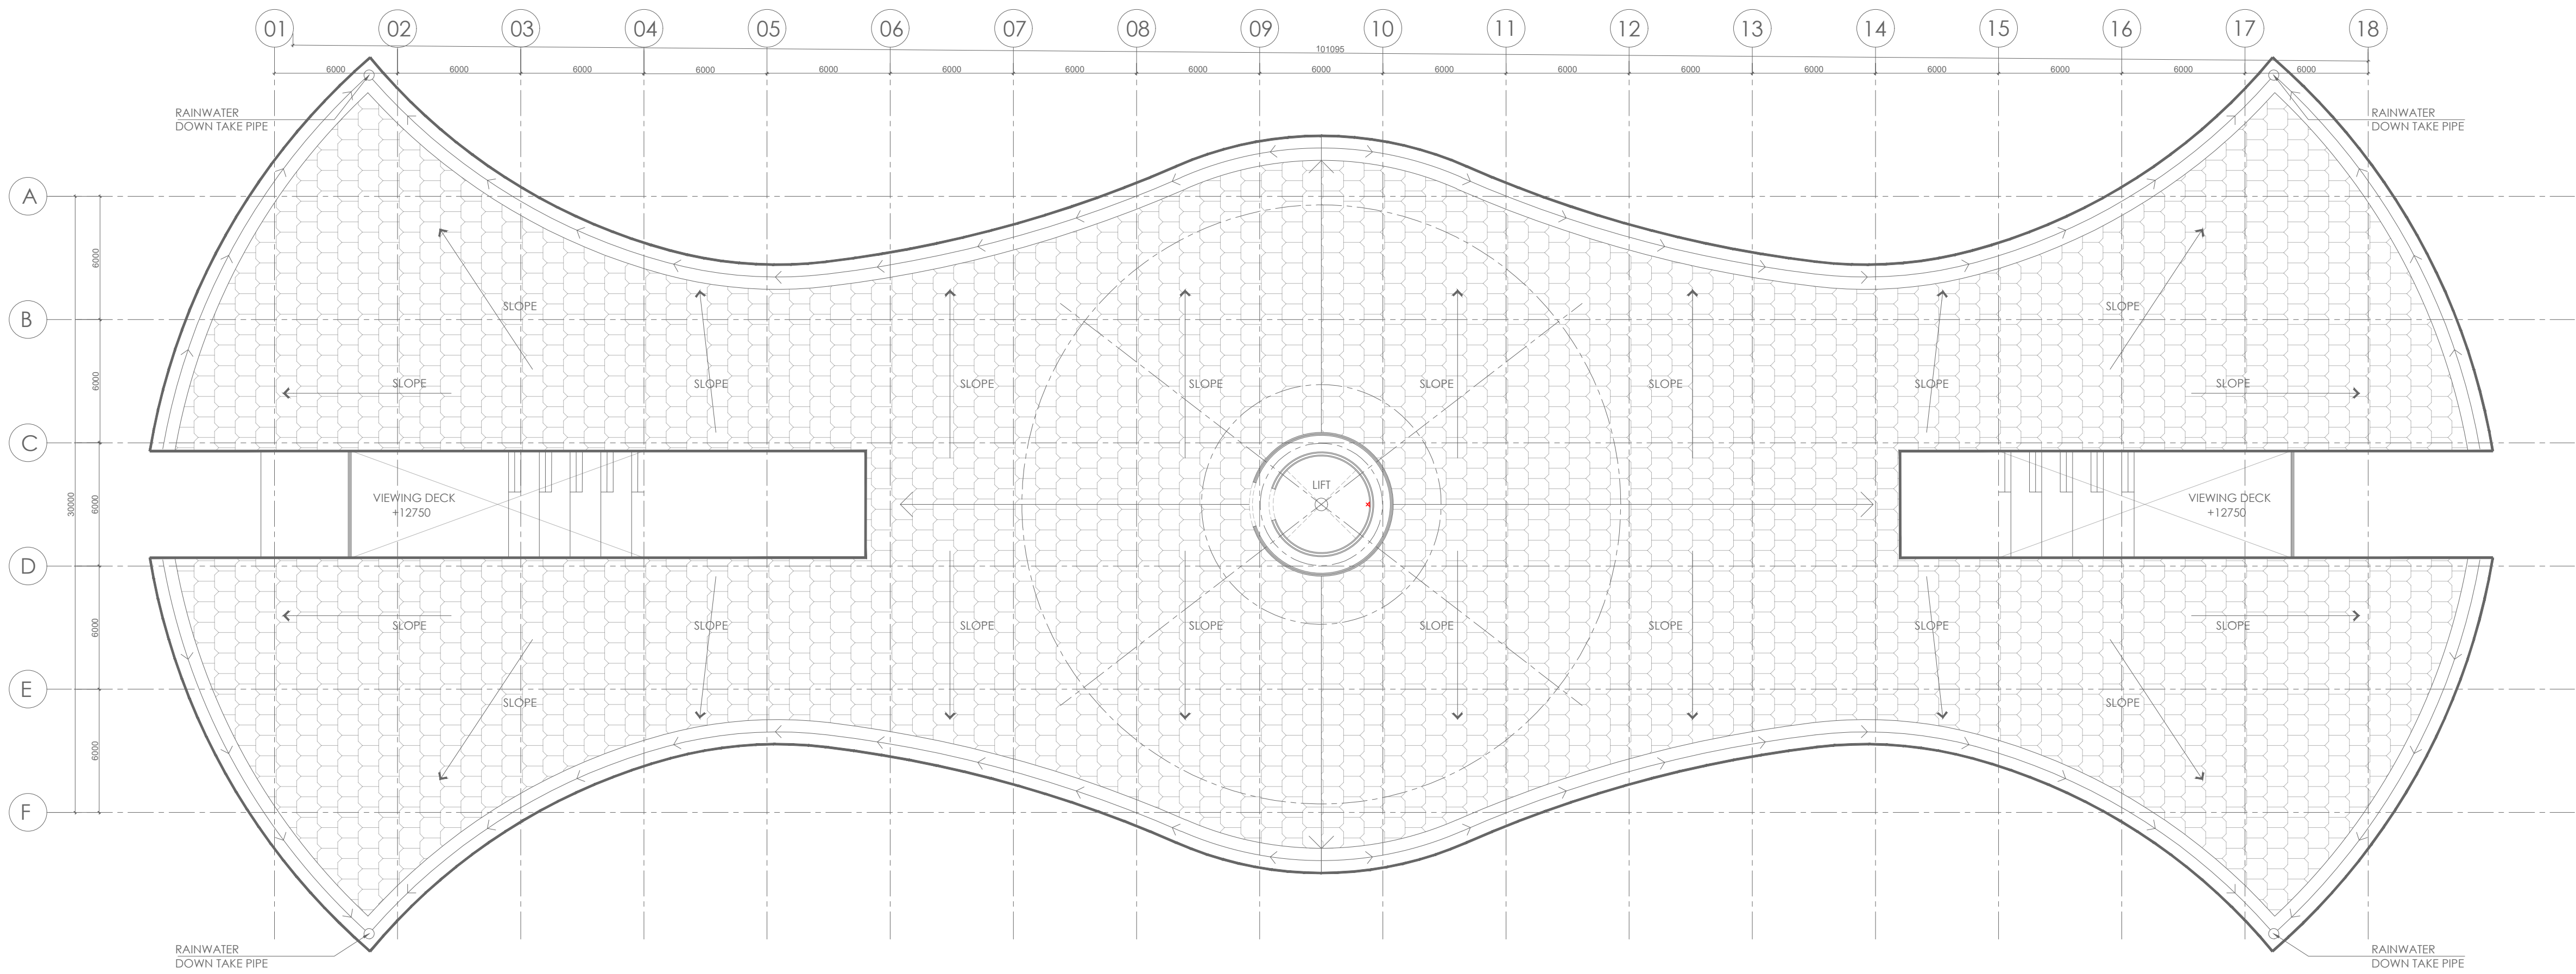

ROOF PLAN

LEGEND	
SYMBOL	DESCRIPTION
	SWITCH 1 WAY
	SWITCH 2 WAY
	6A SWITCH SOCKET
	16A SWITCH SOCKET
	16A SWITCH SOCKET FOR AC
	6A SWITCH SOCKET (UPS POWER)
	TV SOCKET
	TELEPHONE SOCKET
	LAN SOCKET
	WI-FI ROUTER (CAT6)
	ELECTRICAL DB

NOTES:

- DO NOT SCALE THE DRAWING. FOLLOW ONLY FIGURED DIMENSIONS.
- ALL DIMENSIONS GIVEN IN THIS DRAWING ARE IN MILLIMETERS UNLESS NOTED OTHERWISE.
- ALL DIMENSIONS TO BE VERIFIED ON SITE AND APPROVED BY THE SITE ENGINEER.
- ANY DISCREPANCY OR AMBIGUITY IN THE DRAWINGS SHOULD IMMEDIATELY BE BROUGHT TO NOTICE OF THE ARCHITECT.
- ALL DRAWINGS SHOULD BE READ IN CONJUNCTION WITH OTHER RELEVANT ARCHITECTURAL, STRUCTURAL, PLUMBING, MECHANICAL AND ELECTRICAL DRAWINGS.
- THE ± 0 REFERS TO LEVEL ESTABLISHED AT SITE IN PRESENCE OF THE SITE SUPERVISOR AND THE ARCHITECT. ALL REMAINING LEVELS ARE RELATIVE TO THIS LEVEL.
- THIS DRAWING IS THE COPYRIGHT OF ARCHOHM CONSULTANTS & PROJECT MANAGERS AND MUST NOT BE RETAINED, COPIED OR USED WITHOUT THEIR AUTHORITY.

REVISIONS

No.	Date	Descriptions	Revision by

Client:

MEGHALAYAN AGE LIMITED (MAL)


Project:

TRIBAL HERITAGE CENTRE, MANDALGRE, MEGHALAYA

Architects:



Structural Consultants:

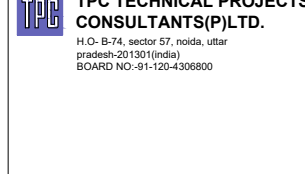

Electrical Consultants:



M/E Consultants:



Drawn By

CK

Checked By

AKD

Design By

AKD

Sheet Title:

EXHIBITION & RESEARCH CENTRE
USABLE TERRACE & ROOF FLOOR PLAN
SW SOCKET LAYOUT

Date:

25-08-2024

Drawing No.:

E-232409-B1-04-03

Scale:

1:200

Project No.:


A-232409

Sheet No.:


A1

Sheet No.:


R0

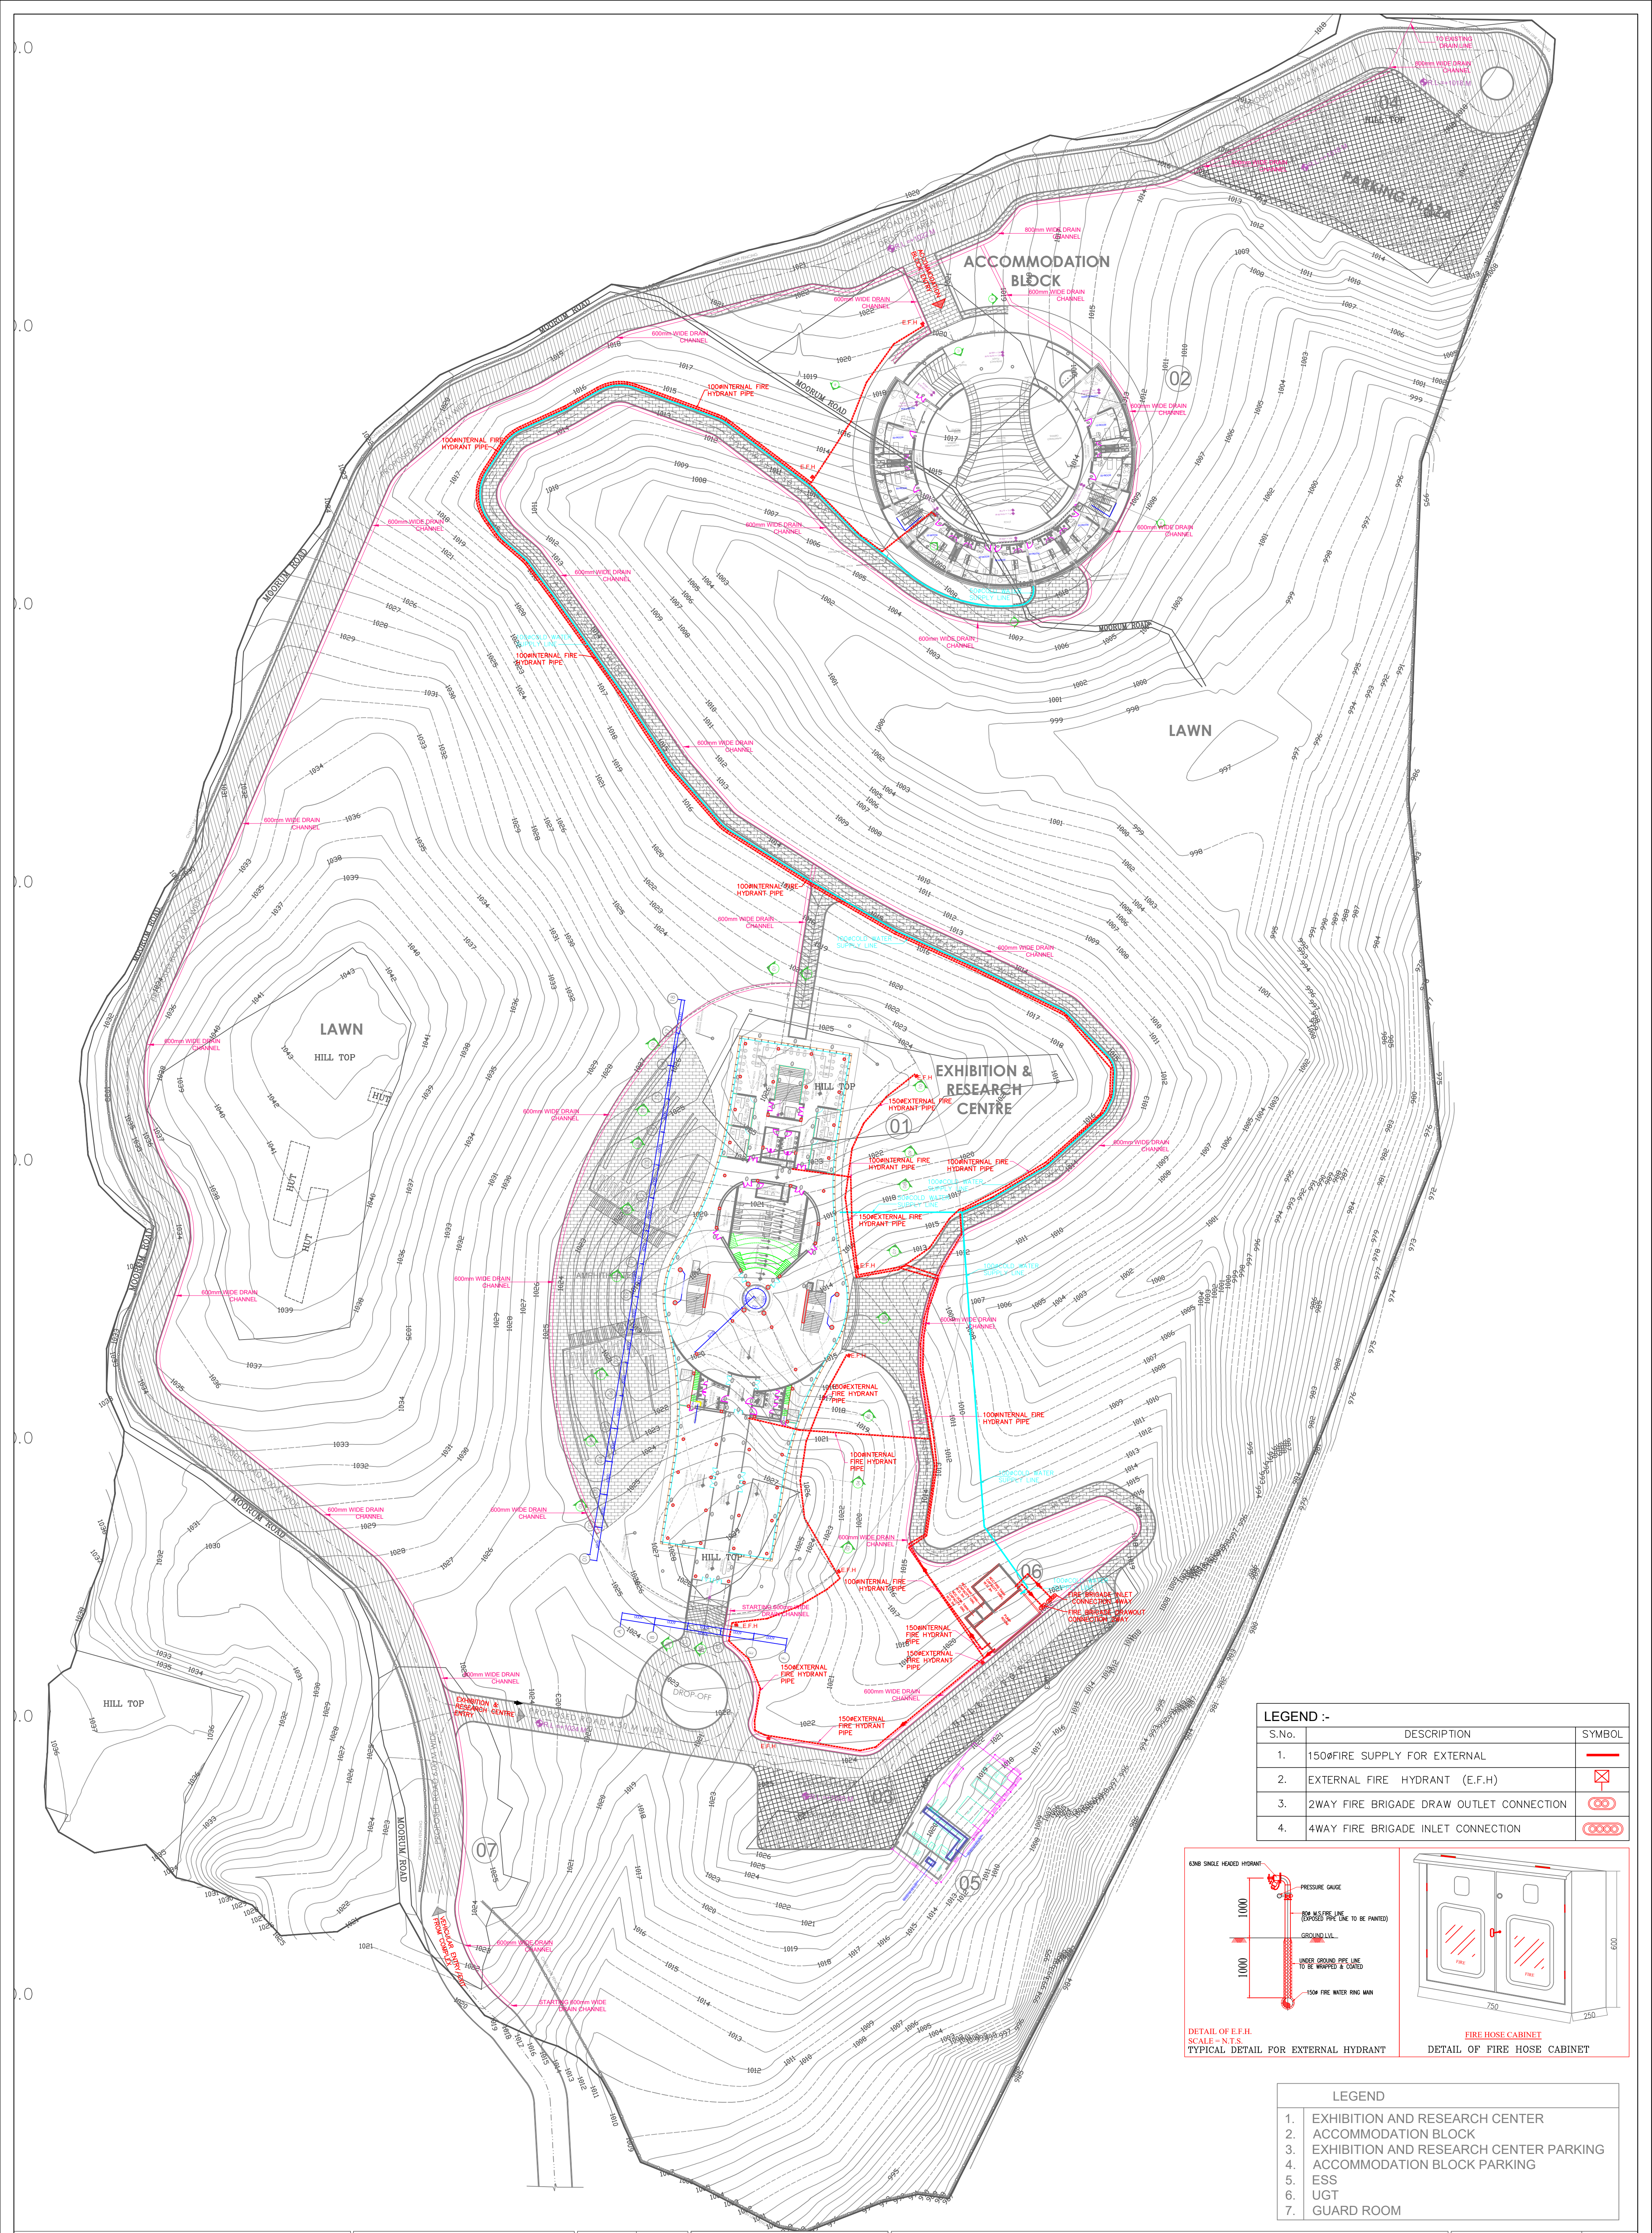



LEGEND :-		
S.No.	DESCRIPTION	SYMBOL
1.	150mm FIRE SUPPLY FOR EXTERNAL	
2.	EXTERNAL FIRE HYDRANT (E.F.H)	
3.	2WAY FIRE BRIGADE DRAW OUTLET CONNECTION	
4.	4WAY FIRE BRIGADE INLET CONNECTION	

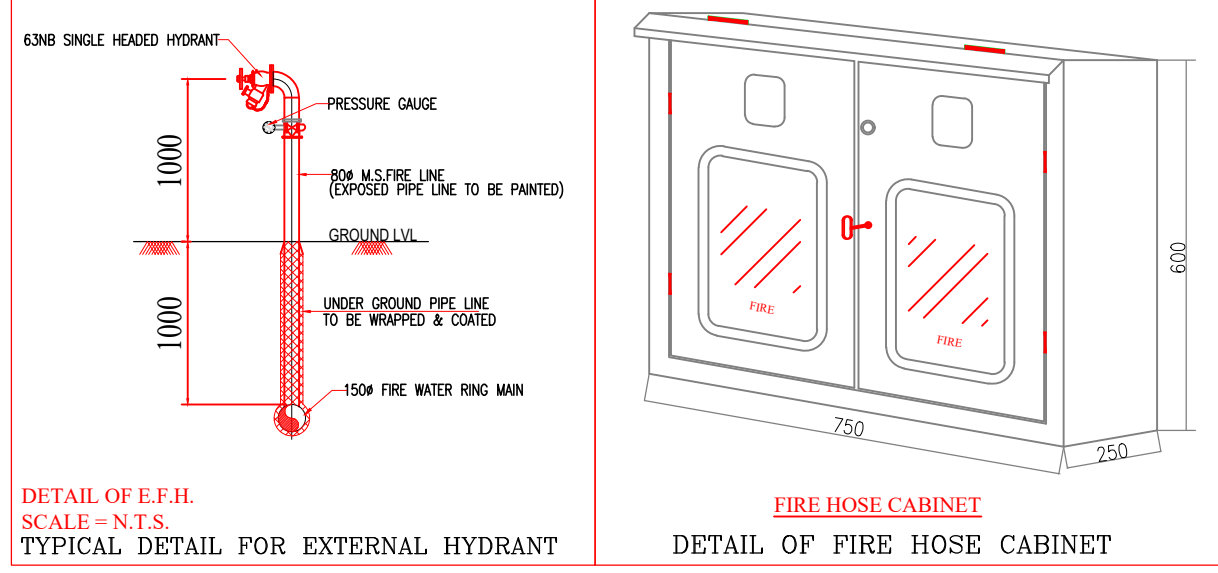

LEGEND	
1.	EXHIBITION AND RESEARCH CENTER
2.	ACCOMMODATION BLOCK
3.	EXHIBITION AND RESEARCH CENTER PARKING
4.	ACCOMMODATION BLOCK PARKING
5.	ESS
6.	UGT
7.	GUARD ROOM

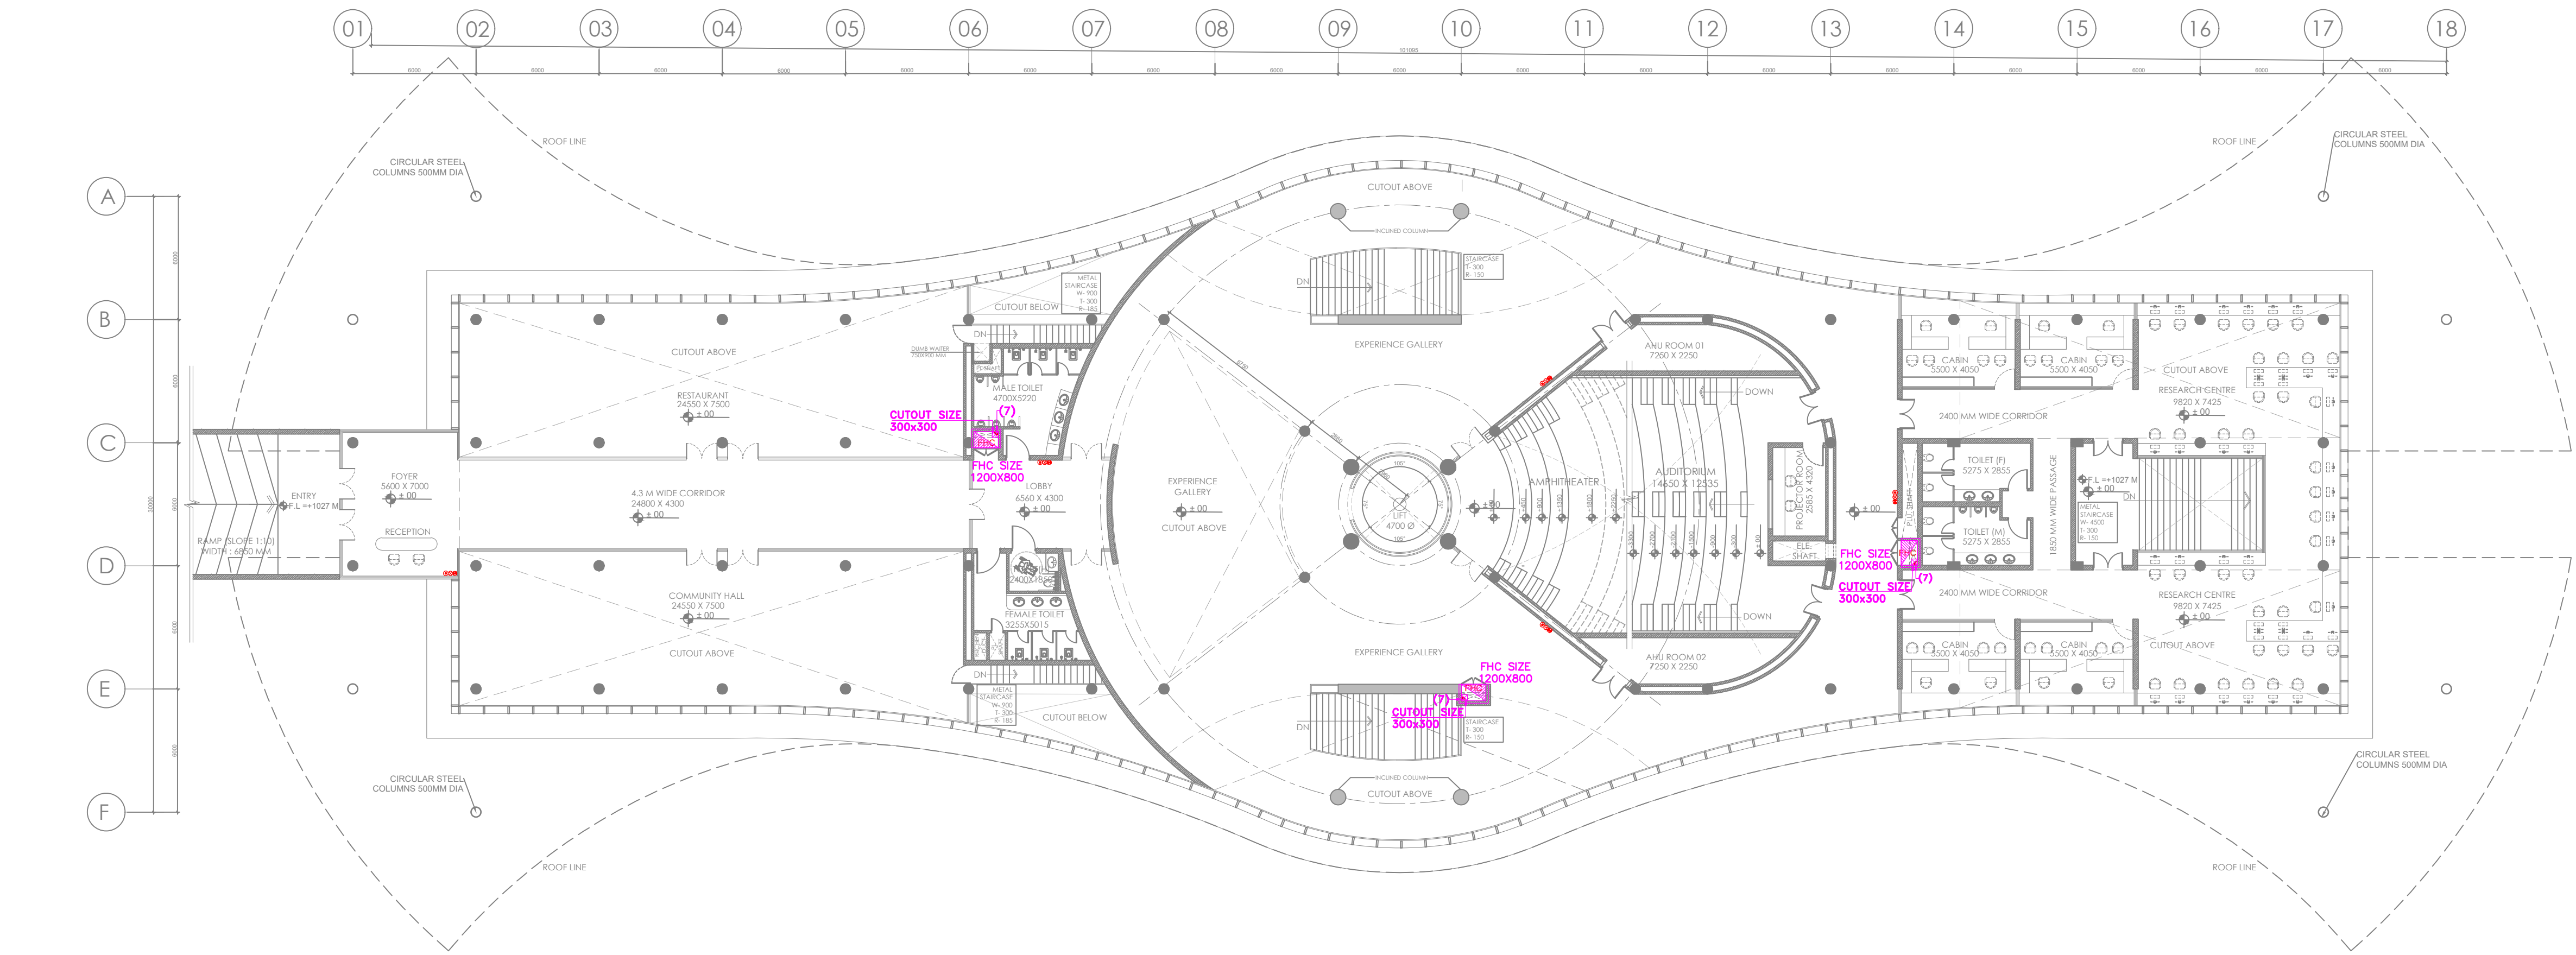

03 GROUND FLOOR PLAN
SCALE 1:200

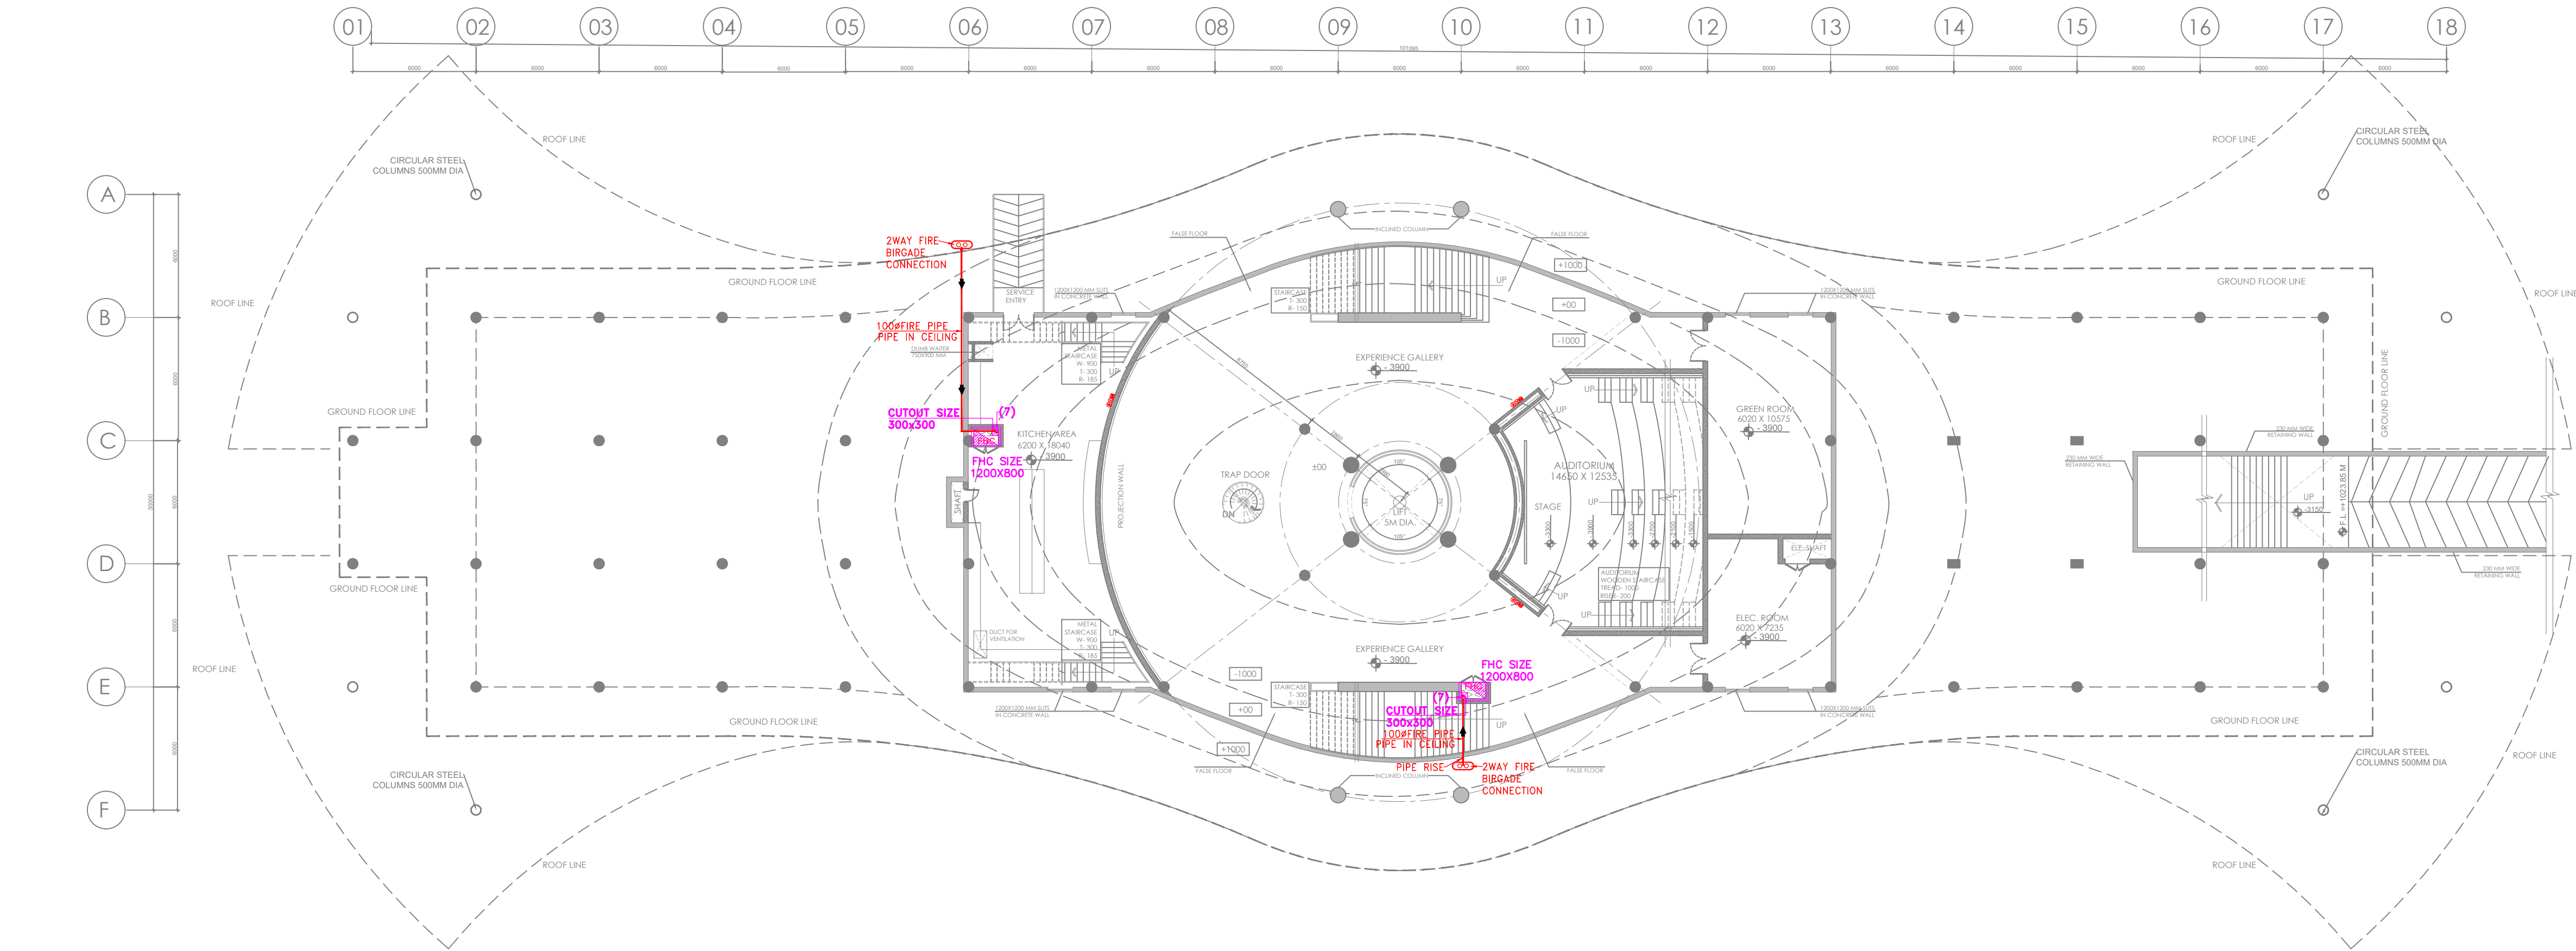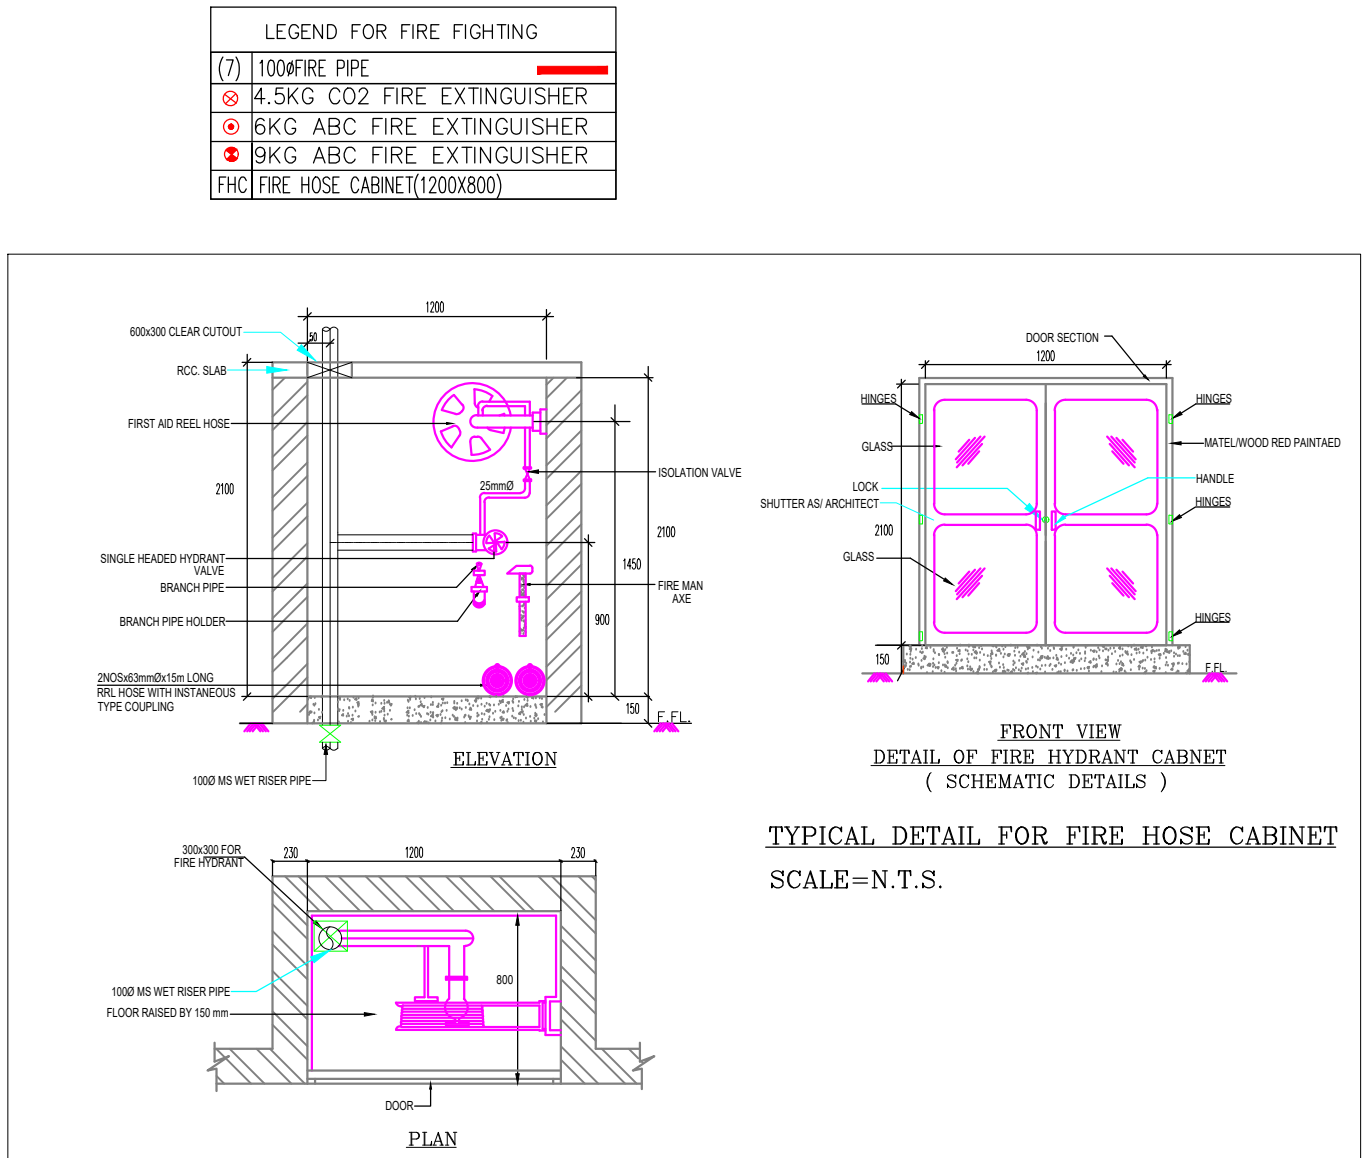

02 LOWER GROUND FLOOR PLAN
SCALE 1:200

NOTES:

- DO NOT SCALE THE DRAWING. FOLLOW ONLY FIGURED DIMENSIONS.
- ALL DIMENSIONS GIVEN IN THIS DRAWING ARE IN MILLIMETERS UNLESS NOTED OTHERWISE.
- ALL DIMENSIONS TO BE VERIFIED ON SITE AND APPROVED BY THE SITE ENGINEER.
- ANY DISCREPANCY OR AMBIGUITY IN THE DRAWINGS SHOULD IMMEDIATELY BE BROUGHT TO NOTICE OF THE ARCHITECT.
- ALL DRAWINGS SHOULD BE READ IN CONJUNCTION WITH OTHER RELEVANT ARCHITECTURAL, STRUCTURAL, PLUMBING, MECHANICAL AND ELECTRICAL DRAWINGS.
- THE ± 0 REFERS TO LEVEL ESTABLISHED AT SITE IN PRESENCE OF THE SITE SUPERVISOR AND THE ARCHITECT. ALL REMAINING LEVELS ARE RELATIVE TO THIS LEVEL.
- THIS DRAWING IS THE COPYRIGHT OF ARCHOHM CONSULTANTS AND MUST NOT BE RETAINED, COPIED OR USED WITHOUT THEIR AUTHORITY.

REVISIONS			
No.	Date	Descriptions	Revision by

Client:

MEGHALAYAN AGE LIMITED (MAL)


Project:

TRIBAL HERITAGE CENTRE, MANDALGRE, MEGHALAYA

Architects:



Structural Consultants:

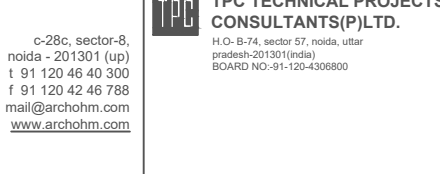

Electrical Consultants:



Plumbing Consultants:



Drawn By:

PRATEEK

Checked By: M.S.

Design By: SHAHFAHAD

Sheet Title:

TRIBAL HERITAGE CENTER EXHIBITION & RESEARCH CENTER FLOOR PLANS (SHEET 01 OF 03)

Date:

29-08-2024

Scale:

1:200

Project No.:

A-232409-B1-FF-01


Project No.:

A-232409



Drawing No.:

A1

R0

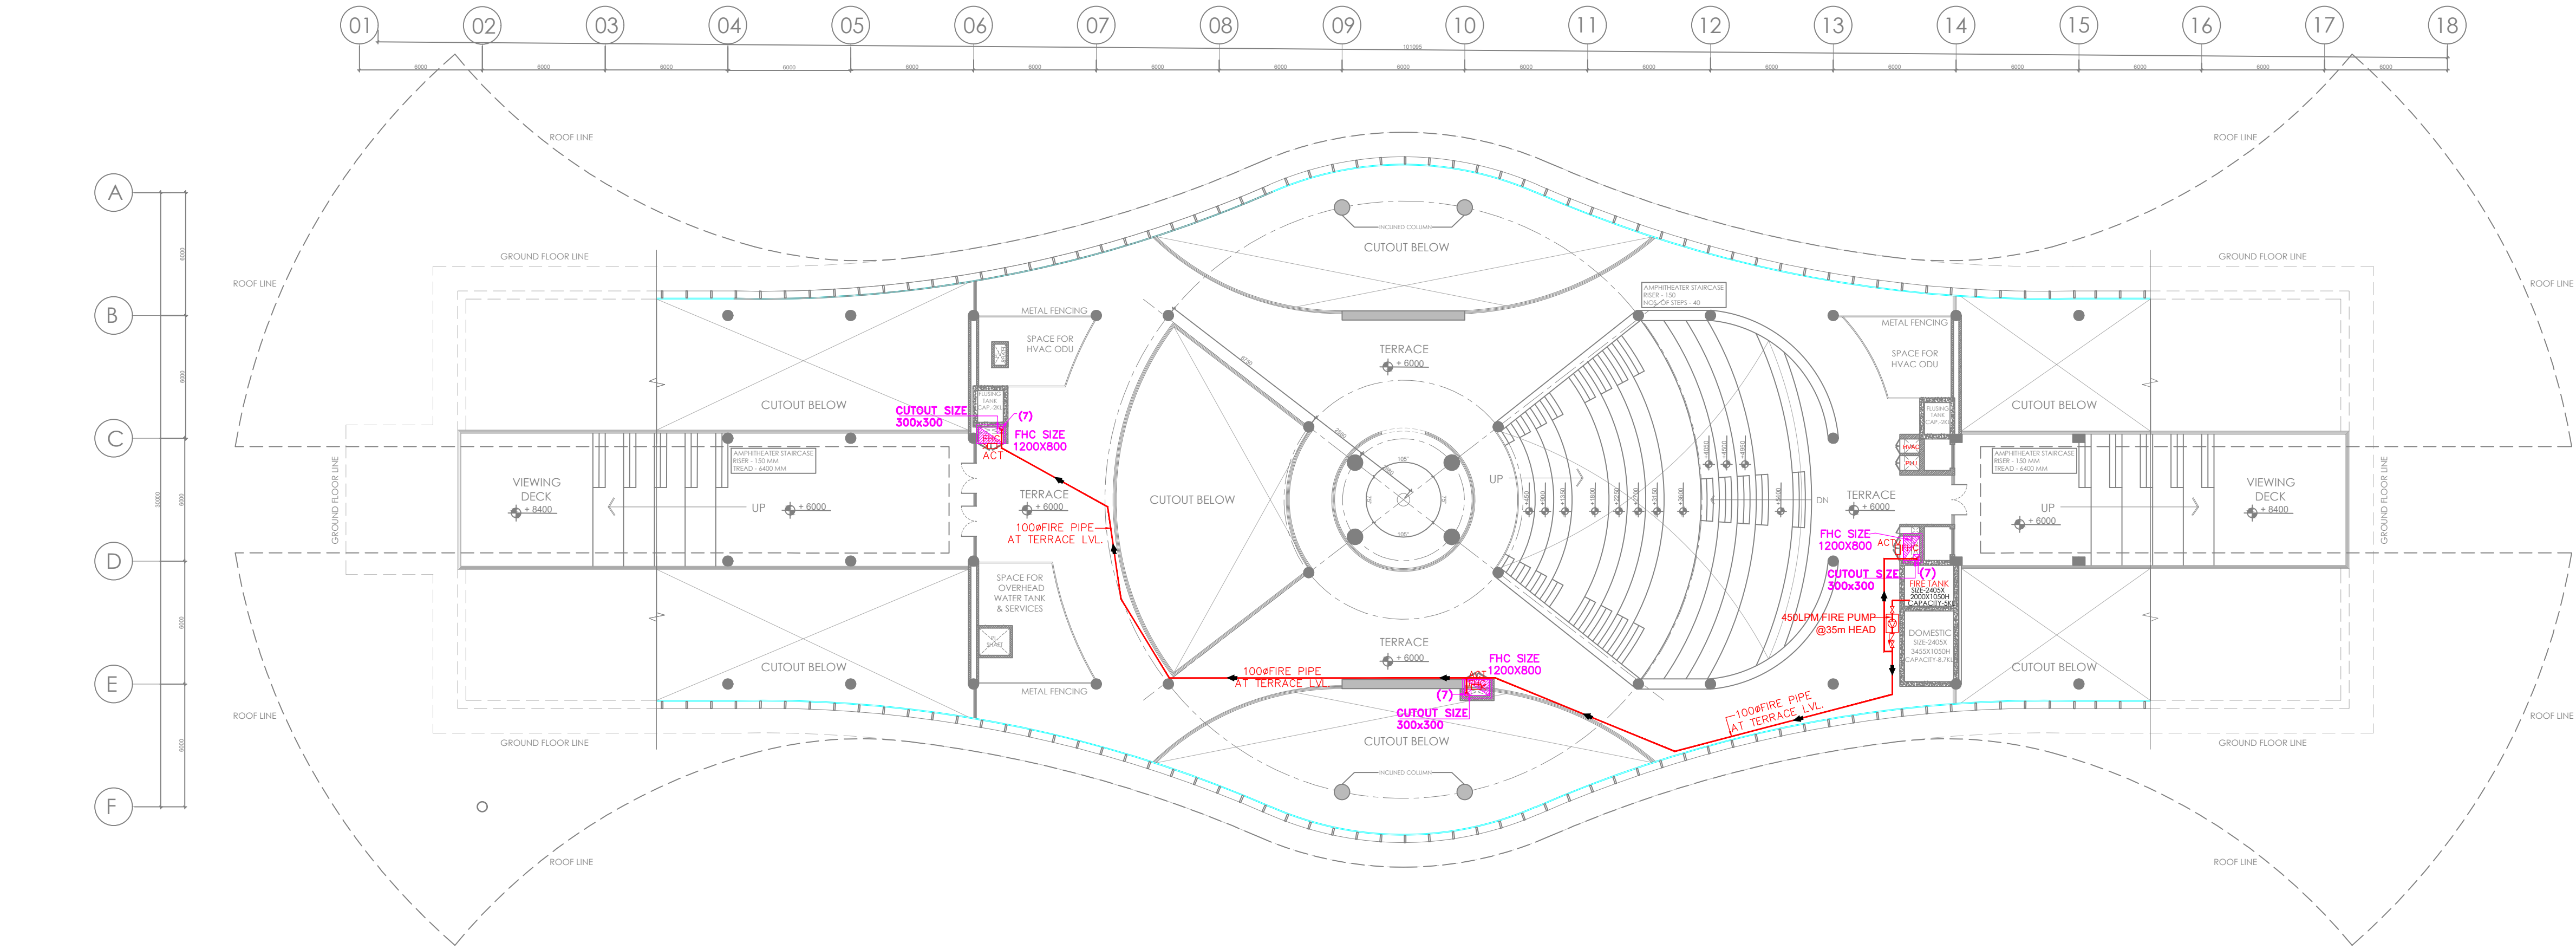

04 USABLE TERRACE PLAN
SCALE 1:200

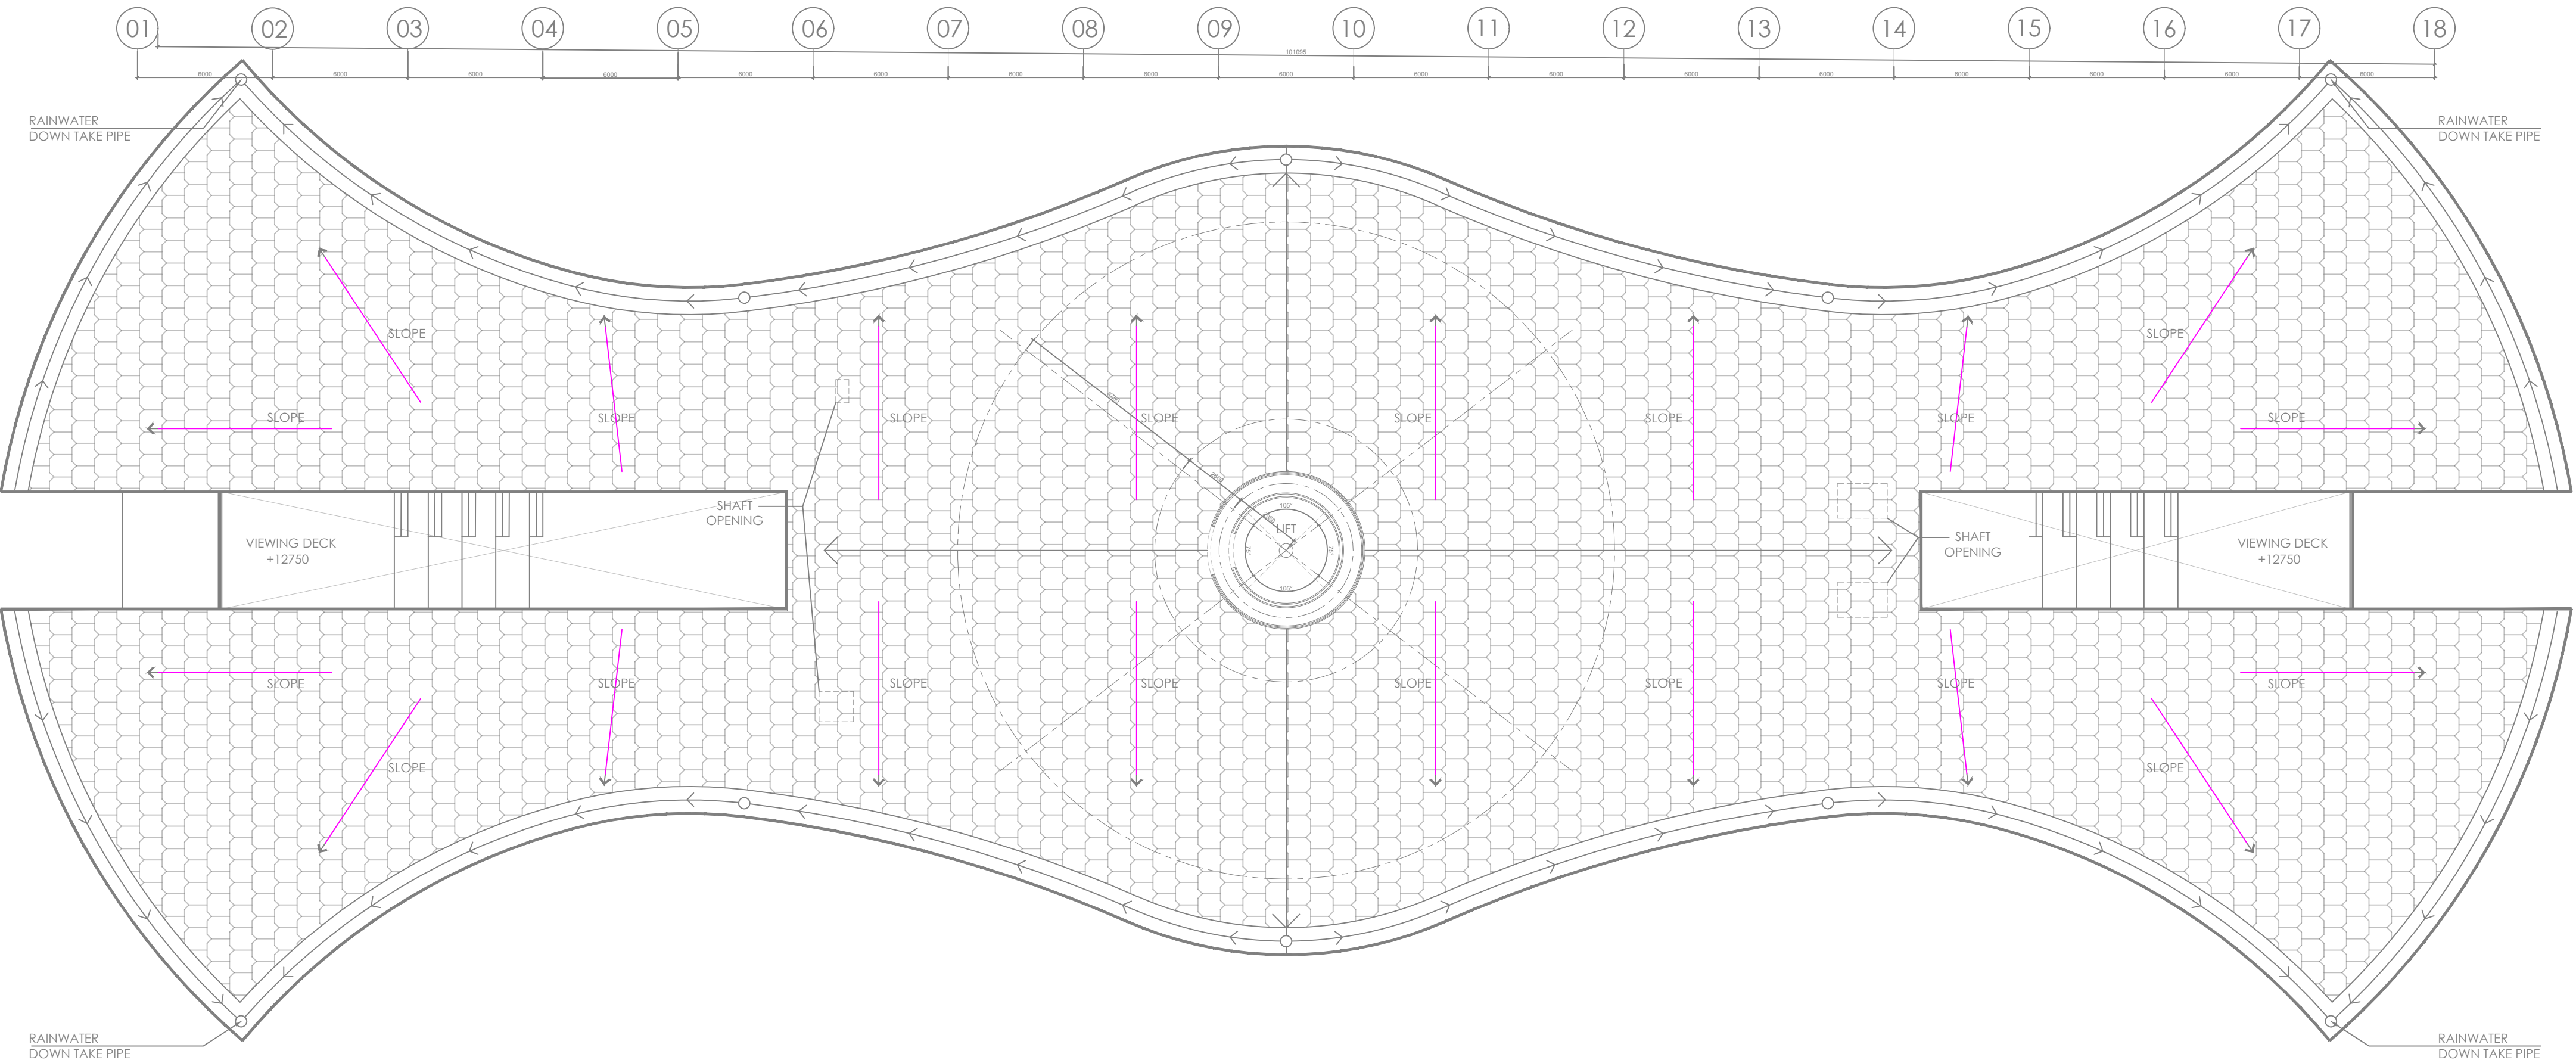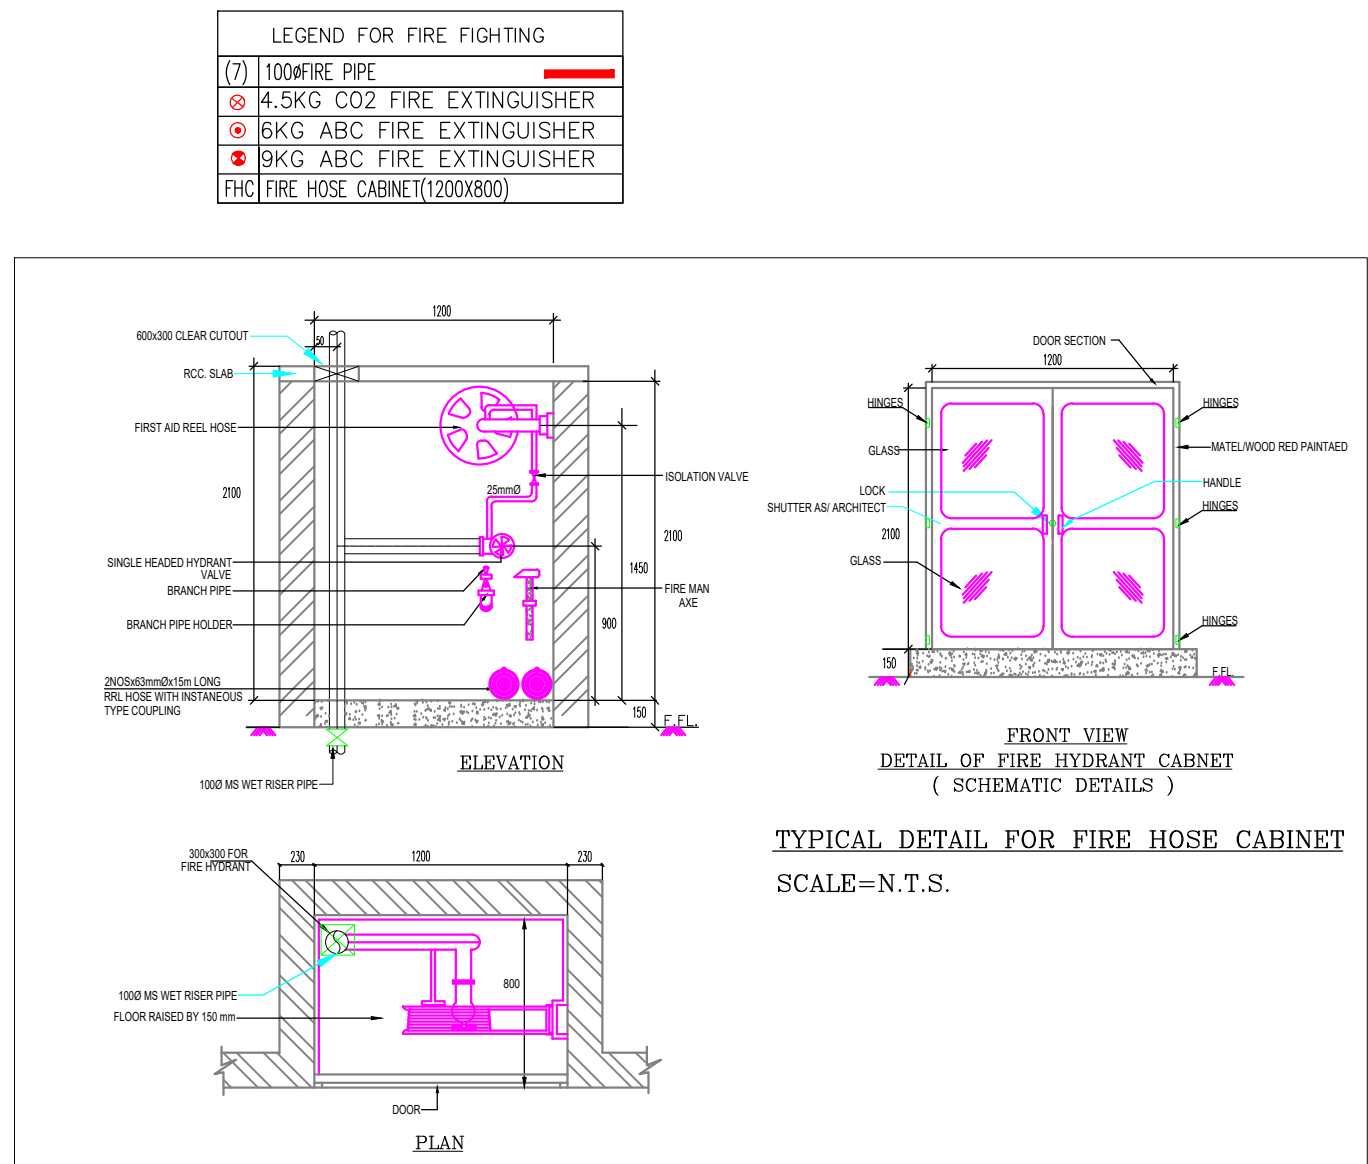

05 ROOF PLAN
SCALE 1:200

NOTES:

- DO NOT SCALE THE DRAWING. FOLLOW ONLY FIGURED DIMENSIONS.
- ALL DIMENSIONS GIVEN IN THIS DRAWING ARE IN MILLIMETERS UNLESS NOTED OTHERWISE.
- ALL DIMENSIONS TO BE VERIFIED ON SITE AND APPROVED BY THE SITE ENGINEER.
- ANY DISCREPANCY OR AMBIGUITY IN THE DRAWINGS SHOULD IMMEDIATELY BE BROUGHT TO NOTICE OF THE ARCHITECT.
- ALL DRAWINGS SHOULD BE READ IN CONJUNCTION WITH OTHER RELEVANT ARCHITECTURAL, STRUCTURAL, PLUMBING, MECHANICAL AND ELECTRICAL DRAWINGS.
- THE ± 0 REFERS TO LEVEL ESTABLISHED AT SITE IN PRESENCE OF THE SITE SUPERVISOR AND THE ARCHITECT. ALL REMAINING LEVELS ARE RELATIVE TO THIS LEVEL.
- THIS DRAWING IS THE COPYRIGHT OF ARCHOHM CONSULTANTS AND MUST NOT BE RETAINED, COPIED OR USED WITHOUT THEIR AUTHORITY.

REVISIONS			
No.	Date	Descriptions	Revision by


Client:

MEGHALAYAN AGE LIMITED (MAL)

Project:

TRIBAL HERITAGE CENTRE, MANDALGRE, MEGHALAYA

Architects:

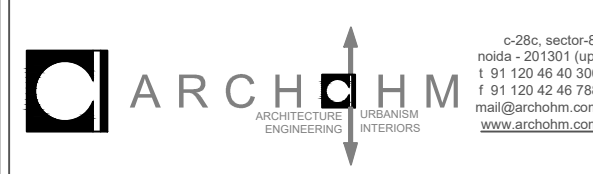

Structural Consultants:



Electrical Consultants:



Mechanical Consultants:



Drawn By:

PRATEEK

Checked By:

M.S

Design By:

SHAHFHAD

Sheet Title:

TRIBAL HERITAGE CENTER
EXHIBITION & RESEARCH CENTER
FLOOR PLANS
(SHEET 02 OF 03)

Date:

29-08-2024

Scale:

1:200

Project No.:

A-232409

Drawing No.:


A-232409-B1-FF-02

Sheet No.:

A1


Sheet No.:

R0

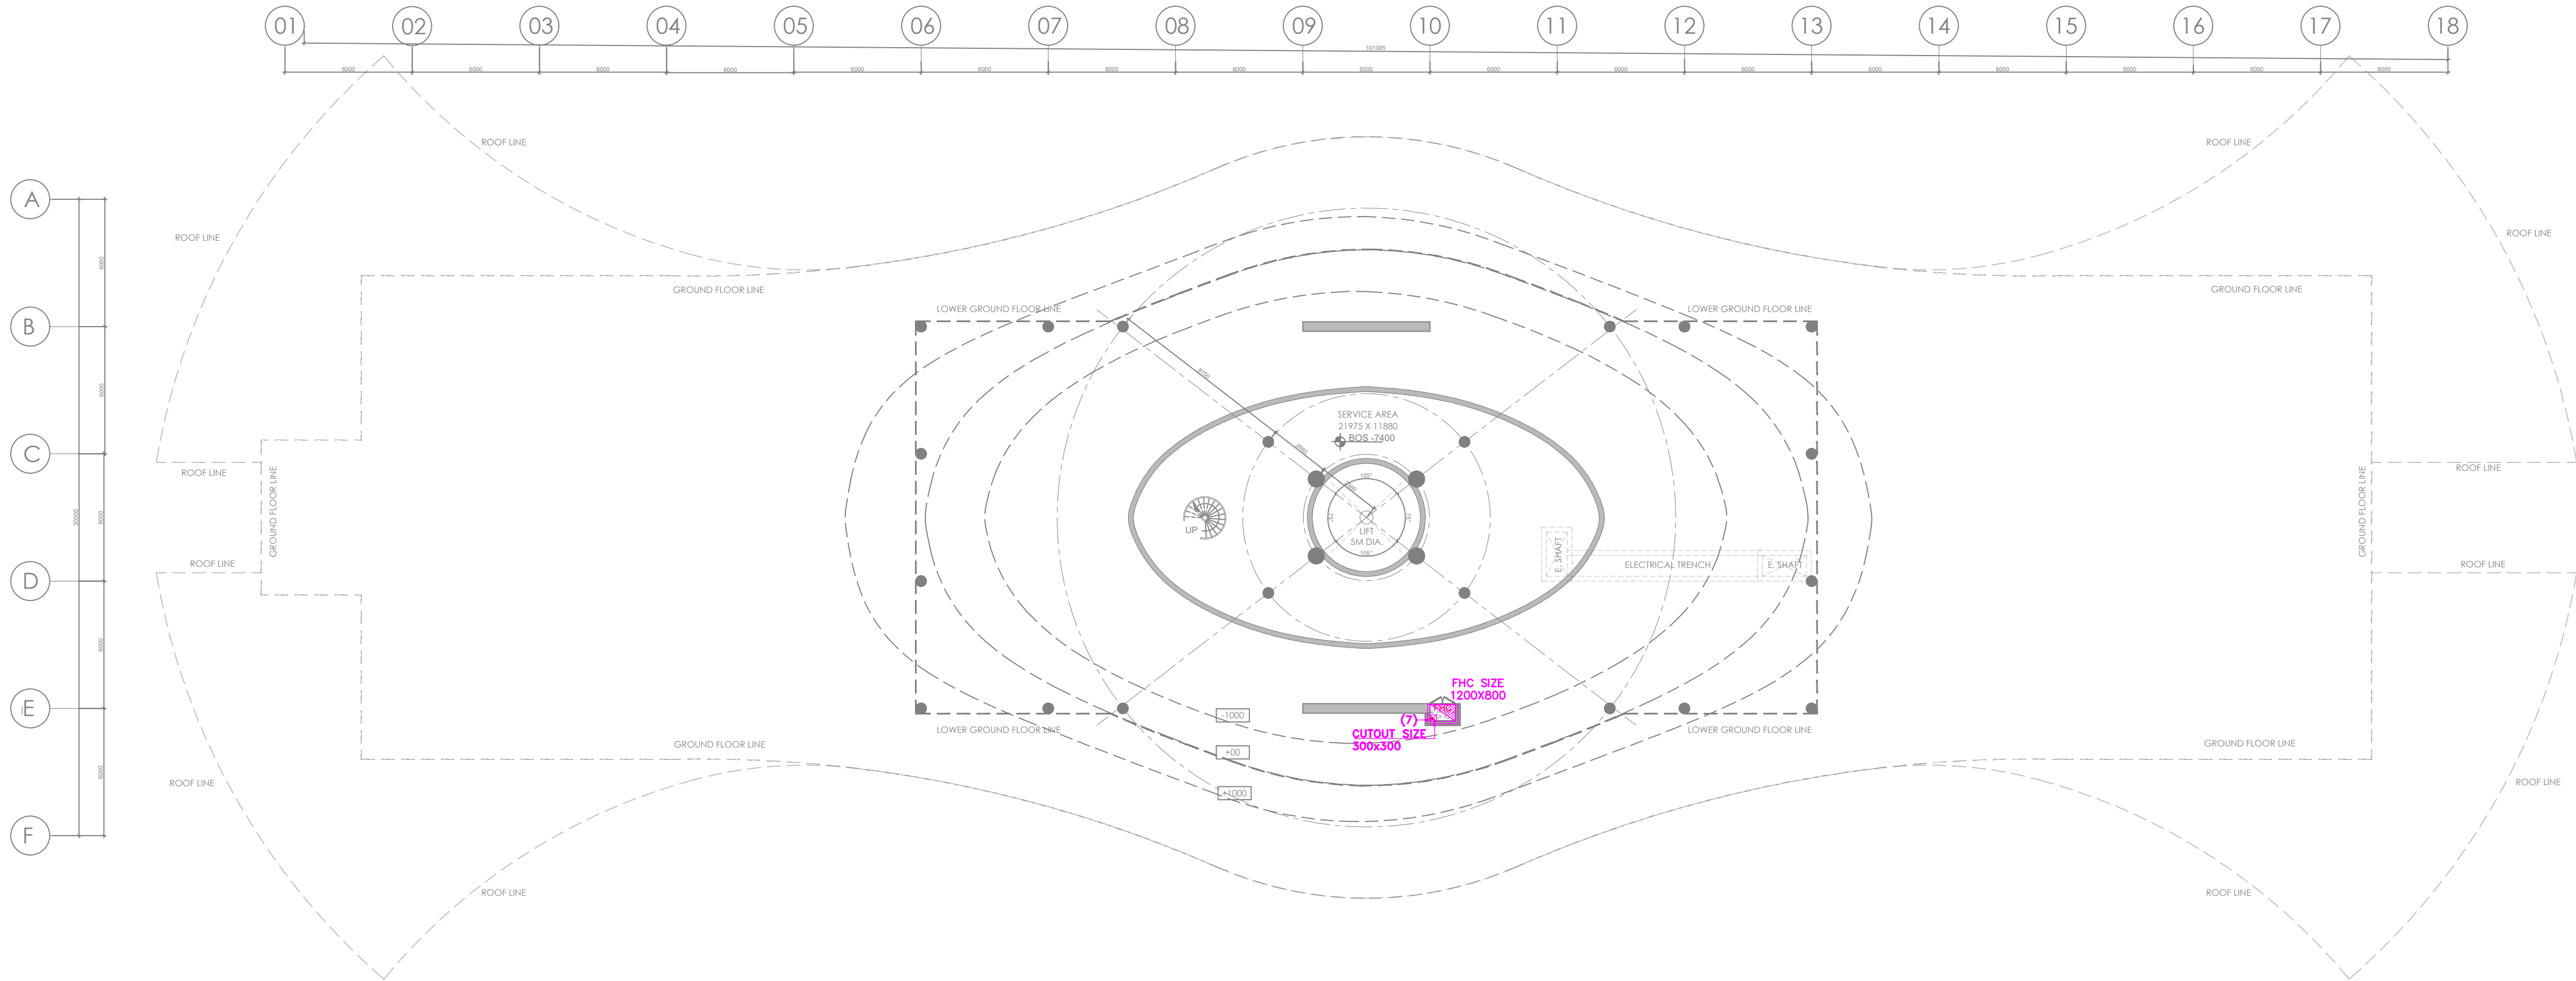

01 SERVICE FLOOR PLAN
SCALE 1:200

LEGEND FOR FIRE FIGHTING	
(7) 100MM FIRE PIPE	—
4.5KG CO2 FIRE EXTINGUISHER	●
6KG ABC FIRE EXTINGUISHER	●
9KG ABC FIRE EXTINGUISHER	●
FHC FIRE HOSE CABINET (1200X800)	■

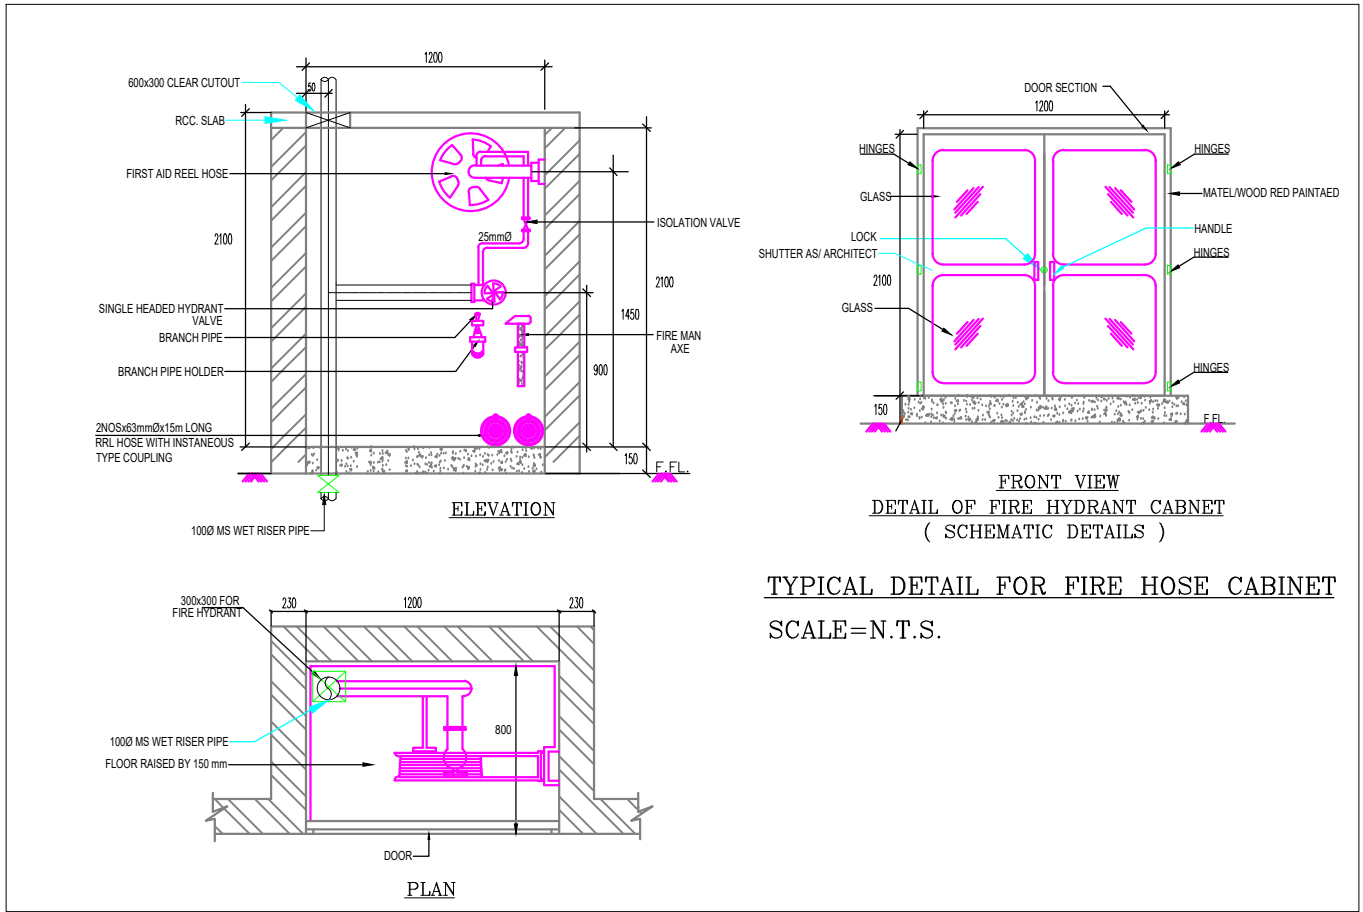

NOTES:

- DO NOT SCALE THE DRAWING. FOLLOW ONLY FIGURED DIMENSIONS.
- ALL DIMENSIONS GIVEN IN THIS DRAWING ARE IN MILLIMETERS UNLESS NOTED OTHERWISE.
- ALL DIMENSIONS TO BE VERIFIED ON SITE AND APPROVED BY THE SITE ENGINEER.
- ANY DISCREPANCY OR AMBIGUITY IN THE DRAWINGS SHOULD IMMEDIATELY BE BROUGHT TO NOTICE OF THE ARCHITECT.
- ALL DRAWINGS SHOULD BE READ IN CONJUNCTION WITH OTHER RELEVANT ARCHITECTURAL, STRUCTURAL, PLUMBING, MECHANICAL AND ELECTRICAL DRAWINGS.
- THE ± 0 REFERS TO LEVEL ESTABLISHED AT SITE IN PRESENCE OF THE SITE SUPERVISOR AND THE ARCHITECT. ALL REMAINING LEVELS ARE RELATIVE TO THIS LEVEL.
- THIS DRAWING IS THE COPYRIGHT OF ARCHOHM CONSULTANTS AND MUST NOT BE RETAINED, COPIED OR USED WITHOUT THEIR AUTHORITY.

REVISIONS			
No.	Date	Descriptions	Revision by

Client:
MEGHALAYAN AGE LIMITED (MAL)

Project: **TRIBAL HERITAGE CENTRE, MANDALGRE, MEGHALAYA**

Architects:



Structural Consultants:

TPC TECHNICAL PROJECTS CONSULTANTS (P) LTD.
C-28C, Sector-8
Phase-1, Gurgaon, Haryana
110 029
T: 91 120 42 48 788
F: 91 120 42 48 788
www.tpcindia.com

Electrical Consultants:

ARCHOHM CONSULTANT PVT. LTD.
C-28C, Sector-8
Phase-1, Gurgaon, Haryana
110 029
T: 91 120 42 48 788
F: 91 120 42 48 788
www.archohm.com

MEP Consultants:

WAC Engineers INDIA PVT. LTD.
MEP Consultants & Project Managers
P-10, Sector-10, Gurgaon, Haryana
110 029
T: 91 120 42 48 788
F: 91 120 42 48 788
www.wacindia.com

Drawn By: PRATEEK

Checked By: M.S.

Design By: SHAHPHAD

Sheet Title:
TRIBAL HERITAGE CENTER EXHIBITION & RESEARCH CENTER FLOOR PLANS (SHEET 03 OF 03)


Date: 29-08-2024

Scale: 1:200


Drawing No.: A-232409-B1-FF-03

Project No.: A-232409

A1 R0

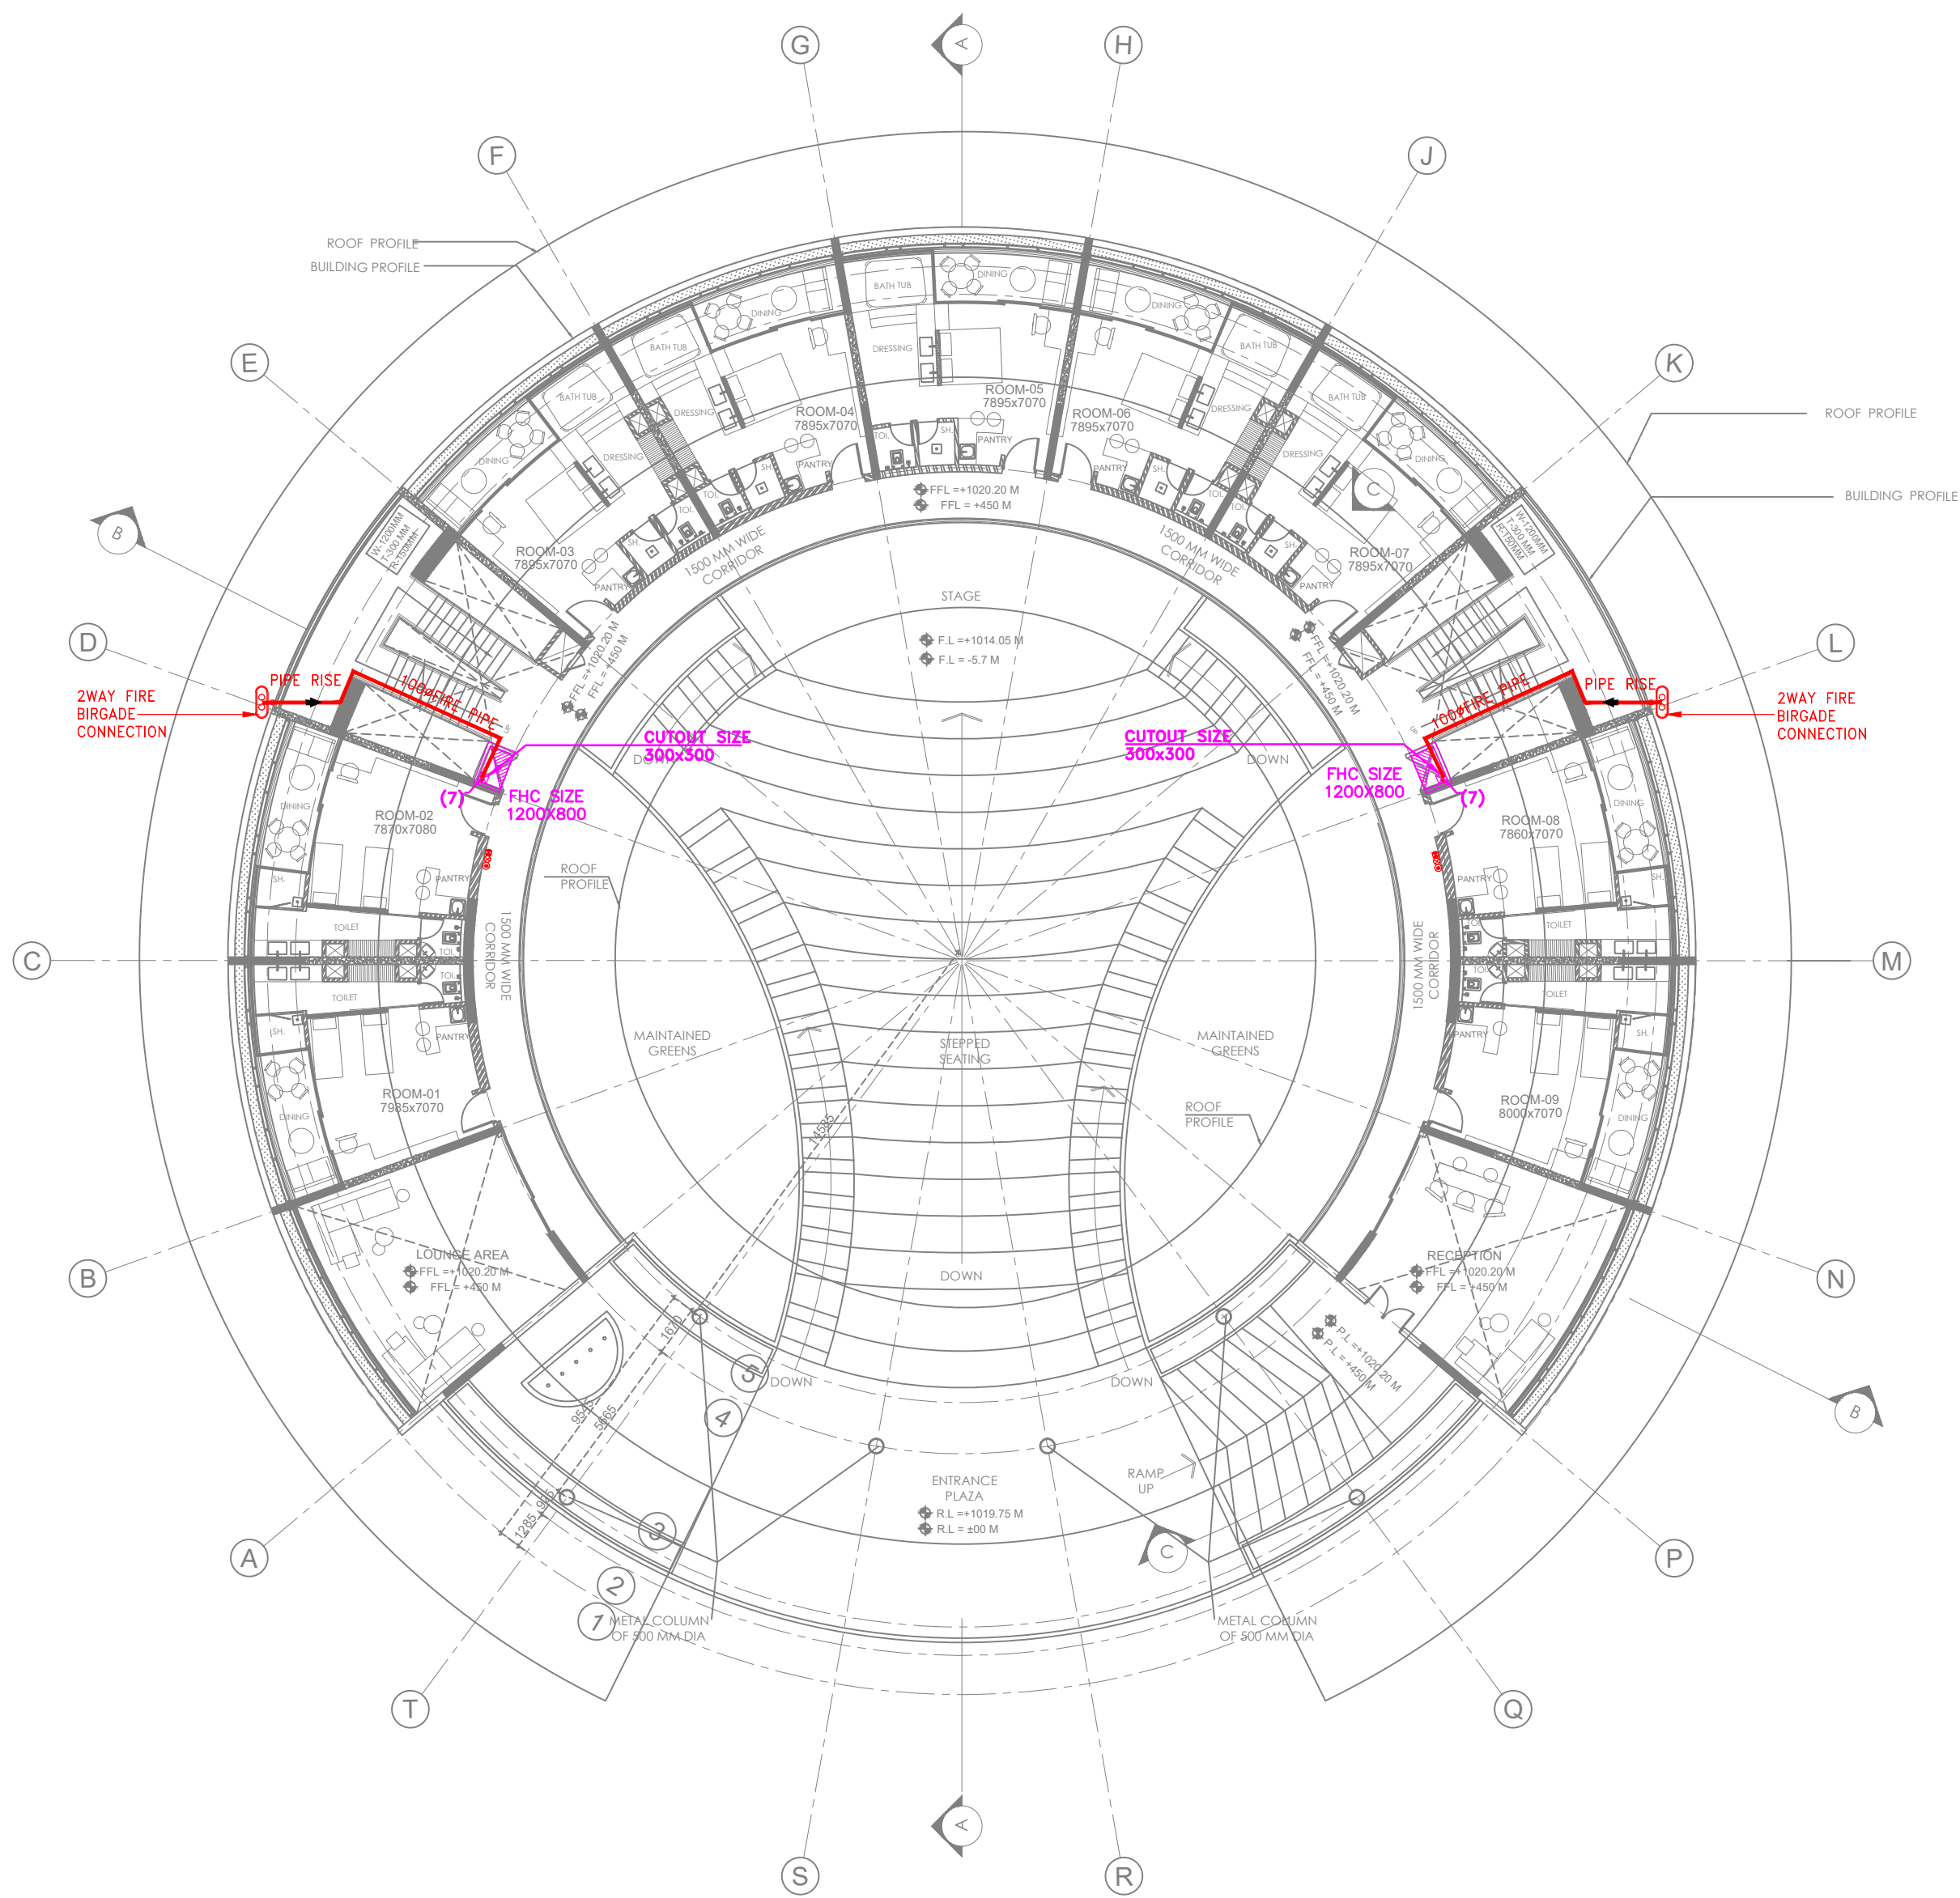


GROUND FLOOR PLAN
SCALE 1:200

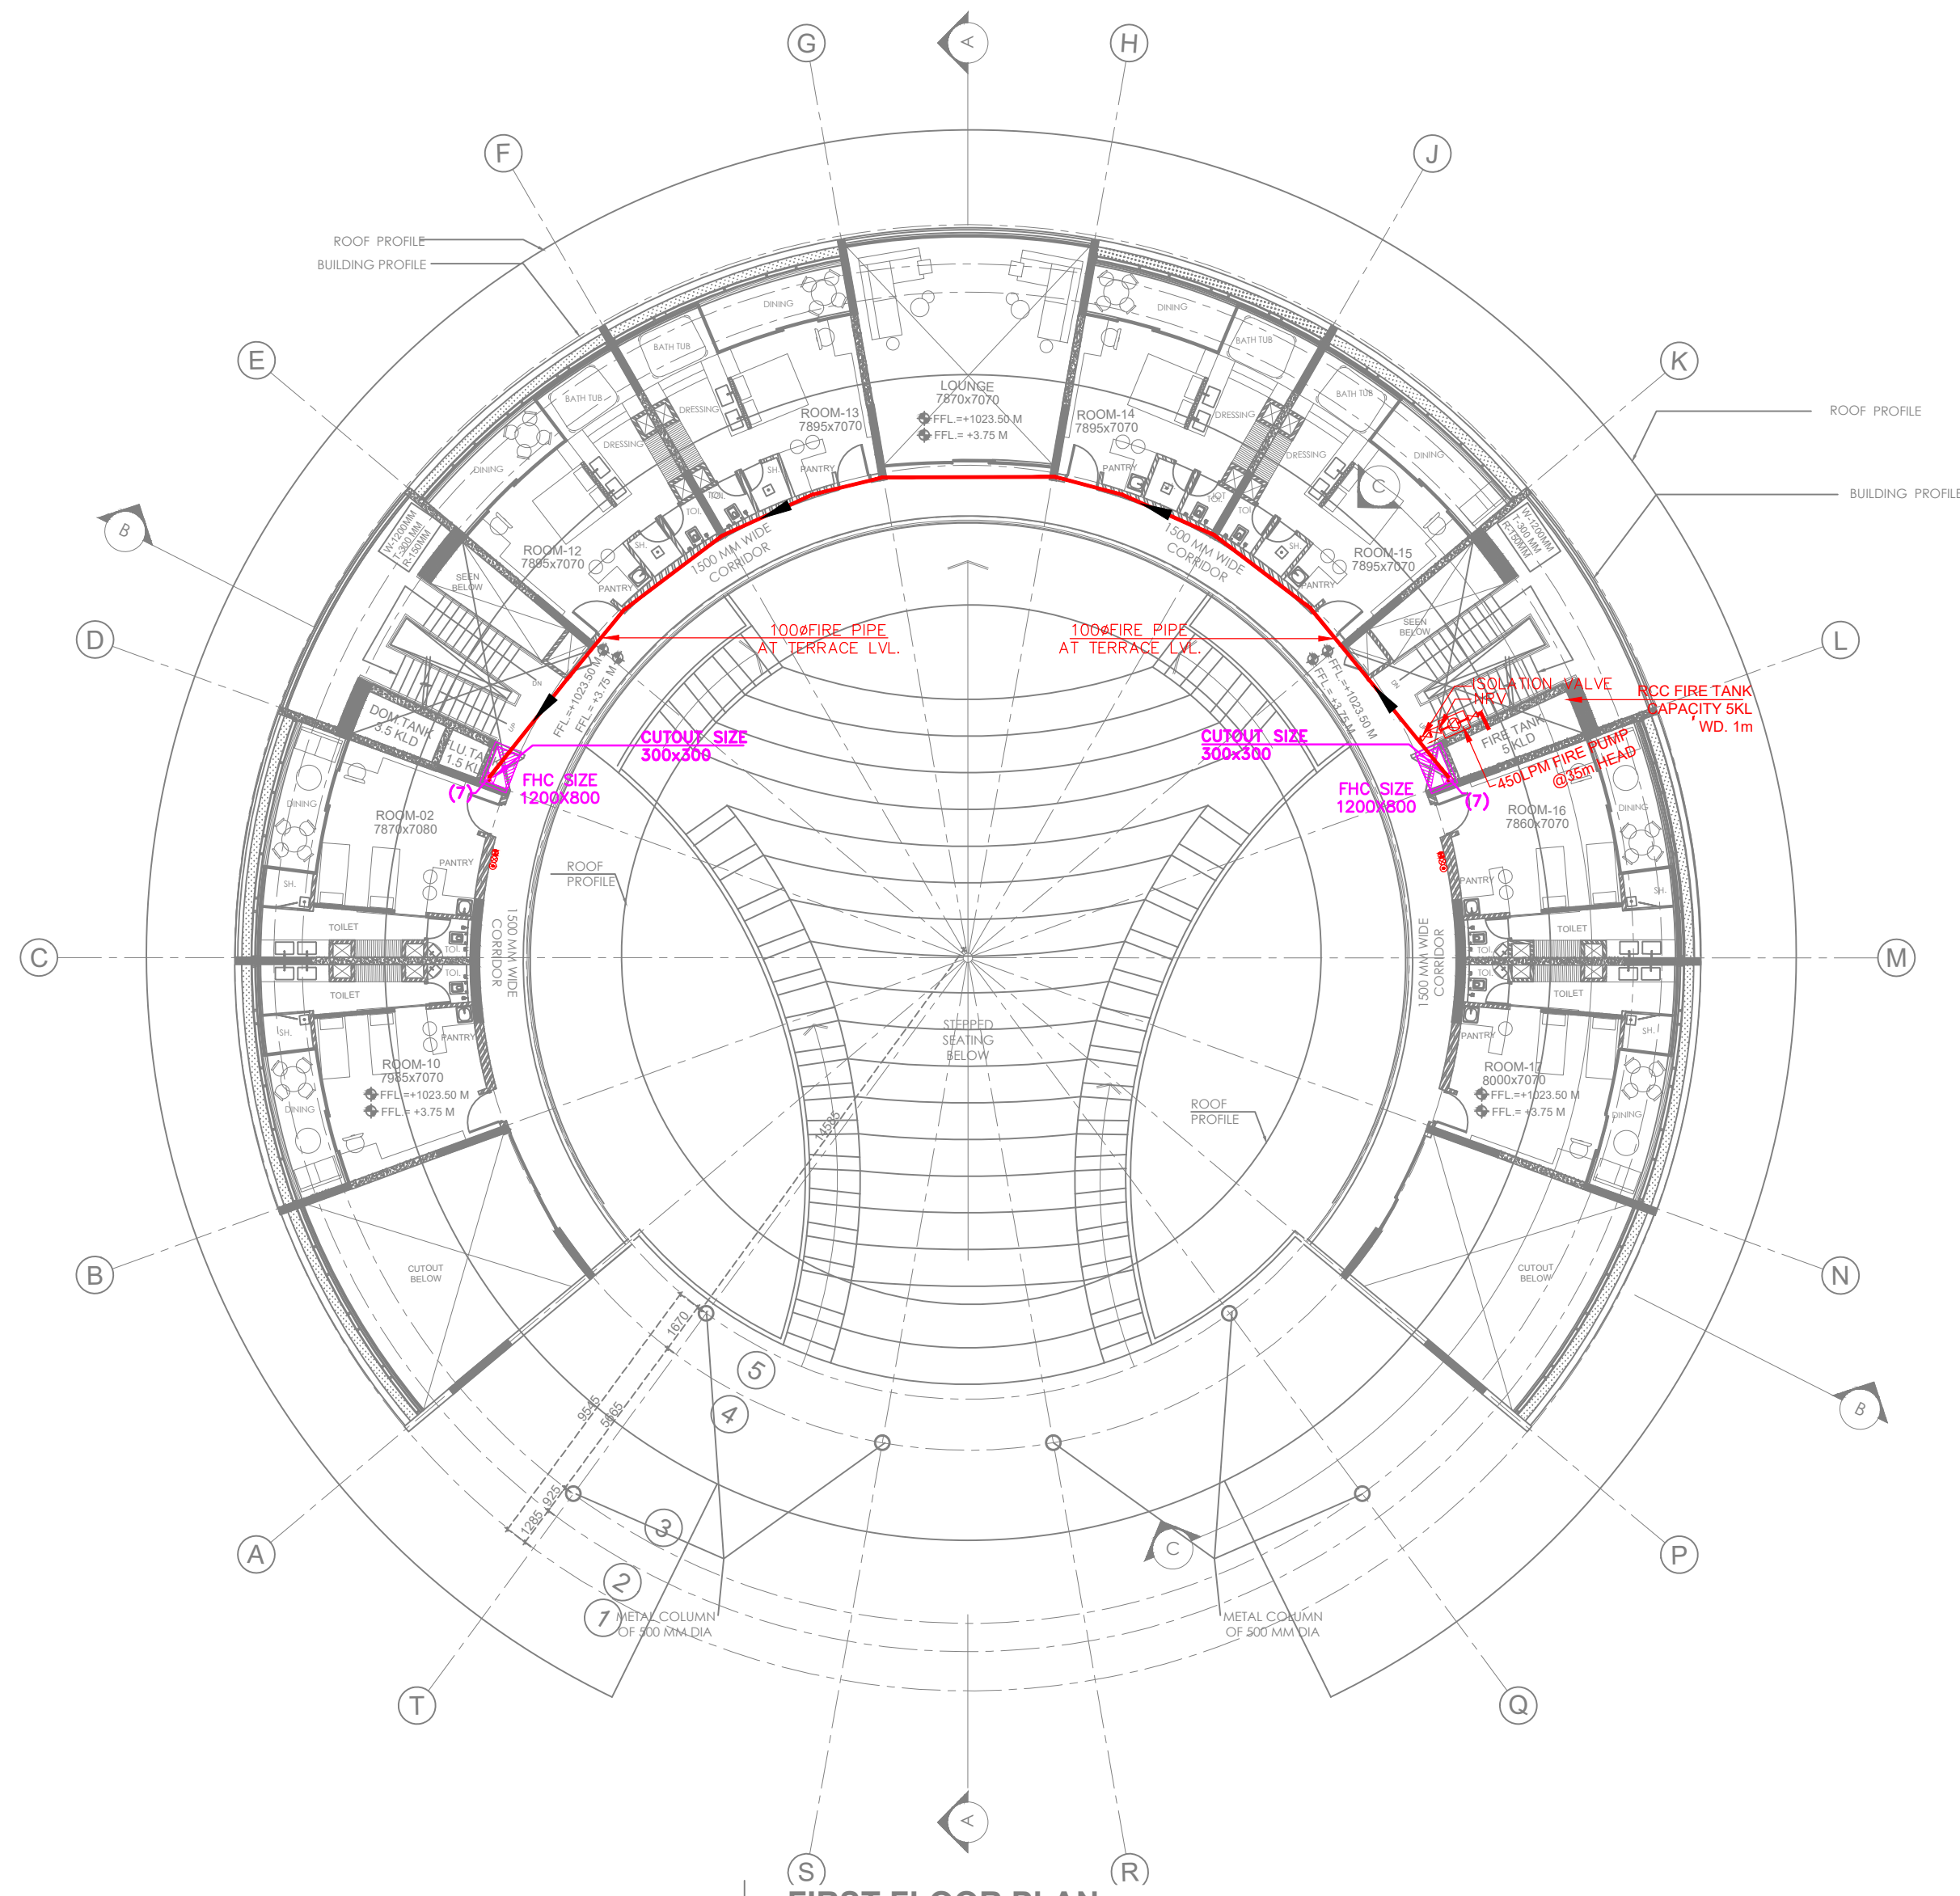

FIRST FLOOR PLAN
SCALE 1:200

LEGEND FOR FIRE FIGHTING	
(7)	100Ø FIRE PIPE
⊗	4.5KG CO2 FIRE EXTINGUISHER
⊙	6KG ABC FIRE EXTINGUISHER
⊕	9KG ABC FIRE EXTINGUISHER
FHC	FIRE HOSE CABINET (1200X800)

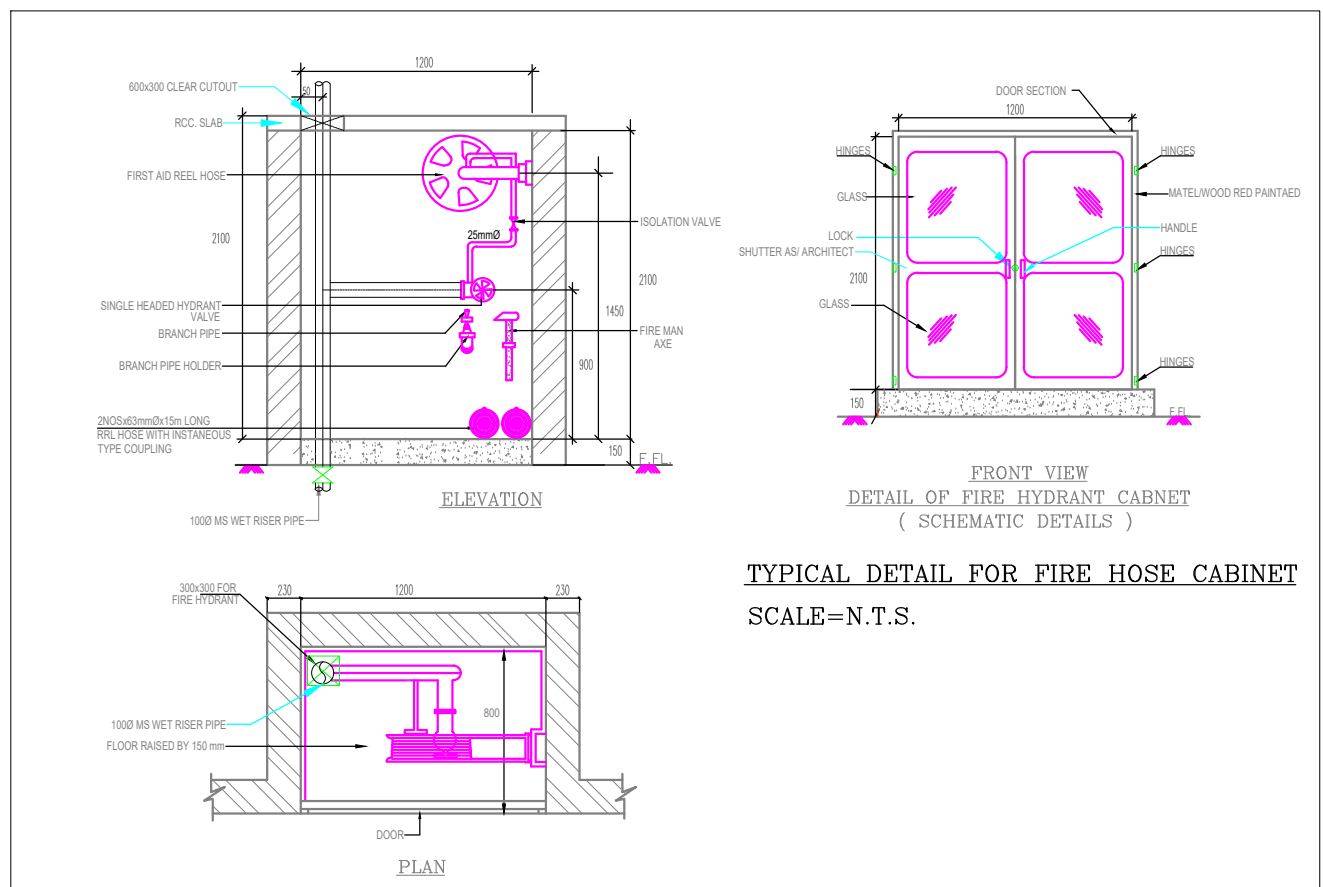

NOTES:

- DO NOT SCALE THE DRAWING. FOLLOW ONLY FIGURED DIMENSIONS.
- ALL DIMENSIONS GIVEN IN THIS DRAWING ARE IN MILLIMETERS UNLESS NOTED OTHERWISE.
- ALL DIMENSIONS TO BE VERIFIED ON SITE AND APPROVED BY THE SITE ENGINEER.
- ANY DISCREPANCY OR AMBIGUITY IN THE DRAWINGS SHOULD IMMEDIATELY BE BROUGHT TO NOTICE OF THE ARCHITECT.
- ALL DRAWINGS SHOULD BE READ IN CONJUNCTION WITH OTHER RELEVANT ARCHITECTURAL, STRUCTURAL, PLUMBING, MECHANICAL AND ELECTRICAL DRAWINGS.
- THE ± 0 REFERS TO LEVEL ESTABLISHED AT SITE IN PRESENCE OF THE SITE SUPERVISOR AND THE ARCHITECT. ALL REMAINING LEVELS ARE RELATIVE TO THIS LEVEL.
- THIS DRAWING IS THE COPYRIGHT OF ARCHOHM CONSULTANTS AND MUST NOT BE RETAINED, COPIED OR USED WITHOUT THEIR AUTHORITY.

REVISIONS			
No.	Date	Descriptions	Revision by

Client:
MEGHALAYAN AGE LIMITED (MAL)

Project:
TRIBAL HERITAGE CENTRE, MANDALGRE, MEGHALAYA

Architects:



Structural Consultants:



Electrical Consultants:



Plumbing Consultants:



Drawn By:

PK

Checked By:

SHAD

Design By:

SHAD

Sheet Title:
**FIRE FIGHTING DRAWING
TRIBAL HERITAGE CENTRE
ACCOMMODATION BLOCK**

Date:

29-08-2024

Drawing No.:

A-232409-B2-FF-01-01

Scale:


1:200

Project No.:


A-232409

A1

R0

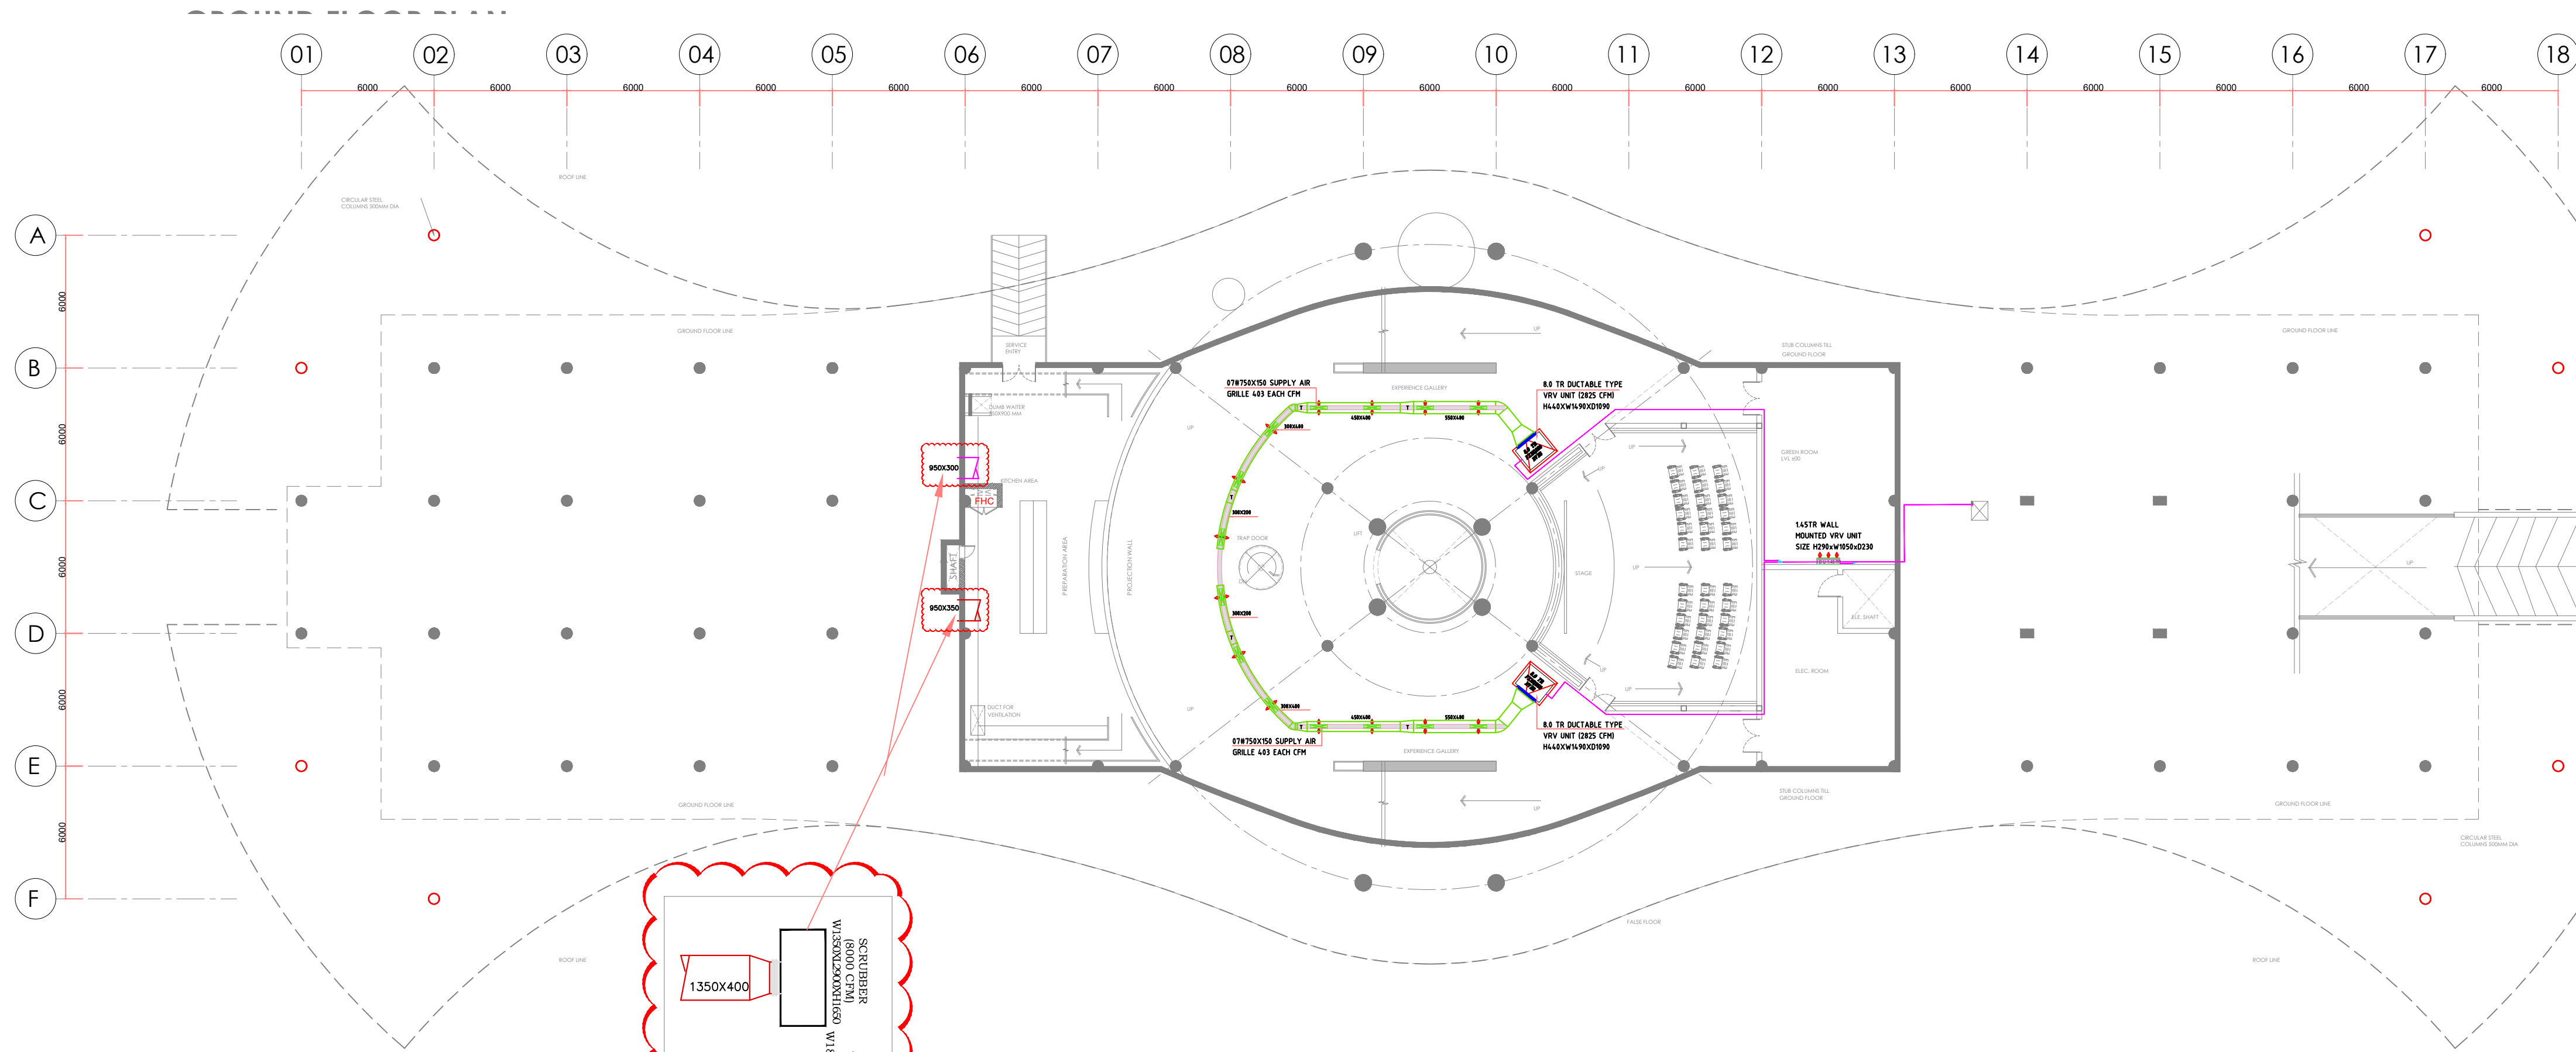

The diagram shows a rectangular terrace with a red border. Two rectangular units are positioned on the terrace. The top unit is labeled 'SCRIBBER (8000 CFM)' and 'W1300X2000H600'. The bottom unit is labeled 'AIR WASHER' and 'W1500X2500H1150'. A red line connects the text 'SCRIBBER' to the top unit. The dimensions '1350X400' are written inside the top unit, and '1200X350' are written inside the bottom unit. The word 'TERRACE' is written at the bottom of the diagram.

 LEGEND		
NO.	SYMBOL	DESCRIPTION
1.		SPLIT HI-WALL UNIT
2.		SPLIT OUTDOOR UNIT
3.		REFRIGERANT PIPE
4.		IN-LINE FAN FOR EX.
5.		SUPPLY & FRESH AIR GRILLE
6.		RETURN & EX. AIR GRILLE
		SUPPLY AIR DUCT
7.		RETURN AIR DUCT
8.		DRAIN PIPE

NOTES:

1. DO NOT SCALE THE DRAWING. FOLLOW ONLY FIGURED DIMENSIONS.
2. ALL DIMENSIONS GIVEN IN THIS DRAWING ARE IN MILLIMETERS, UNLESS NOTED OTHERWISE.
3. ALL DIMENSIONS TO BE VERIFIED ON SITE AND APPROVED BY THE SITE ENGINEER.
4. ANY DISCREPANCY OR AMBIGUITY IN THE DRAWINGS SHOULD IMMEDIATELY BE BROUGHT TO NOTICE OF THE ARCHITECT.
5. DRAWINGS SHOULD BE READ IN CONJUNCTION WITH OTHER RELEVANT ARCHITECTURAL, STRUCTURAL, PLUMBING, MECHANICAL AND ELECTRICAL DRAWINGS.
6. THE # REFERS TO LEVEL ESTABLISHED AT SITE IN PRESENCE OF THE SITE SUPERVISOR AND THE ARCHITECT. ALL REMAINING LEVELS ARE RELATIVE TO THIS LEVEL.
7. THIS DRAWING IS THE PROPERTY OF THE ARCHITECT AND MUST BE KEPT IN HIS OR HER OFFICE AND MUST NOT BE RETAINED, COPIED OR USED WITHOUT THEIR AUTHORITY.

[illegible]

Client: **MEGHALAYAN AGE LIMITED (MAL)**

Project: **TRIBAL HERITAGE CENTRE, MANDALGRE, MEGHALAYA**

Architects:



c-28c, sector-8,
noida - 201301 (up)
t 91 120 46 40 300
f 91 120 42 46 788
mail@archohm.com
www.archohm.com

Structural Consultants:
TPC TECHNICAL PROJECTS
CONSULTANTS(P)LTD.

Electrical Consultants:
 **ARCHOHM CONSULTANTS
PVT. LTD.**

	PHE Consultants
--	-----------------

Drawn By	ATEEQ
----------	-------

Sheet Title:
HVAC LAYOUT
RESEARCH & EXHIBITION CENTRE
FLOOR PLANS
(SHEET 01 OF 02)

Date: 29-08-2024

Scale:
1:200

Project No:-
A0-232409

Drawing No.:
A-232409-B1-HVAC-01-01

	A1	R0
--	----	----



WAC Engineers
INDIA PVT. LTD.
IER Consultants & Project Manager

Checked By	MUSHEER
------------	---------

Date: 29-08-2024

Scale:
1:200

Project No:-
A0-232409

Design By	MUSHEER
-----------	---------


Drawing No.:
A-232409-B1

-HVAC-01-01

	A1	R0
--	----	----

LEGEND

NO.	SYMBOL	DESCRIPTION
1.		SPLIT HI-WALL UNIT
2.		SPLIT OUTDOOR UNIT
3.		REFRIGRANT PIPE
4.		IN-LINE FAN FOR EX.
5.		SUPPLY & FRESH AIR GRILLE
6.		RETURN & EX. AIR GRILLE
7.		SUPPLY AIR DUCT
8.		RETURN AIR DUCT
8.		DRAIN PIPE

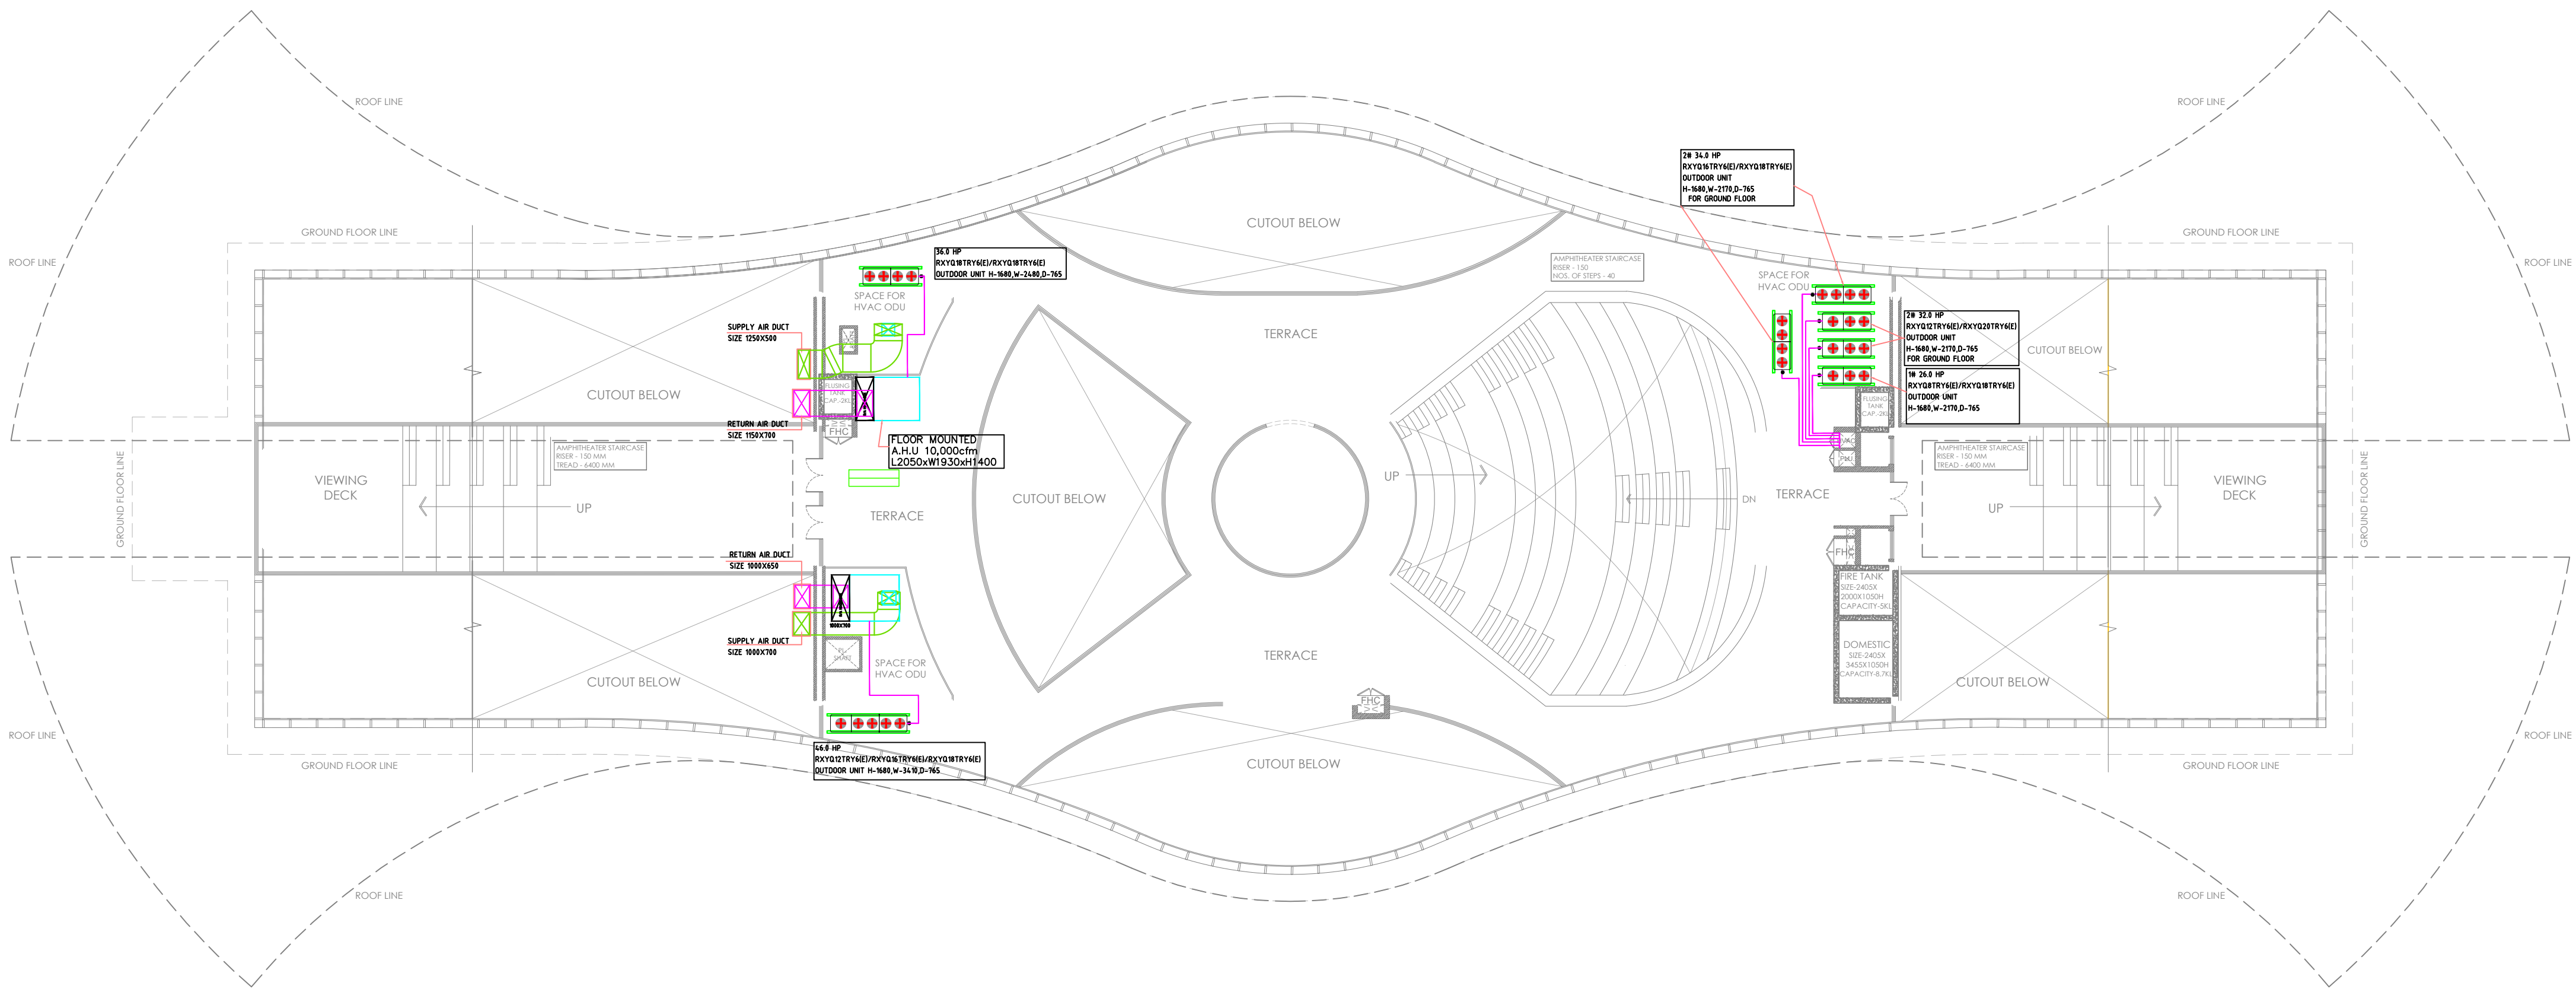

NOTES:

- DO NOT SCALE THE DRAWING. FOLLOW ONLY FIGURED DIMENSIONS.
- ALL DIMENSIONS GIVEN IN THIS DRAWING ARE IN MILLIMETERS UNLESS NOTED OTHERWISE.
- ALL DIMENSIONS TO BE VERIFIED ON SITE AND APPROVED BY THE SITE ENGINEER.
- ANY DISCREPANCY OR AMBIGUITY IN THE DRAWINGS SHOULD IMMEDIATELY BE BROUGHT TO NOTICE OF THE ARCHITECT.
- ALL DRAWINGS SHOULD BE READ IN CONJUNCTION WITH OTHER RELEVANT ARCHITECTURAL, STRUCTURAL, PLUMBING, MECHANICAL AND ELECTRICAL DRAWINGS.
- THE ± 0 REFERS TO LEVEL ESTABLISHED AT SITE IN PRESENCE OF THE SITE SUPERVISOR AND THE ARCHITECT. ALL REMAINING LEVELS ARE RELATIVE TO THIS LEVEL.
- THIS DRAWING IS THE COPYRIGHT OF ARCHOHM CONSULTANTS AND MUST NOT BE RETAINED, COPIED OR USED WITHOUT THEIR AUTHORITY.

REVISIONS

No.	Date	Descriptions	Revision by


Client:

MEGHALAYAN AGE LIMITED (MAL)


Project:

TRIBAL HERITAGE CENTRE, MANDALGRE, MEGHALAYA


Architects:

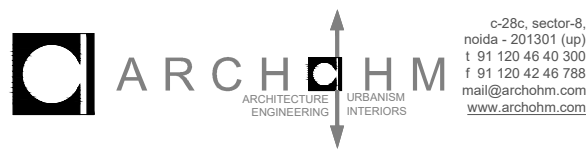

Structural Consultants:

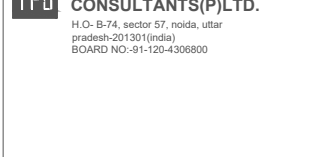

Electrical Consultants:

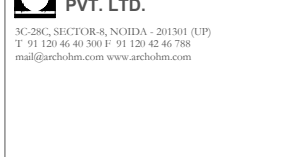

P&E Consultants:



Drawn By:

ATEEO

Checked By:

MUSHEER

Design By:

MUSHEER

Sheet Title:
HVAC LAYOUT
RESEARCH & EXHIBITION CENTRE
TERRACE FLOOR PLANS
(SHEET 02 OF 02)

Date:

29-08-2024

Scale:

1:200

Project No.:


A0-232409

Drawing No.:


A-232409-B1-HVAC-01-02

A1

R0

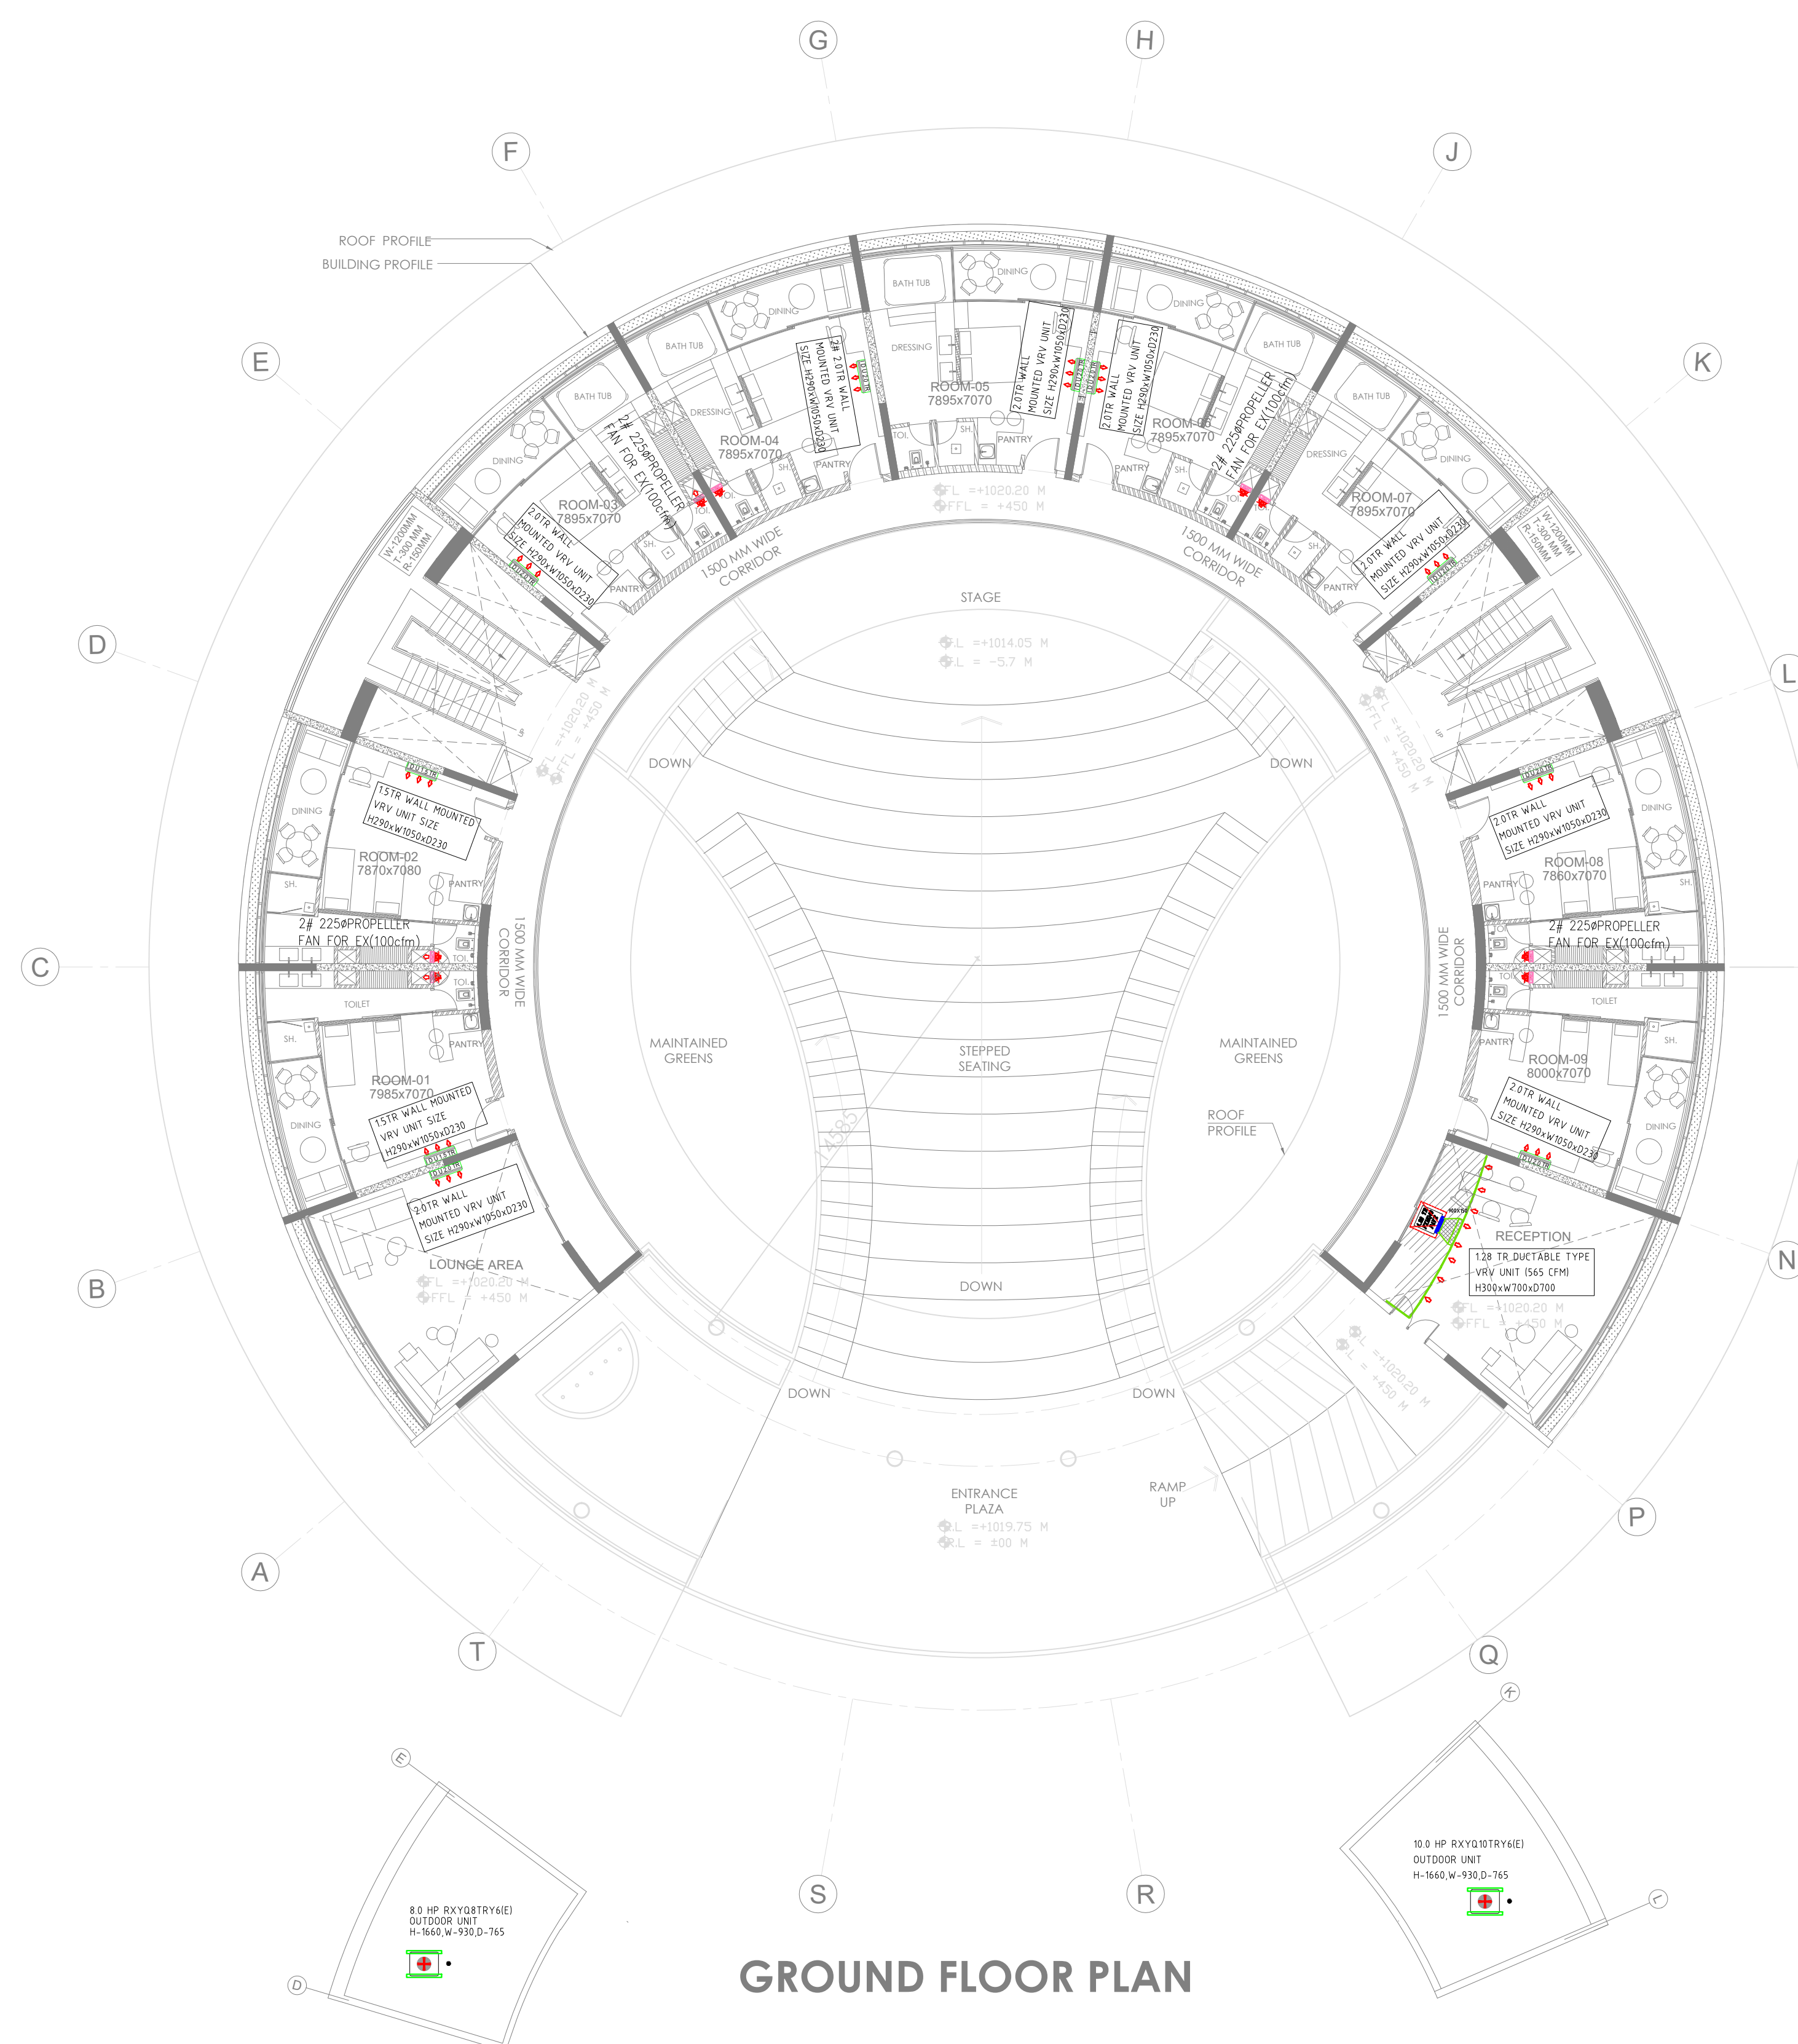

GROUND FLOOR PLAN

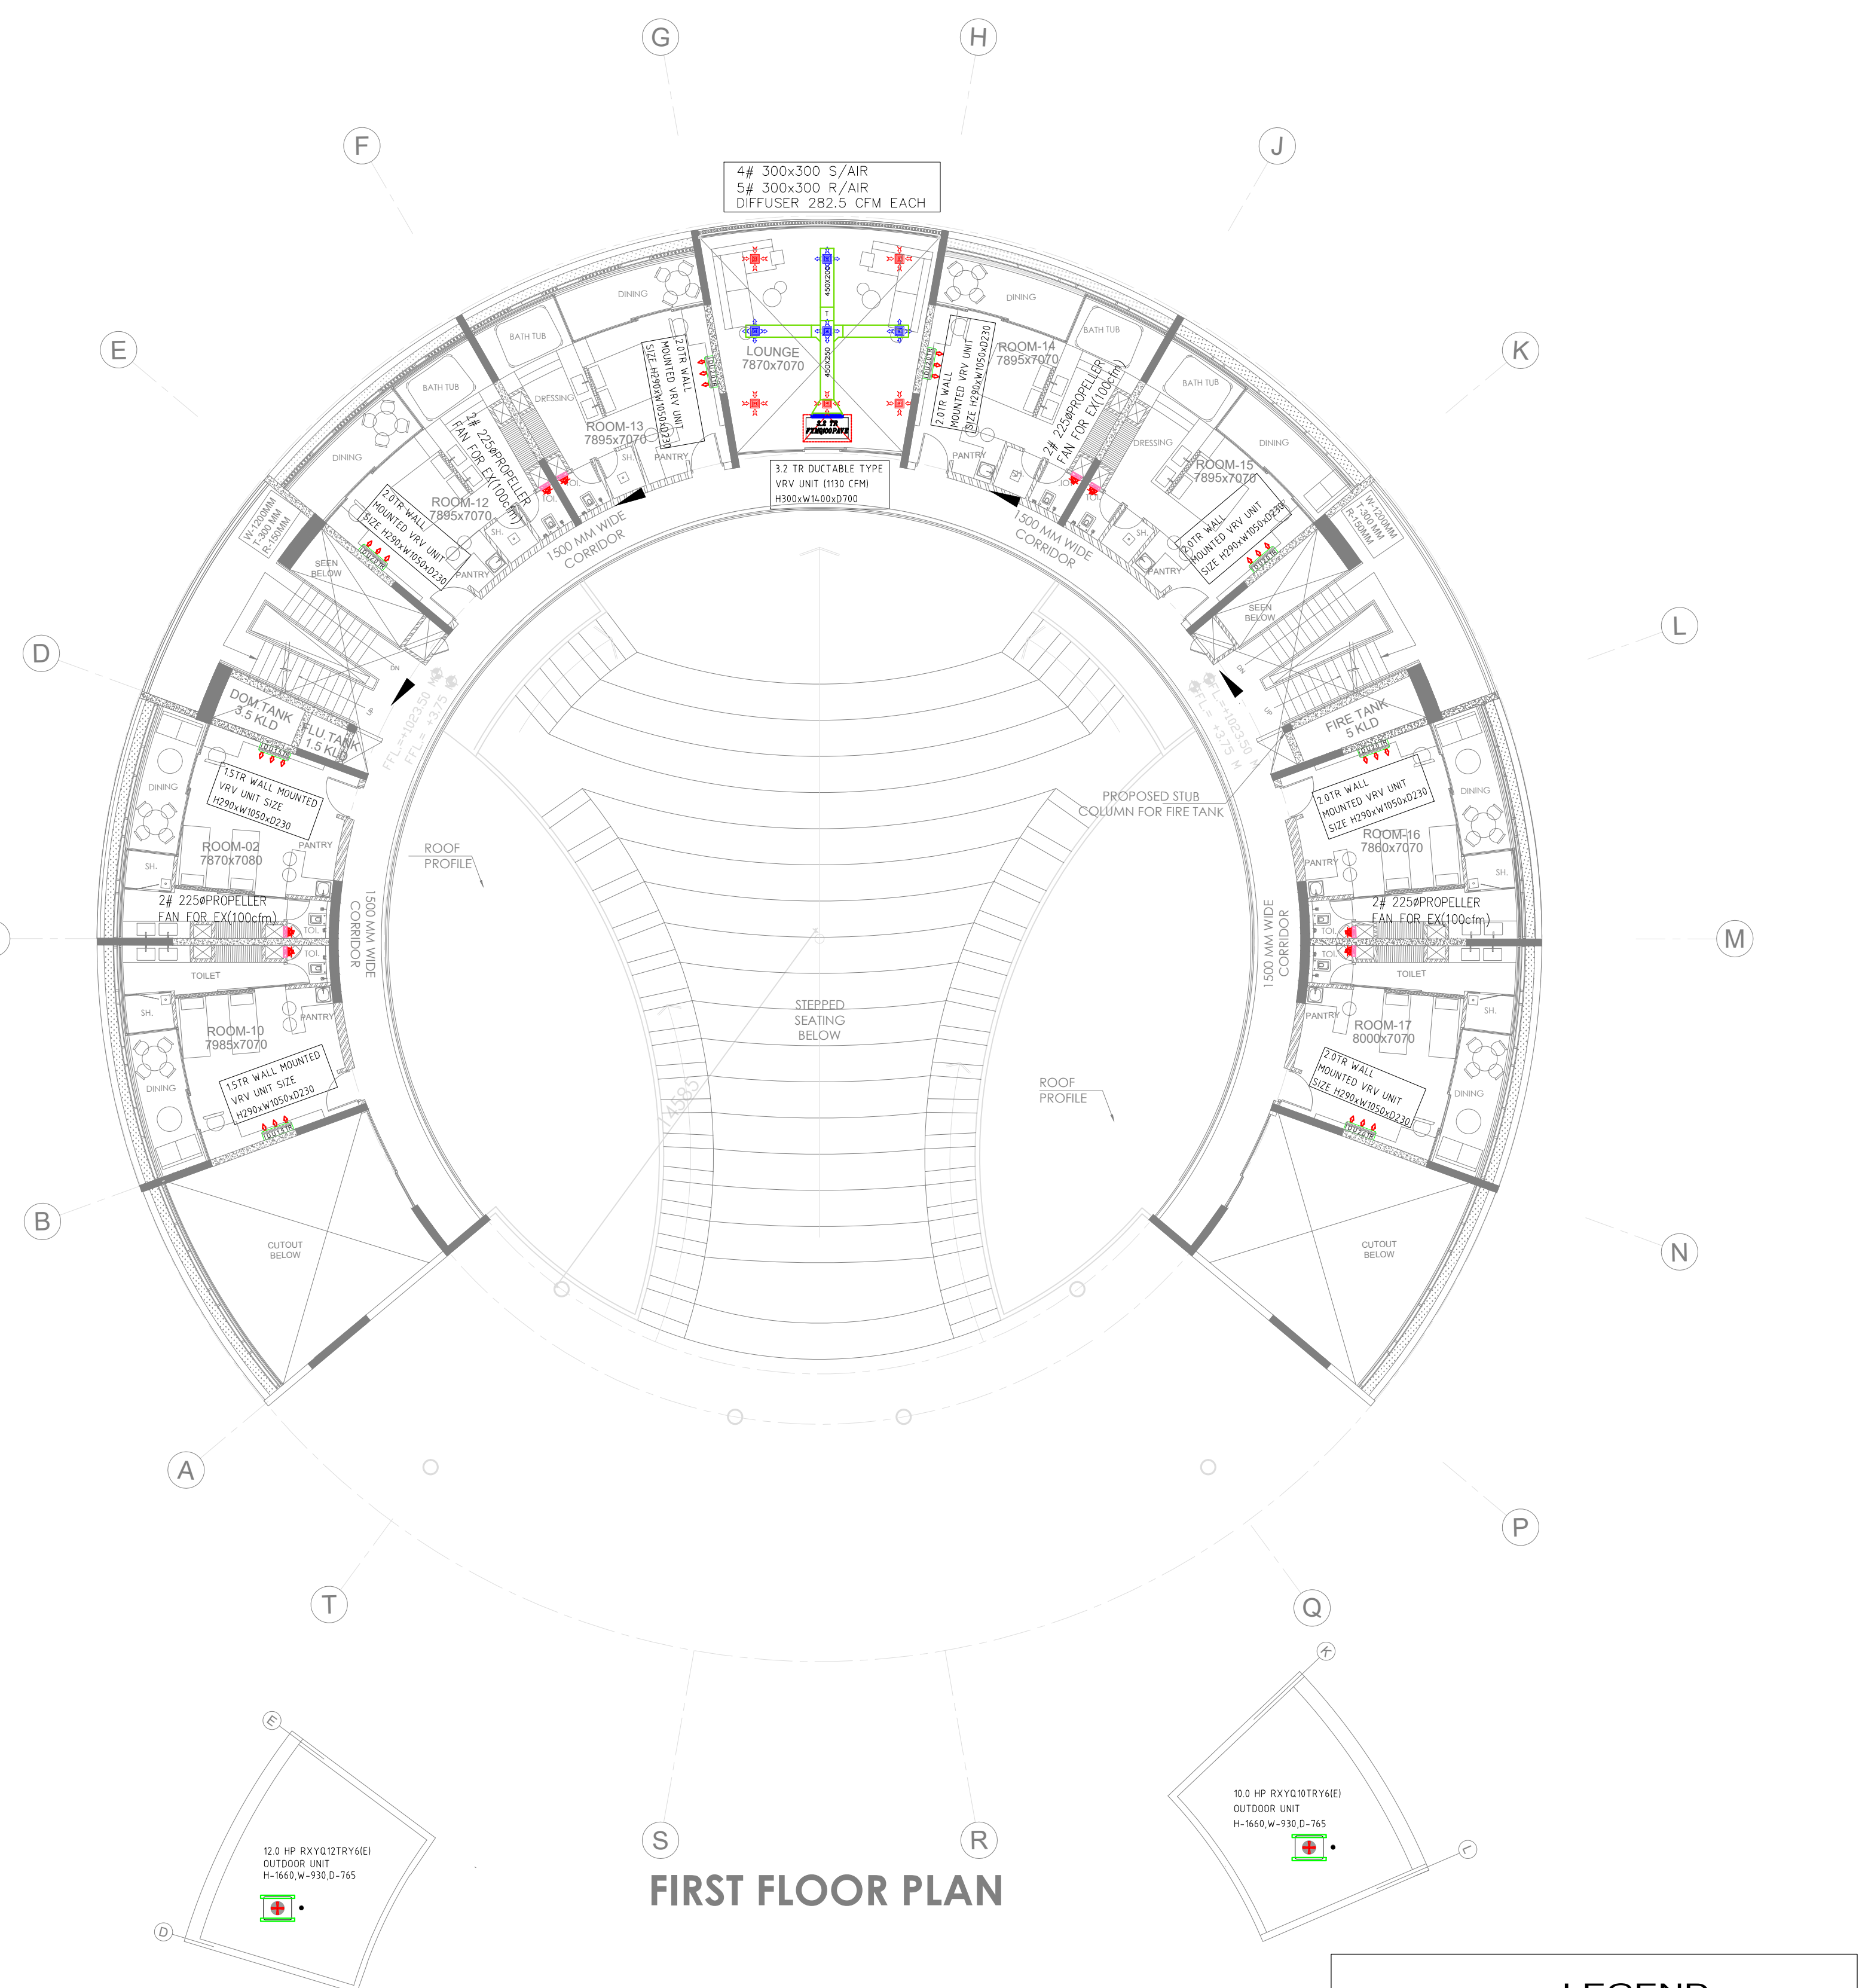

FIRST FLOOR PLAN

LEGEND		
NO	SYMBOL	DESCRIPTION
1.		SPLIT HI-WALL UNIT
2.		SPLIT OUTDOOR UNIT
3.		REFRIGRANT PIPE
4.		IN-LINE FAN FOR EX.
5.		SUPPLY & FRESH AIR GRILLE
6.		RETURN & EX. AIR GRILLE
7.		SUPPLY AIR DUCT
8.		RETURN AIR DUCT
9.		DRAIN PIPE

NOTES:

- DO NOT SCALE THE DRAWING. FOLLOW ONLY FIGURED DIMENSIONS.
- ALL DIMENSIONS GIVEN IN THIS DRAWING ARE IN MILLIMETERS UNLESS NOTED OTHERWISE.
- ALL DIMENSIONS TO BE VERIFIED ON SITE AND APPROVED BY THE SITE ENGINEER.
- ANY DISCREPANCY OR AMBIGUITY IN THE DRAWINGS SHOULD IMMEDIATELY BE BROUGHT TO NOTICE OF THE ARCHITECT.
- ALL DRAWINGS SHOULD BE READ IN CONJUNCTION WITH OTHER RELEVANT ARCHITECTURAL, STRUCTURAL, PLUMBING, MECHANICAL AND ELECTRICAL DRAWINGS.
- THE ± 0 REFERS TO LEVEL ESTABLISHED AT SITE IN PRESENCE OF THE SITE SUPERVISOR AND THE ARCHITECT. ALL REMAINING LEVELS ARE RELATIVE TO THIS LEVEL.
- THIS DRAWING IS THE COPYRIGHT OF ARCHOHM CONSULTANTS & PROJECT MANAGERS AND MUST NOT BE RETAINED, COPIED OR USED WITHOUT THEIR AUTHORITY.

REVISIONS			
No.	Date	Descriptions	Revision by

Client:
MEGHALAYAN AGE LIMITED (MAL)

Project: **TRIBAL HERITAGE CENTRE, MANDALGRE, MEGHALAYA**


Architects:
ARCHOHM CONSULTANTS & PROJECT MANAGERS

Structural Consultants:
TPC TECHNICAL PROJECTS CONSULTANTS PVT. LTD.

Electrical Consultants:
ARCHOHM CONSULTANTS PVT. LTD.

Mechanical Consultants:
ARCHOHM CONSULTANTS PVT. LTD.

Sheet Title: HVAC LAYOUT RESEARCHERS ACCOMMODATION FLOOR PLANS & SECTION	Drawn By: AM	Checked By: GK	Design By: SG	Date: 15-03-2024	Scale: 1:200	Project No.: A0-212216	Drawing No.: A-232409-B2-HVAC-01-01	A1	R0
---	-----------------	-------------------	------------------	---------------------	-----------------	---------------------------	--	----	----

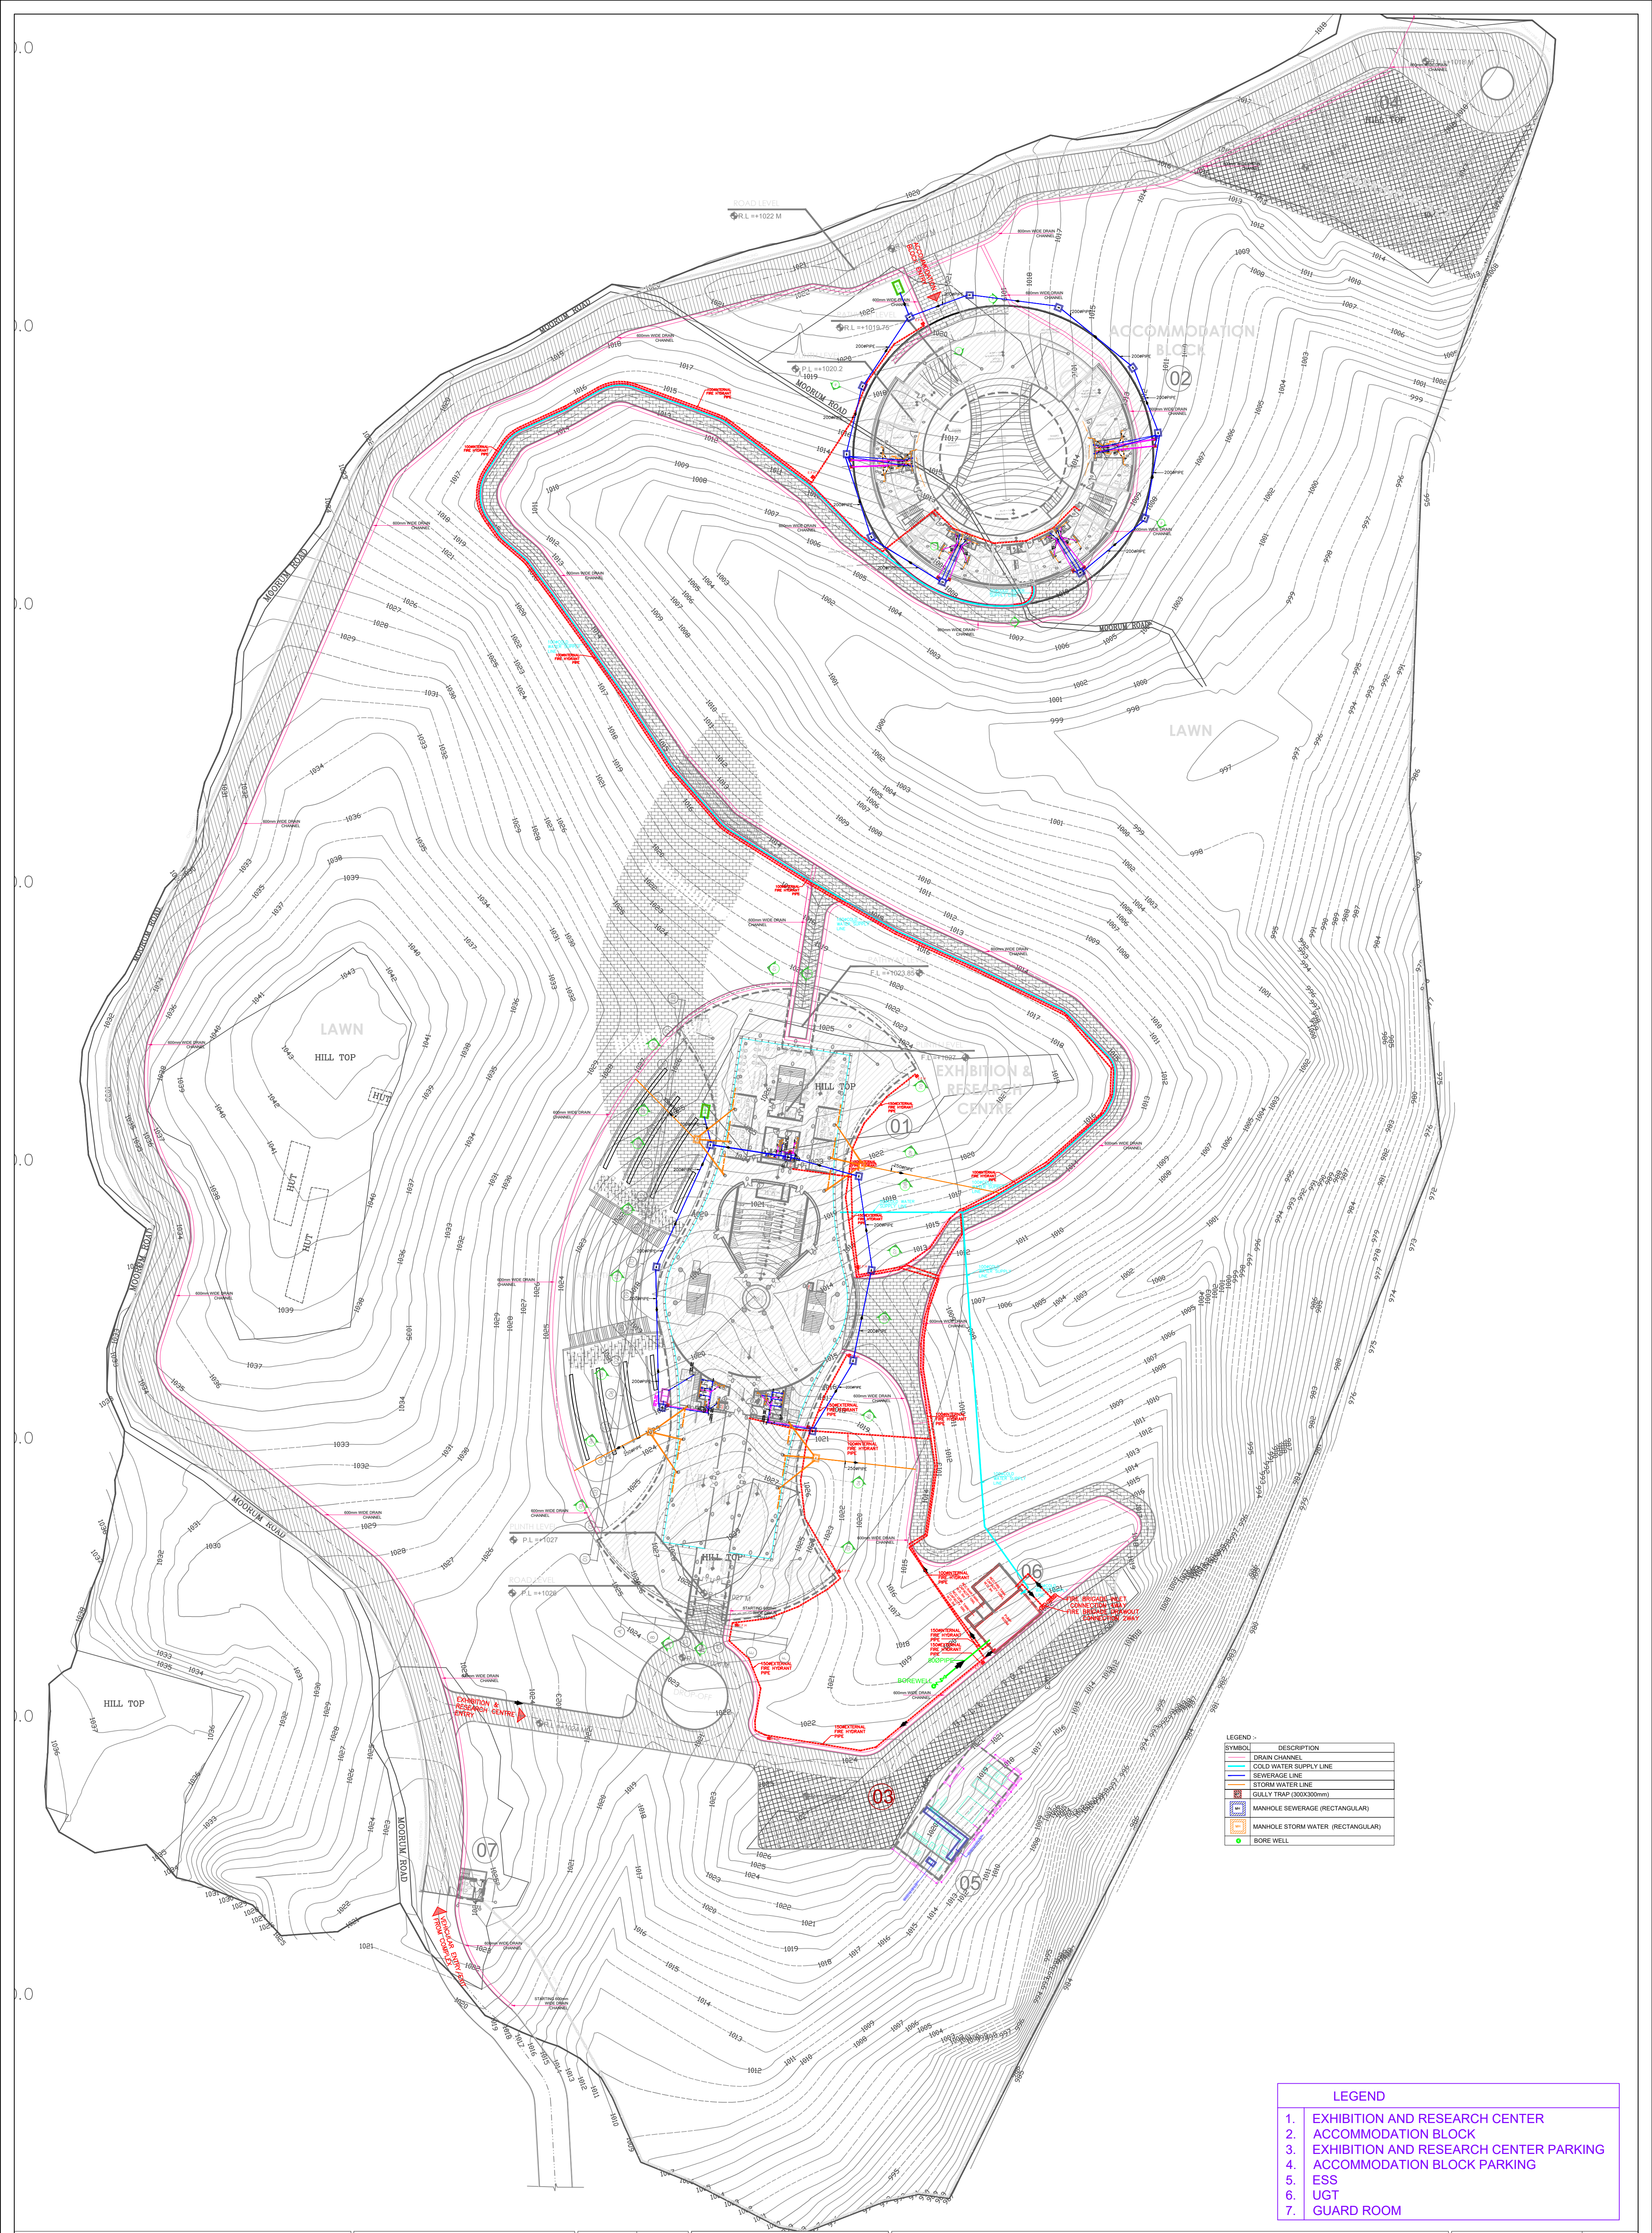

SYMBOL	DESCRIPTION
	DRAIN CHANNEL
	COLD WATER SUPPLY LINE
	SEWERAGE LINE
	STORM WATER LINE
	GULLY TRAP (300X300mm)
	MANHOLE SEWERAGE (RECTANGULAR)
	MANHOLE STORM WATER (RECTANGULAR)
	BORE WELL

LEGEND	
1.	EXHIBITION AND RESEARCH CENTER
2.	ACCOMMODATION BLOCK
3.	EXHIBITION AND RESEARCH CENTER PARKING
4.	ACCOMMODATION BLOCK PARKING
5.	ESS
6.	UGT
7.	GUARD ROOM

NOTES:

1. DO NOT SCALE THE DRAWING. FOLLOW ONLY FIGURED DIMENSIONS.

2. ALL DIMENSIONS GIVEN IN THIS DRAWING ARE IN MILLIMETERS UNLESS NOTED OTHERWISE.

3. ALL DIMENSIONS TO BE VERIFIED ON SITE AND APPROVED BY THE SITE ENGINEER.

4. ANY DISCREPANCY OR AMBIGUITY IN THE DRAWINGS SHOULD IMMEDIATELY BE BROUGHT TO THE ATTENTION OF THE ARCHITECT.

5. ALL DRAWINGS SHOULD BE READ IN CONJUNCTION WITH OTHER RELEVANT ARCHITECTURAL, STRUCTURAL, PLUMBING, MECHANICAL AND ELECTRICAL DRAWINGS.

6. THE U.P. PERSPECTIVE LEVEL ESTABLISHED AT SITE IN PRESENCE OF THE SITE SUPERVISOR AND THE ARCHITECT. ALL REMAINING LEVELS ARE RELATIVE TO THIS LEVEL.

7. THIS DRAWING IS THE COPYRIGHT OF ARCHQHM CONSULTANTS AND MUST NOT BE REPRODUCED, COPIED OR USED WITHOUT THEIR AUTHORITY.

REVISIONS

No.	Date	Descriptions	Revision by

Client:

MEGHALAYAN AGE LIMITED (MAL)

Project:

TRIBAL HERITAGE CENTRE, MANDALGRE, MEGHALAYA

Architects:

ARCHQHM CONSULTANTS

Structural Consultants:

TPC TECHNICAL PROJECTS CONSULTANTS PVT. LTD.

Electrical Consultants:

ARCHQHM CONSULTANTS PVT. LTD.

Mechanical Consultants:

WAC ENGINEERS

Drawn By:

PRATEEK

Checked By:

MS

Design By:

SHAFIYAD

Sheet Title:

PLUMBING DRAWING TRIBAL HERITAGE CENTRE SITE PLAN

Date:

29.08.2024

Scale:

1:500

Project No.:


A-232409

Drawing No.:


A-232409-PL-01

A1

R0

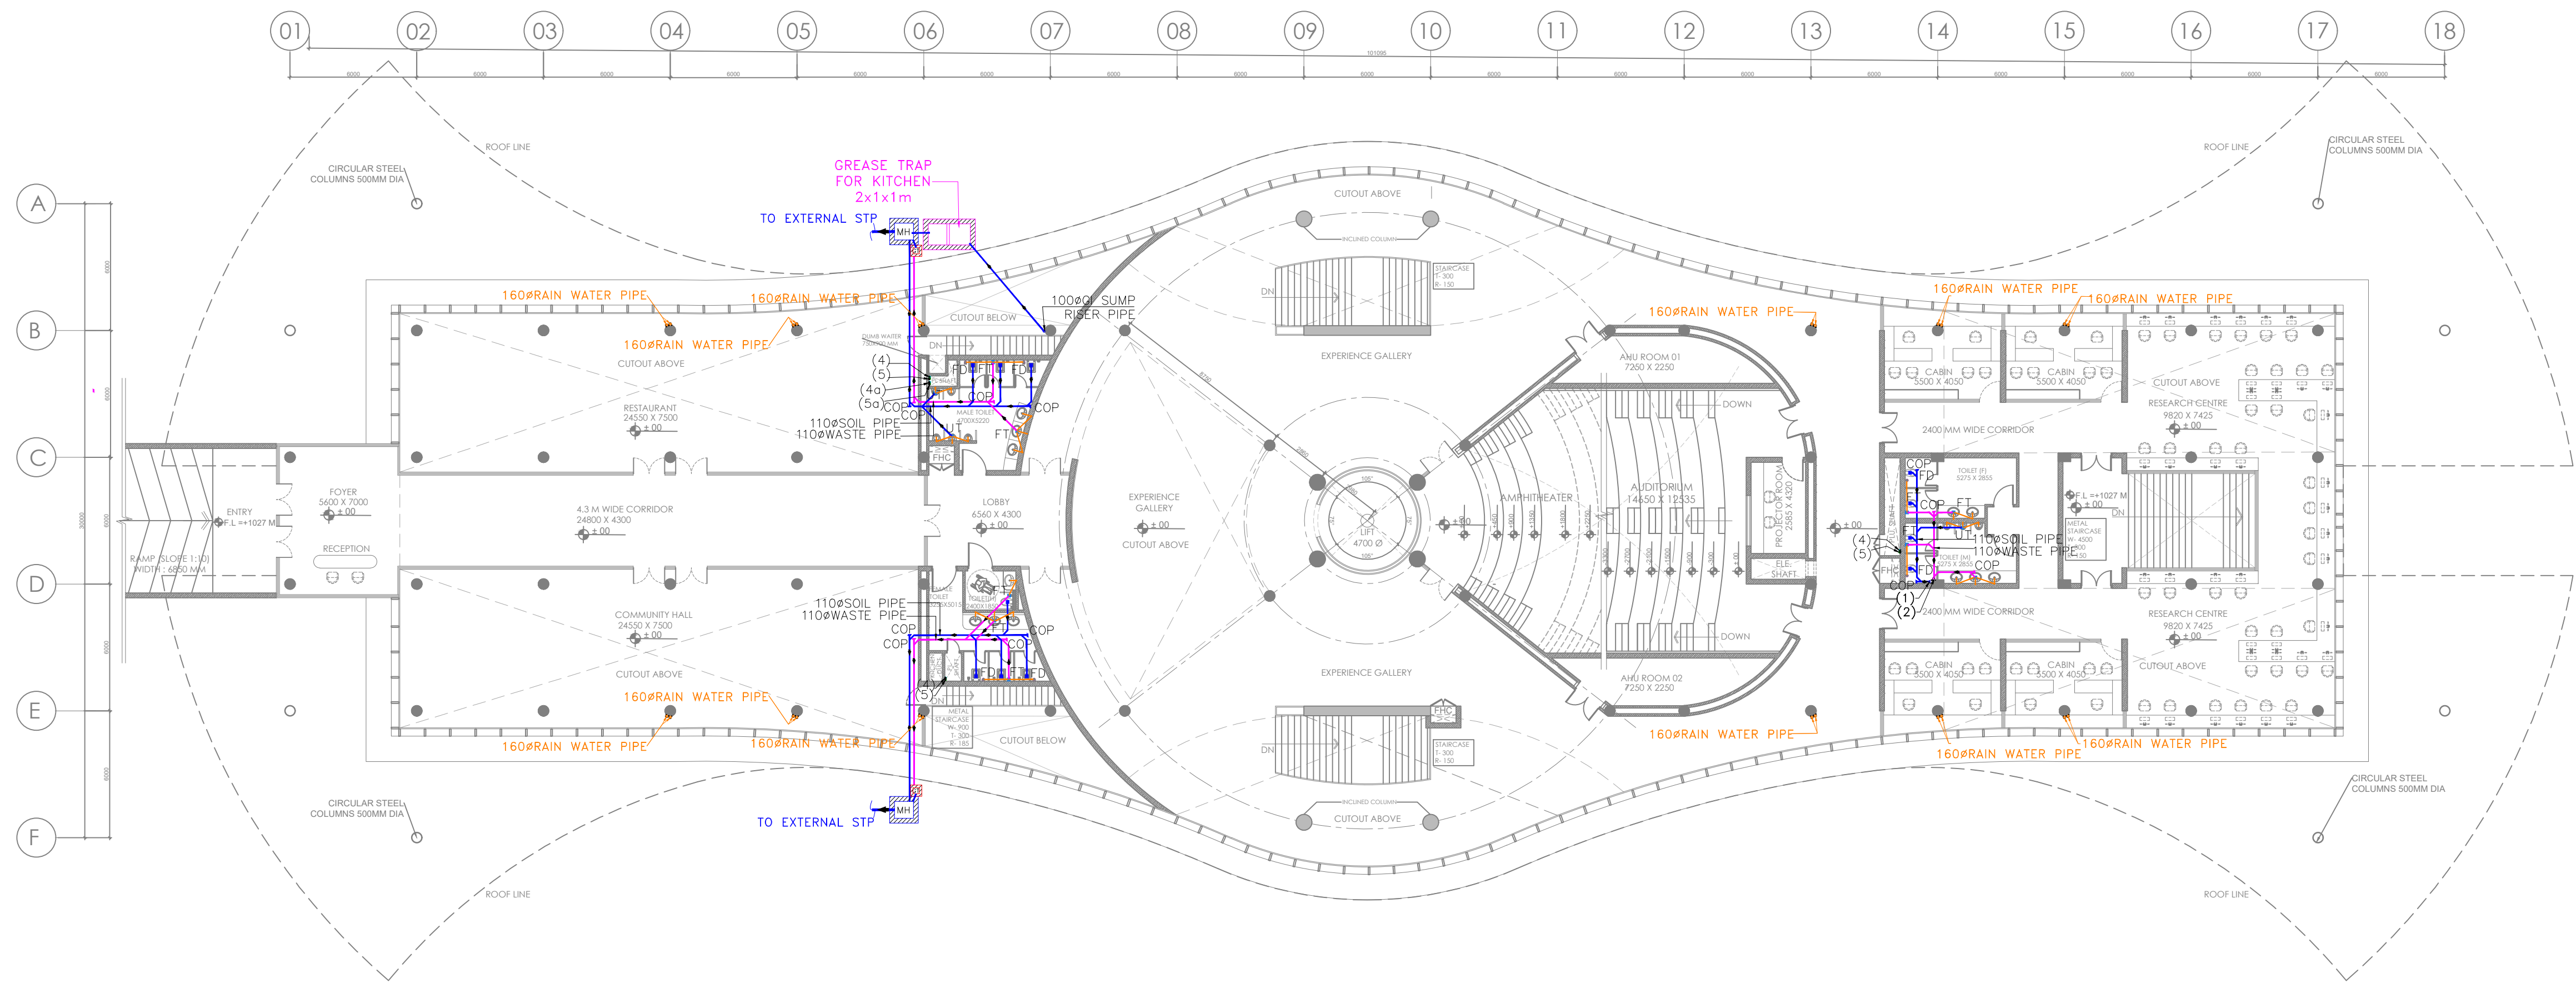

03 GROUND FLOOR PLAN
SCALE 1:200

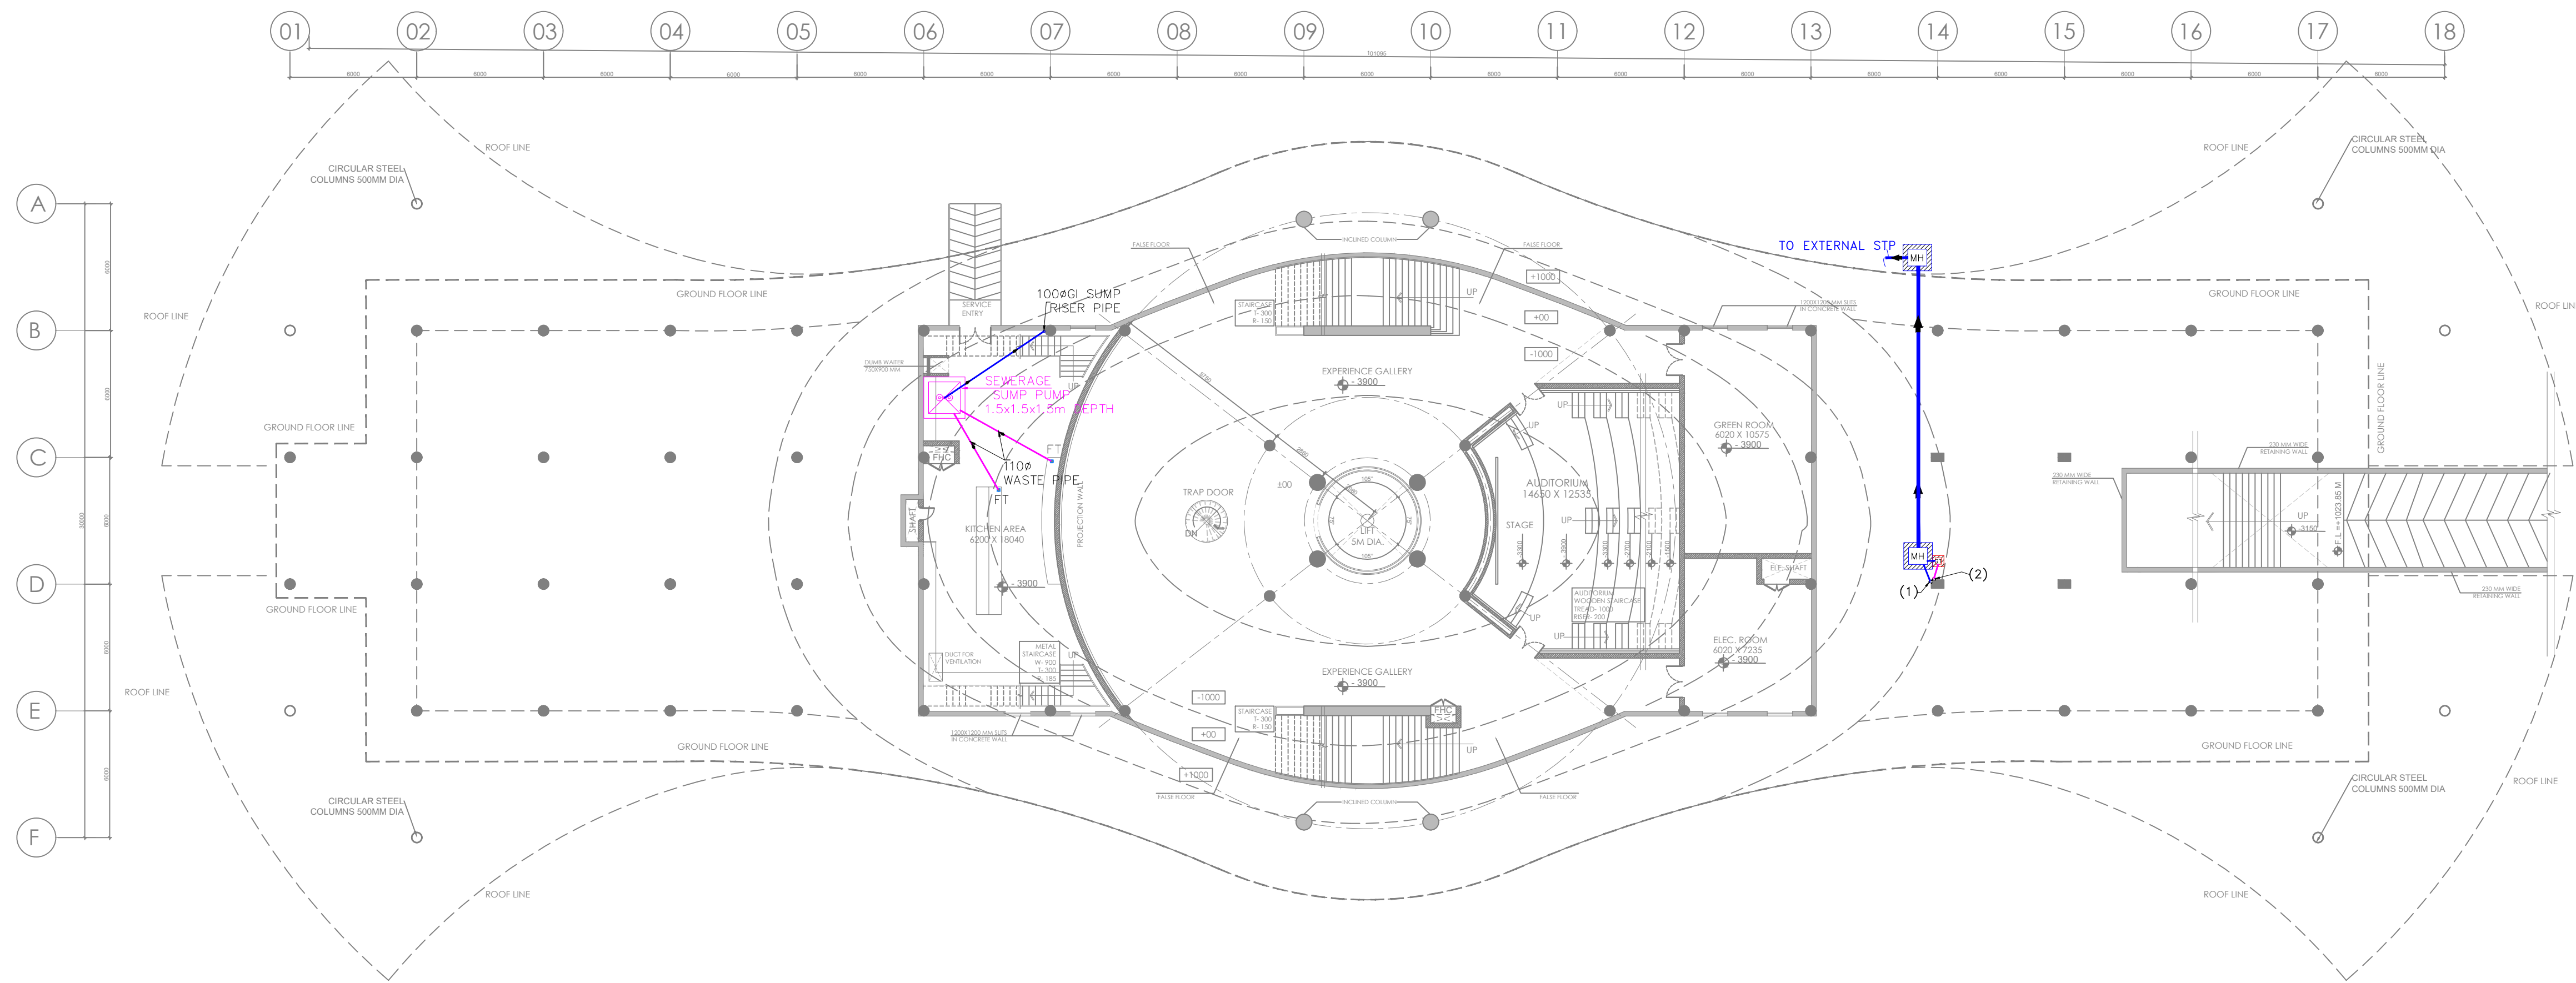

02 LOWER GROUND FLOOR PLAN
SCALE 1:200

LEGEND FOR PLUMBING PIPE	
(1) 110ø SOIL & VENT PIPE	—
(2) 110ø WASTE & VENT PIPE	—
(4) COLD WATER SUPPLY PIPE	—
(4ø) COLD WATER RISER PIPE	—
(5ø) FLUSHING WATER RISER PIPE	—
(10ø) 160ø RAIN WATER PIPE	—
FD FLOOR DRAIN 110X63mm	—
FT FLOOR TRAP 110X110mm	—
CUTOUT SIZE 150mmX150mm	—
W.C CUTOUT SIZE 150mmX150mm	—
CWS COLD WATER SUPPLY	—
CWR COLD WATER RISER	—
FWS FLUSHING WATER SUPPLY	—
FWR FLUSHING WATER RISER	—
VALVE	—

NOTE:-

- FD TO FT 63ø WASTE PIPE
- WASH BASIN TO FT 40ø WASTE PIPE
- SINK TO FT 50ø WASTE PIPE
- URINAL TO URINAL TRAP 50ø SOIL PIPE

LEGEND FOR PLUMBING PIPE	
(1) 110ø SOIL & VENT PIPE	—
(2) 110ø WASTE & VENT PIPE	—
(4) COLD WATER SUPPLY PIPE	—
(4ø) COLD WATER RISER PIPE	—
(5ø) FLUSHING WATER RISER PIPE	—
(10ø) 160ø RAIN WATER PIPE	—
FD FLOOR DRAIN 110X63mm	—
FT FLOOR TRAP 110X110mm	—
CUTOUT SIZE 150mmX150mm	—
W.C CUTOUT SIZE 150mmX150mm	—
CWS COLD WATER SUPPLY	—
CWR COLD WATER RISER	—
FWS FLUSHING WATER SUPPLY	—
FWR FLUSHING WATER RISER	—
VALVE	—

NOTE:-

- FD TO FT 63ø WASTE PIPE
- WASH BASIN TO FT 40ø WASTE PIPE
- SINK TO FT 50ø WASTE PIPE
- URINAL TO URINAL TRAP 50ø SOIL PIPE

NOTES:

- DO NOT SCALE THE DRAWING. FOLLOW ONLY FIGURED DIMENSIONS.
- ALL DIMENSIONS GIVEN IN THIS DRAWING ARE IN MILLIMETERS UNLESS NOTED OTHERWISE.
- ALL DIMENSIONS TO BE VERIFIED ON SITE AND APPROVED BY THE SITE ENGINEER.
- ANY DISCREPANCY OR AMBIGUITY IN THE DRAWINGS SHOULD IMMEDIATELY BE BROUGHT TO NOTICE OF THE ARCHITECT.
- ALL DRAWINGS SHOULD BE READ IN CONJUNCTION WITH OTHER RELEVANT ARCHITECTURAL, STRUCTURAL, PLUMBING, MECHANICAL AND ELECTRICAL DRAWINGS.
- THE ± 0 REFERS TO LEVEL ESTABLISHED AT SITE IN PRESENCE OF THE SITE SUPERVISOR AND THE ARCHITECT. ALL REMAINING LEVELS ARE RELATIVE TO THIS LEVEL.
- THIS DRAWING IS THE COPYRIGHT OF ARCHOHM CONSULTANTS AND MUST NOT BE RETAINED, COPIED OR USED WITHOUT THEIR AUTHORITY.

REVISIONS			
No.	Date	Descriptions	Revision by

Client:
MEGHALAYAN AGE LIMITED (MAL)

Project: **TRIBAL HERITAGE CENTRE, MANDALGRE, MEGHALAYA**

Architects:



Structural Consultants:



Electrical Consultants:



P&E Consultants:



Drawn By:

PRATEEK



Checked By:

M.S

Design By:

SHAHHAD

Sheet Title: TRIBAL HERITAGE CENTRE EXHIBITION & RESEARCH CENTER FLOOR PLANS PLUMBING SYSTEM (SHEET 01 OF 02)	Date: 29-08-2024	Scale: 1:200	Project No.: A-232409
Drawing No.: A-232409-B1-PL-01-01	A1	R0	

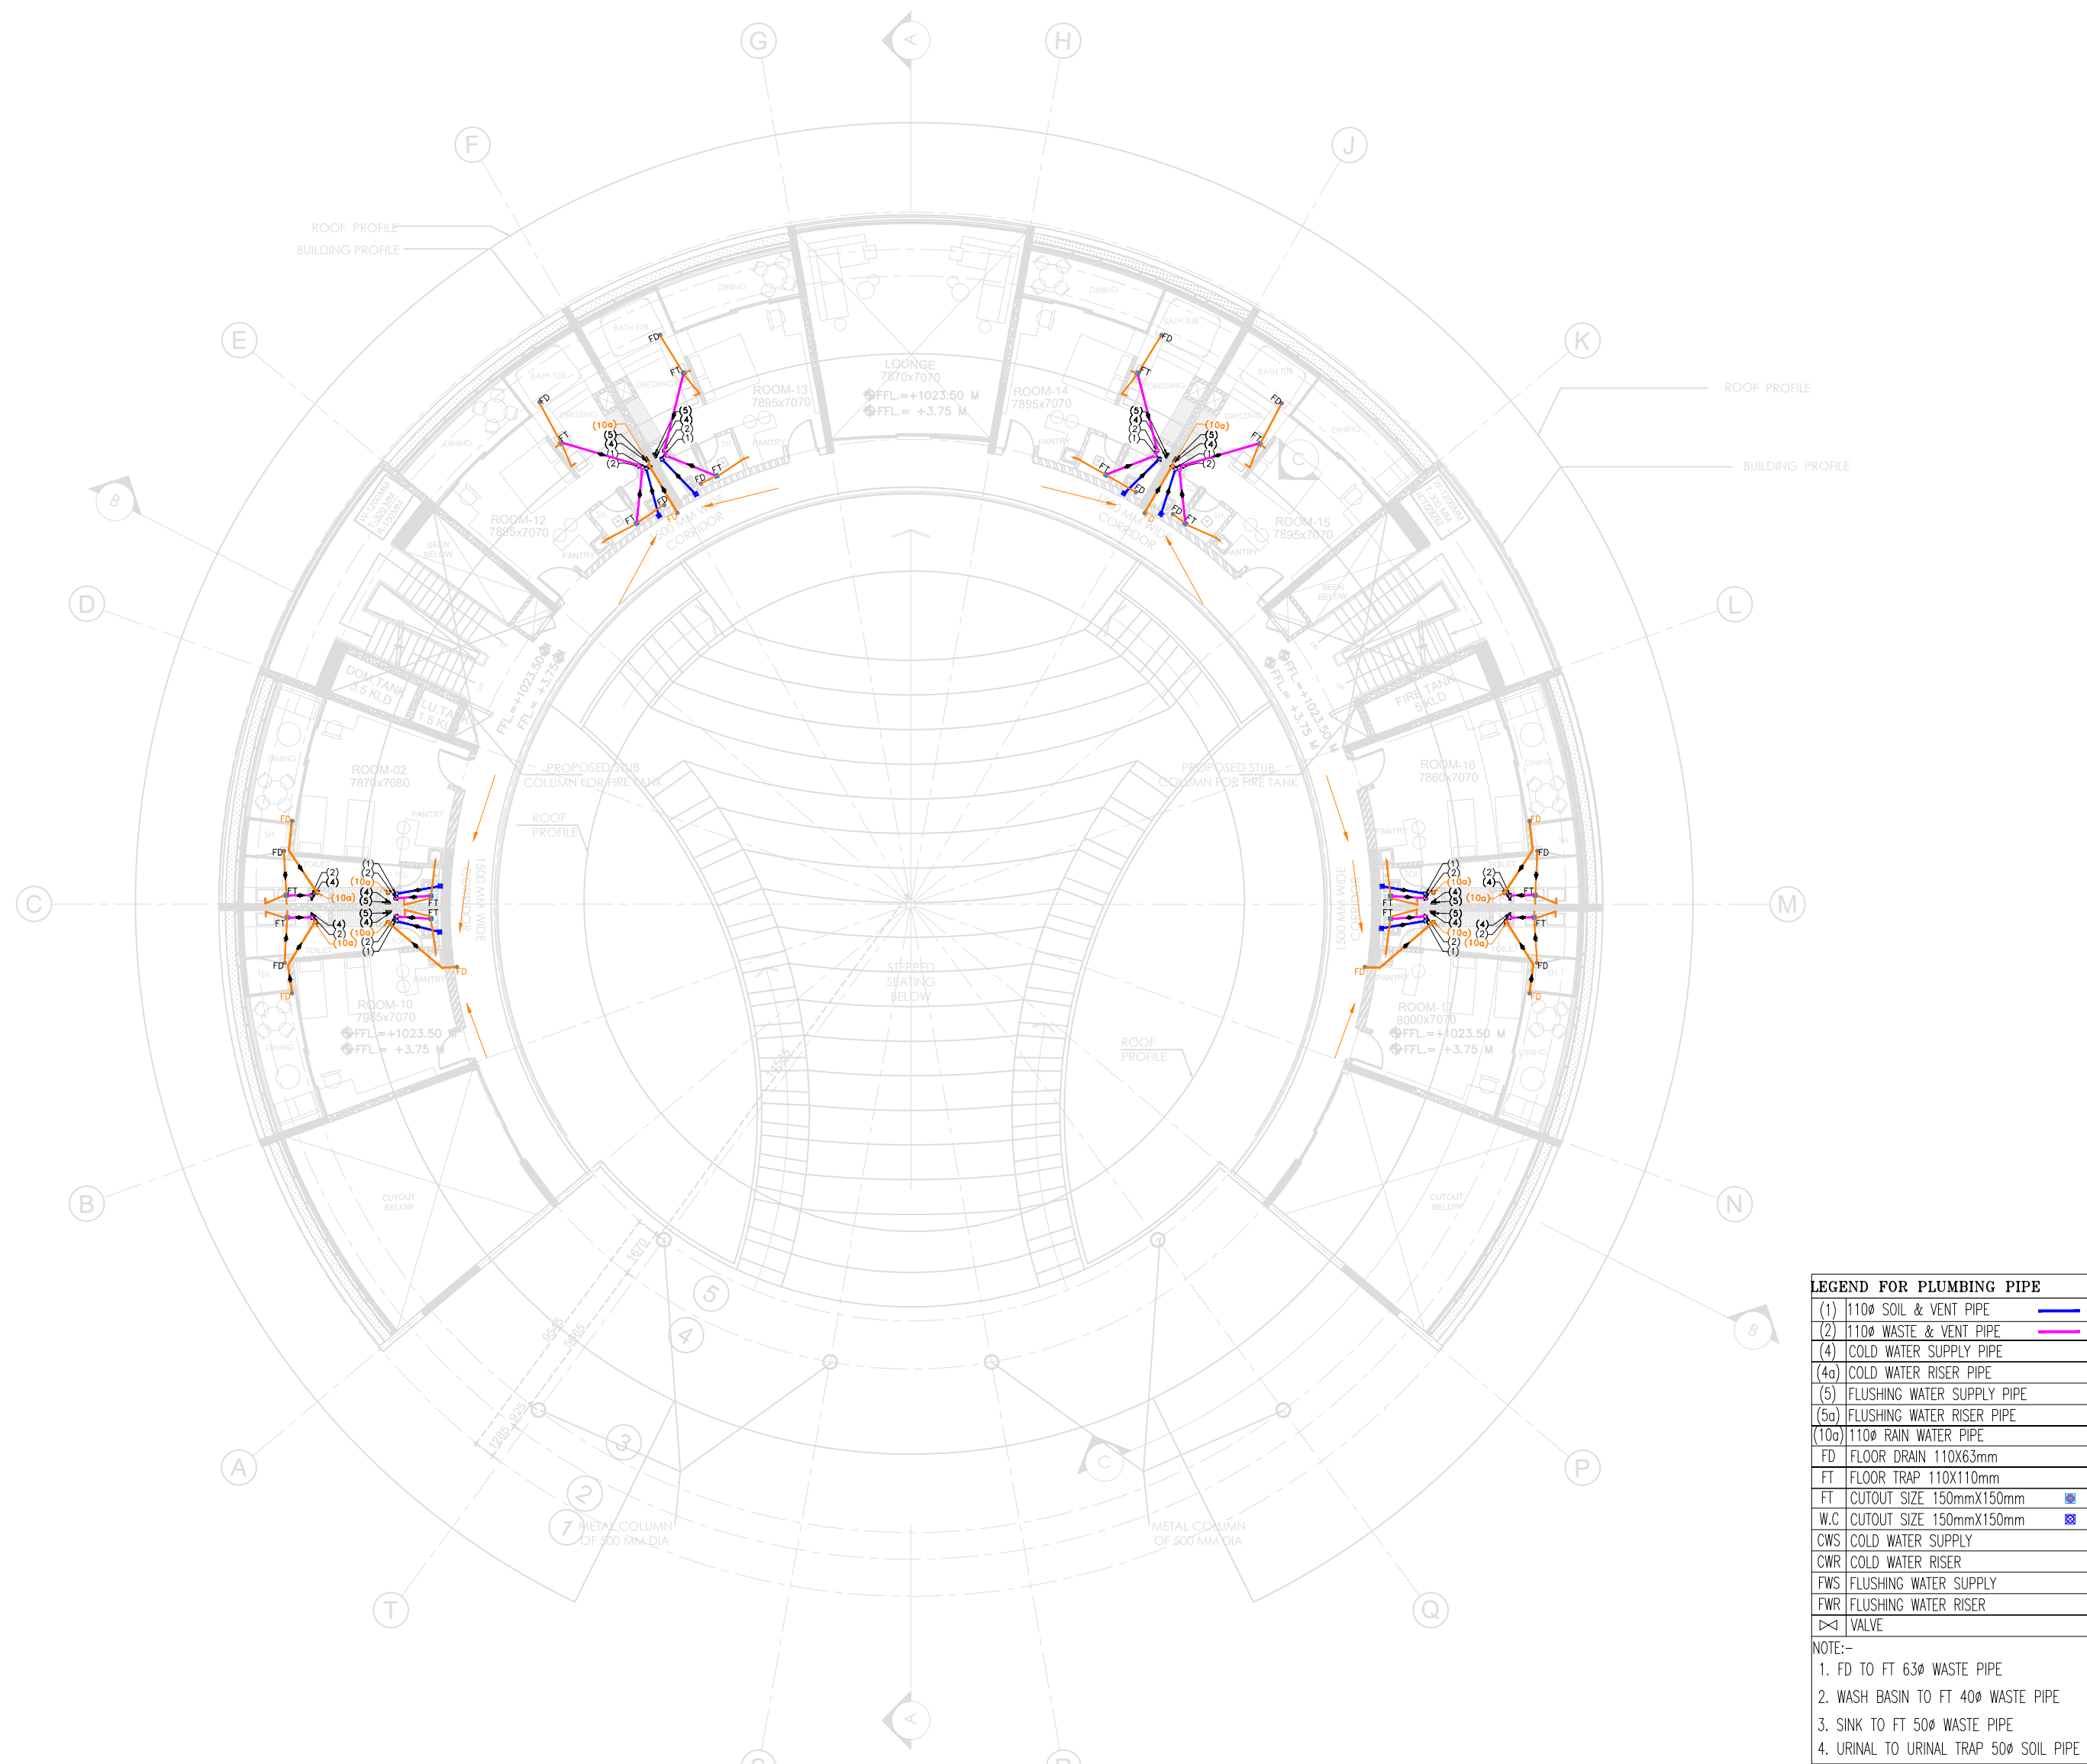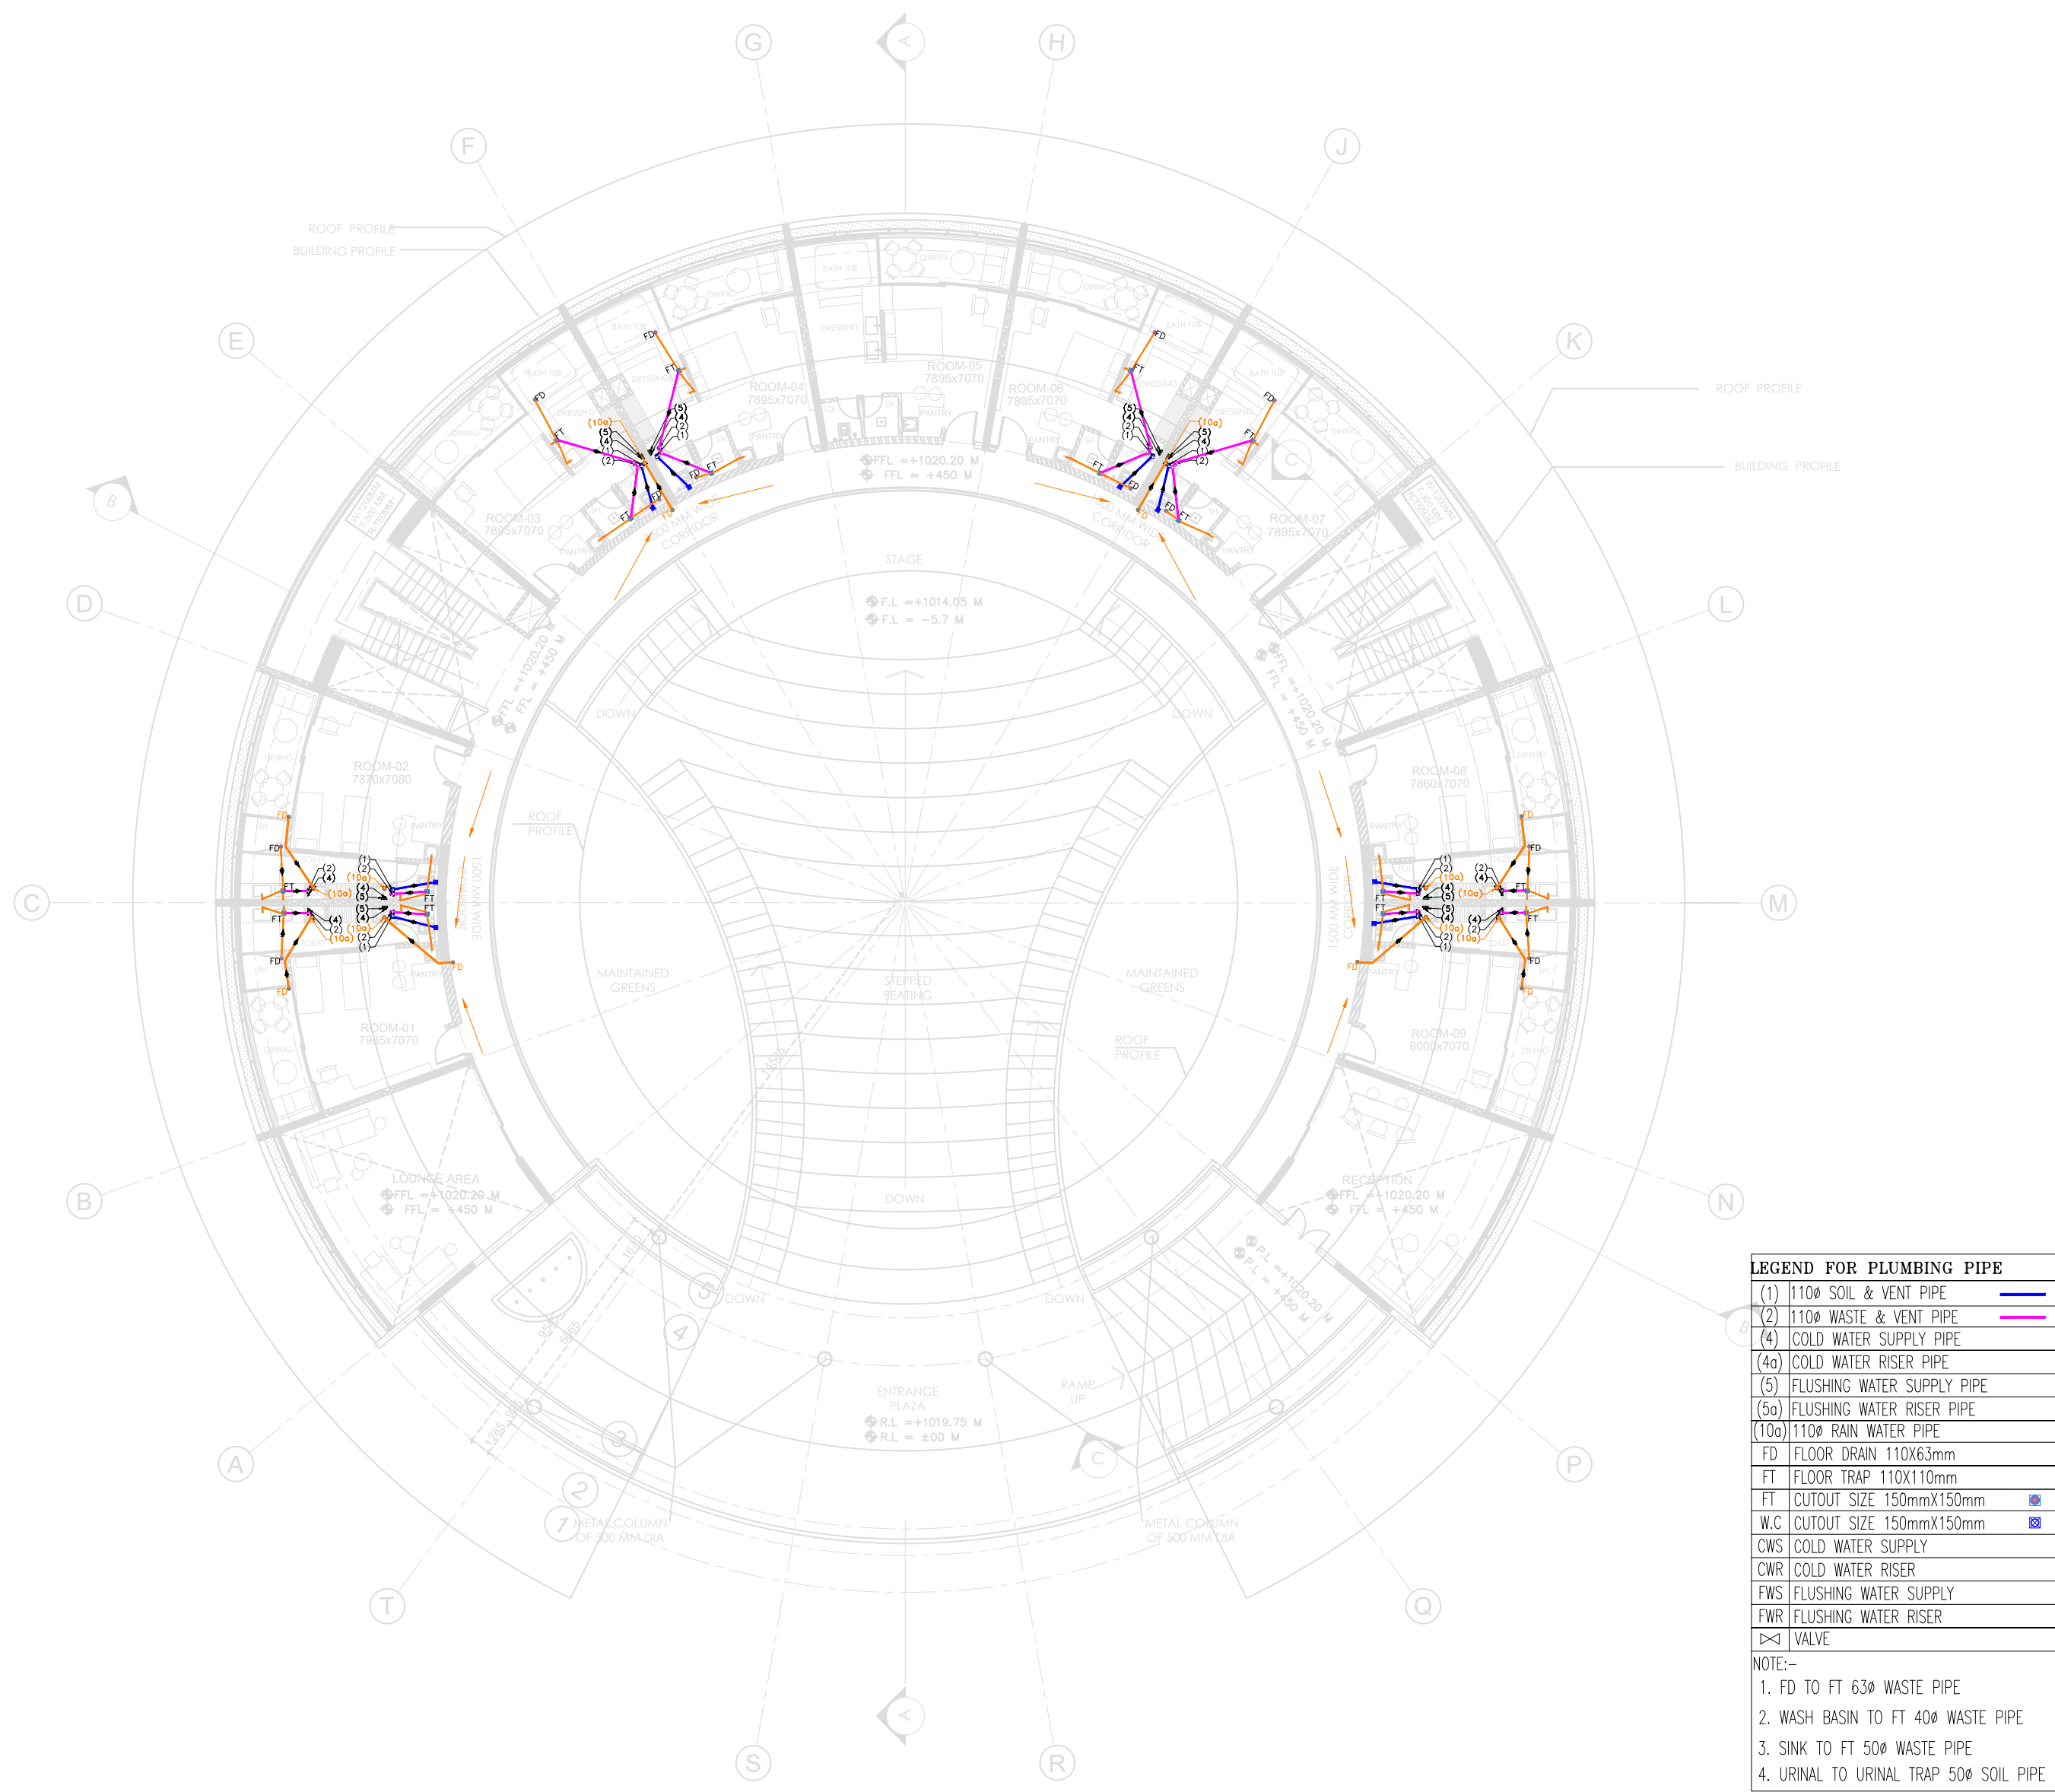

NOTES:

- DO NOT SCALE THE DRAWING. FOLLOW ONLY FIGURED DIMENSIONS
- ALL DIMENSIONS GIVEN IN THIS DRAWING ARE IN MILLIMETERS UNLESS NOTED OTHERWISE.
- ALL DIMENSIONS TO BE VERIFIED ON SITE AND APPROVED BY THE SITE ENGINEER
- ANY DISCREPANCY OR AMBIGUITY IN THE DRAWINGS SHOULD IMMEDIATELY BE BROUGHT TO NOTICE OF THE ARCHITECT.
- ALL DRAWINGS SHOULD BE READ IN CONJUNCTION WITH OTHER RELEVANT ARCHITECTURAL, STRUCTURAL, PLUMBING, MECHANICAL AND ELECTRICAL DRAWINGS.
- THE ± 0 REFERS TO LEVEL ESTABLISHED AT SITE IN PRESENCE OF THE SITE SUPERVISOR AND THE ARCHITECT. ALL REMAINING LEVELS ARE RELATIVE TO THIS LEVEL.
- THIS DRAWING IS THE COPYRIGHT OF ARCHOHM CONSULTANTS AND MUST NOT BE RETAINED, COPIED OR USED WITHOUT THEIR AUTHORITY.

REVISIONS

No.	Date	Descriptions	Revision by

Client:

MEGHALAYAN AGE LIMITED (MAL)

Project:

TRIBAL HERITAGE CENTRE, MANDALGRE, MEGHALAYA

Architects:



Structural Consultants:

TPC TECHNICAL PROJECTS CONSULTANTS (PVT.) LTD.
H/O: B-14, Sector 02, Noida, Uttar Pradesh
T: 91 120 42 48 788
M: 91 120 42 48 788
E: mail@tpcprojects.com
www.tpcprojects.com

Electrical Consultants:

ARCHOHM CONSULTANT PVT. LTD.
H/O: B-14, Sector 02, Noida, Uttar Pradesh
T: 91 120 42 48 788
M: 91 120 42 48 788
E: mail@archohm.com
www.archohm.com

M/E Consultants:

WVAC Engineers INDIA PVT. LTD.
MEP Consultants & Project Managers
H/O: B-14, Sector 02, Noida, Uttar Pradesh
T: 91 120 42 48 788
M: 91 120 42 48 788
E: mail@wvacindia.com
www.wvacindia.com

Drawn By

PK

Checked By

SHAD

Design By

SHAD

Sheet Title:
**PLUMBING DRAINAGE SYSTEM
TRIBAL HERITAGE CENTRE
ACCOMMODATION BLOCK**

Date:

29-08-2024

Drawing No.:

A-232409-B2-PL-01-01

Scale:

1:200

Project No.:

A-232409

Sheet No.:

A1

R0